


□ □ □ / □ □ / □

PROJECT NAME:
THE ROYAL PALACE
DEVELOPER NAME:
SHREE RAM INFRA

Ms Shree Ram Infra
Partner

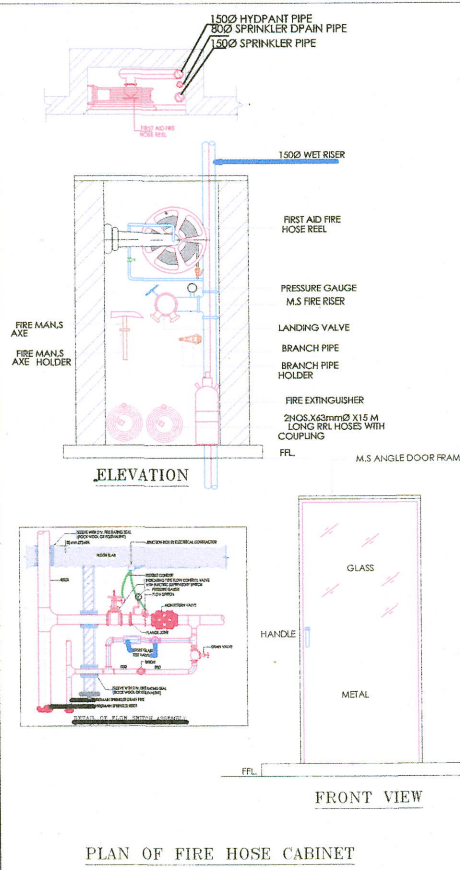

LEGEND:-

FIRE HYDRANT MS PIPE	
BALL VALVE	
EXTERNAL FIRE HYDRANT	
EXTERNAL FIRE HOSE CABINAT	
FIRE HOSE CABINAT	
UPRIGHT SPRINKLER HEAD	
PENDENT SPRINKLER HEAD	
SIDE WALL SPRINKLER HEAD	
FIRE EXINGUISHER	
FLOW SWITCH	FS
ISOLATION VALVE	IV
2 WAY FIRE BRIGADE INLET	

PROJECT:
PROPOSED RESIDENTIAL "THE ROYAL PALACE" BUILDING ON PLOT NO. - 45 SCHEME -24 (RAJAT VIHAR), JAIPUR.

NAME OF DRAWING:
STILT FLOOR
FIRE FIGHTING LAYOUT

DRAWING Area calculation	NORTH
PROJECT NO.:	DATE: 26, JUN. - 2024
SCALE: NTS	REV NO.: R-0
DRAWING NO.:	
PROJECT CATEGORY BLOCK FLOOR TYPE NUMBER	
A-01	

P.NO.25A


PARK

90'

P.NO.46

145'

P.NO.44

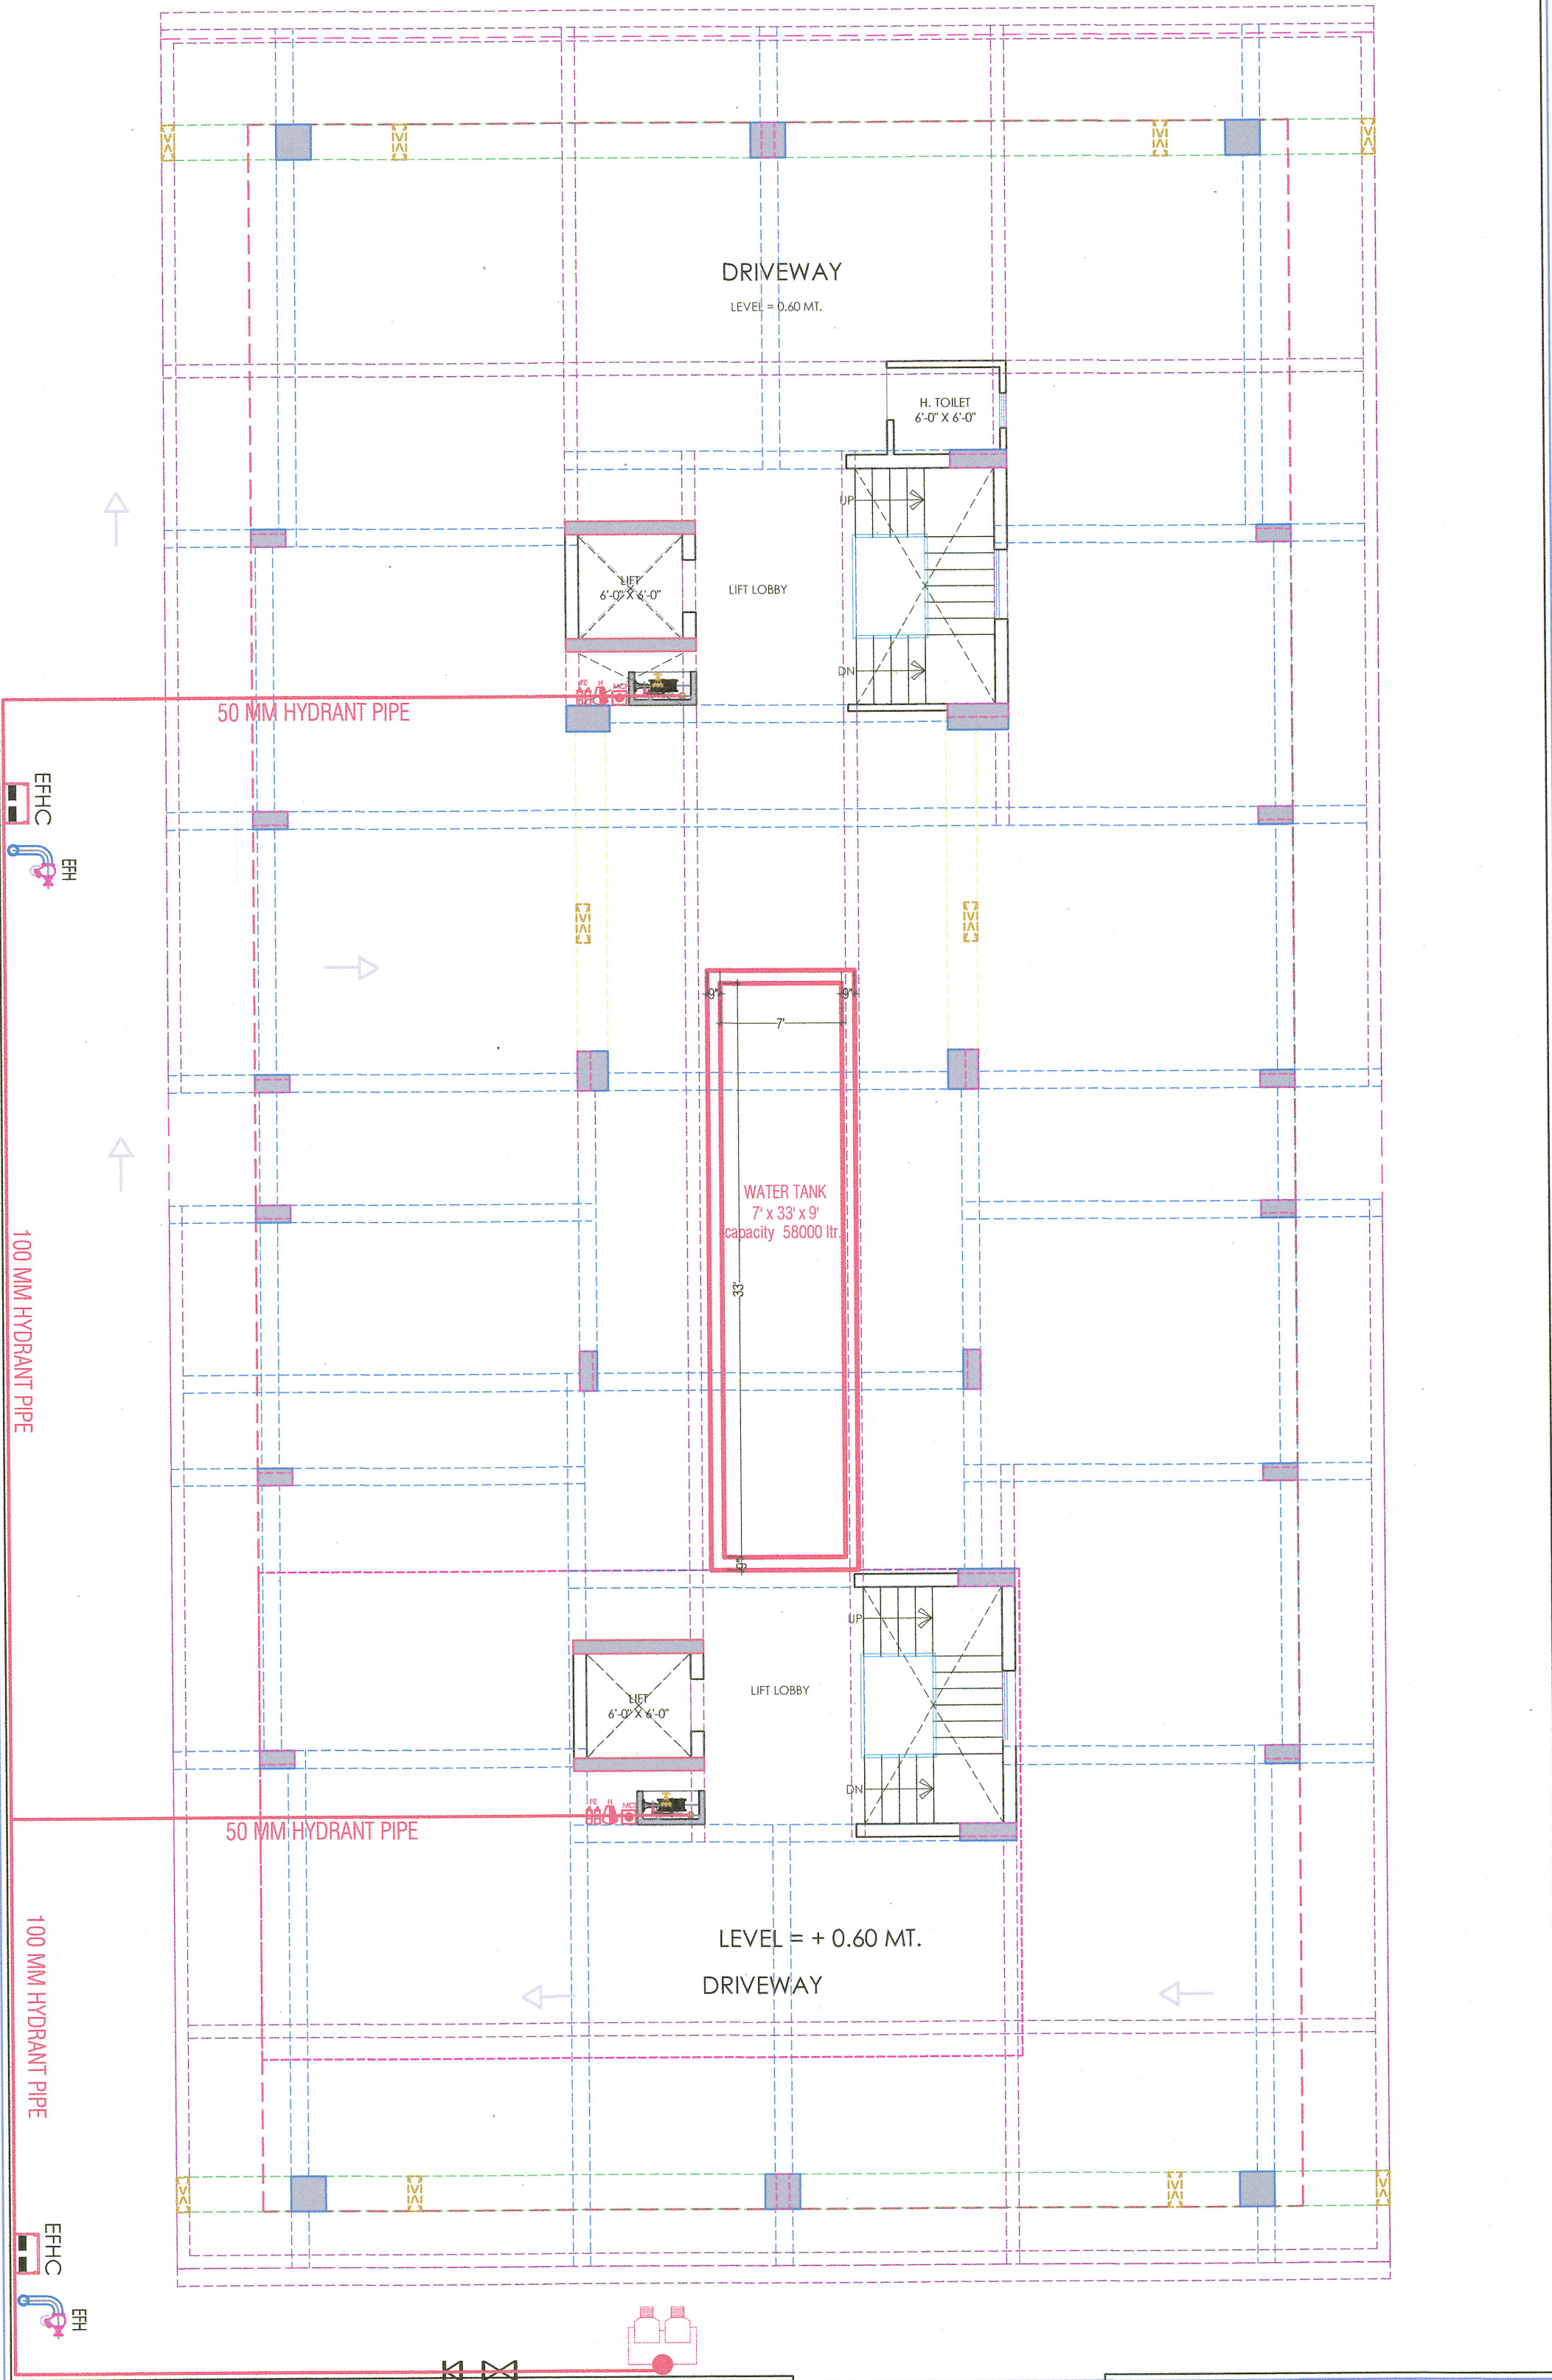


STILT FLOOR FIRE FIGHTING LAYOUT

Er. SANJEEV SHARMA
B.E (Electrical)

PROJECT NAME:
THE ROYAL PALACE
DEVELOPER NAME:
SHREE RAM INFRA

M/s Shree Ram Infra
21/6

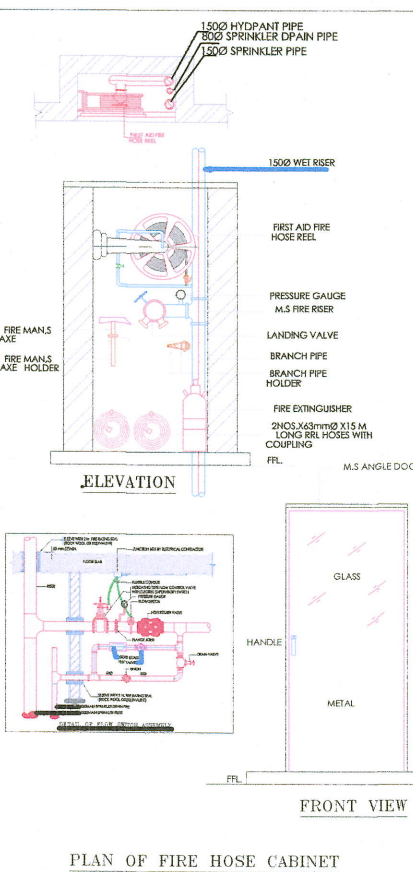


LEGEND:-

FIRE HYDRANT MS PIPE	
BALL VALVE	1/2
EXTERNAL FIRE HYDRANT	1/2
EXTERNAL FIRE HOSE CABINET	1/2
FIRE HOSE CABINET	1/2
UPRIGHT SPRINKLER HEAD	1/2
PENDENT SPRINKLER HEAD	1/2
SIDE WALL SPRINKLER HEAD	1/2
FIRE EXTINGUISHER	1/2
FLOW SWITCH	FS
ISOLATION VALVE	IV
2 WAY FIRE BRIGADE INLET	1/2

PROPOSED RESIDENTIAL "THE ROYAL PALACE" BUILDING ON PLOT NO. - 45 SCHEME - 24 (RAJAT VIHAR), JAIPUR.

NAME OF DRAWING:
TYPICAL FLOOR
FIRE FIGHTING LAYOUT

DRAWING Area calculation	NORTH: 26. JUN. - 2024
PROJECT NO.:	DATE:
SCALE: NTS	REV NO.: R-0
DRAWING NO.:	
PROJECT	CATEGORY
A-01	

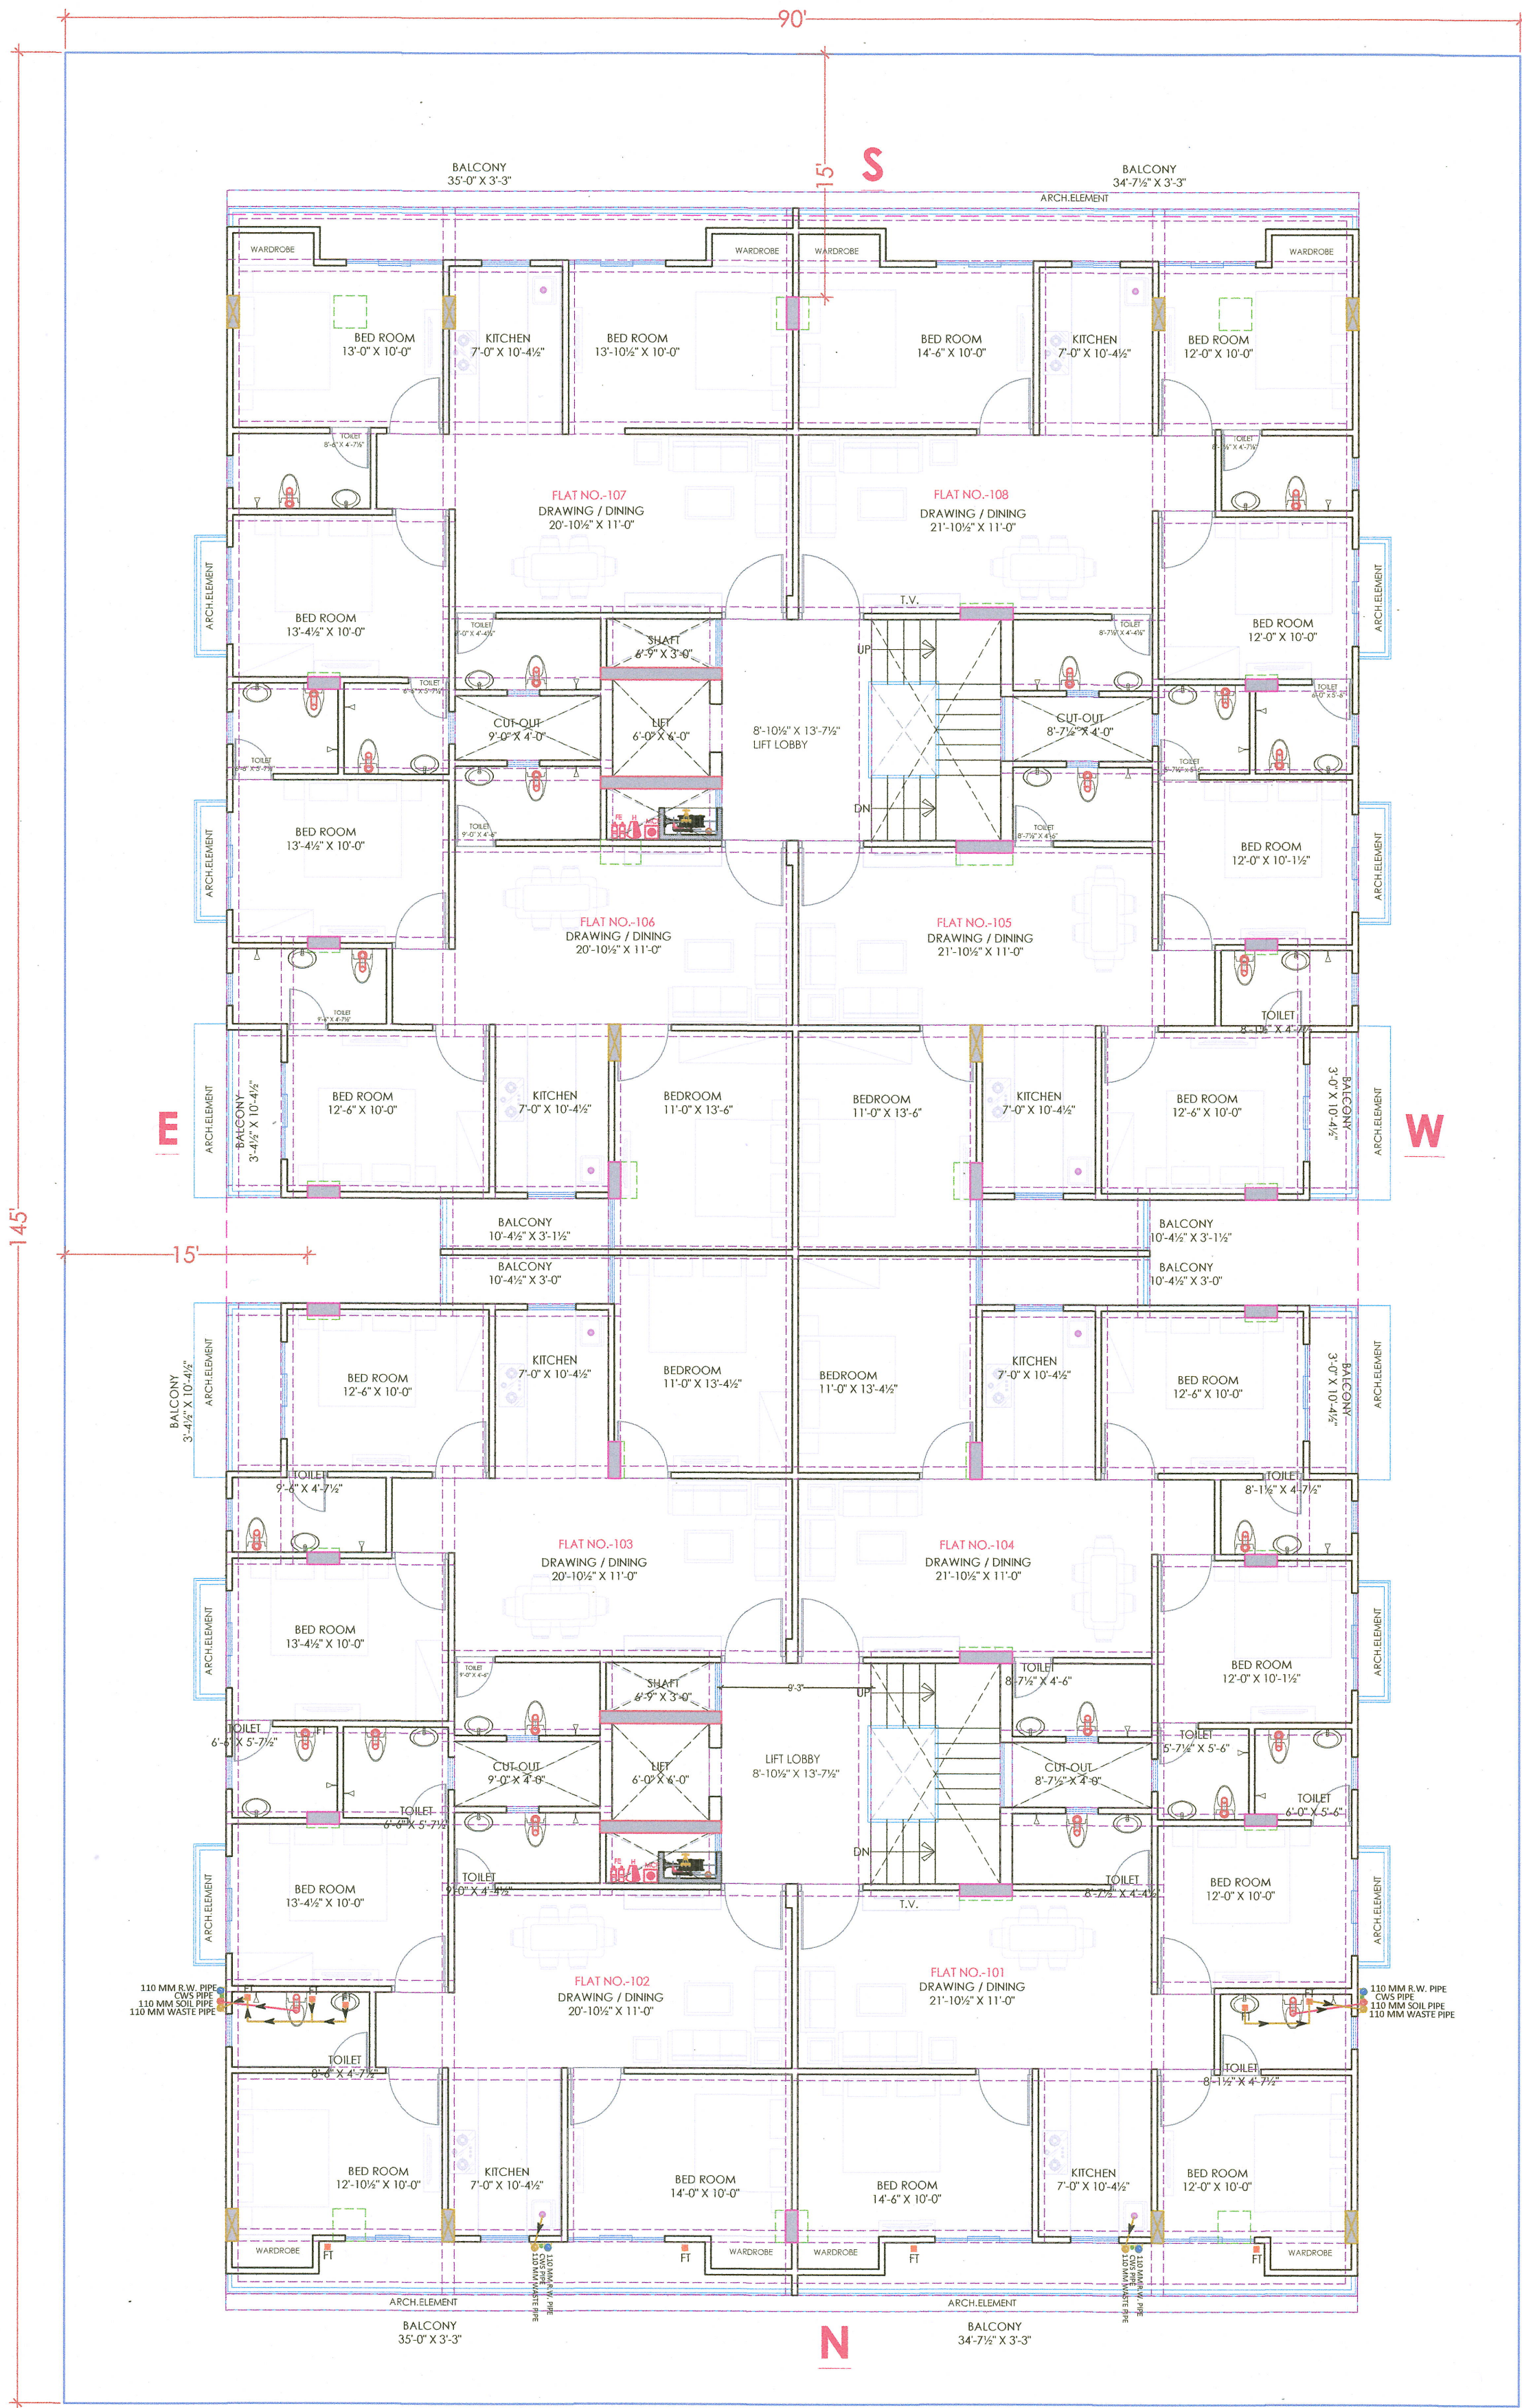


ZDP ROAD 60'-0" WIDE

TYPICAL FLOOR FIRE FIGHTING LAYOUT

Er. SANJEEV SHARMA
B.E (Electrical)

PROJECT NAME:
THE ROYAL PALACE
DEVELOPER NAME:
SHREE RAM INFRA

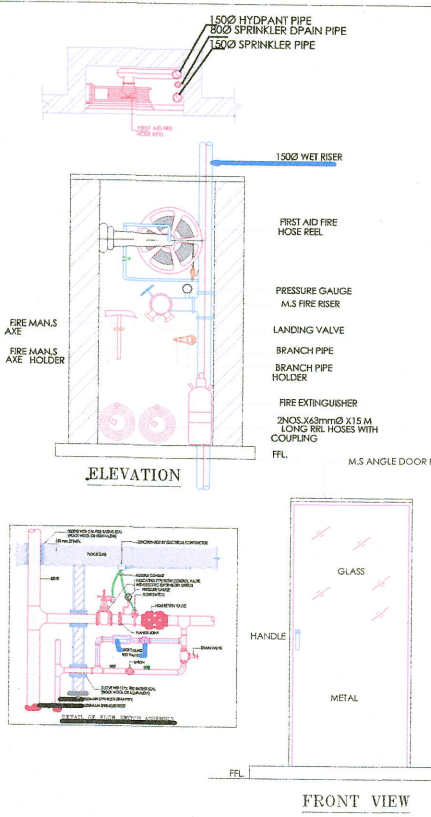

LEGEND:-


FIRE HYDRANT MS PIPE	
BALL VALVE	
EXTERNAL FIRE HYDRANT	
EXTERNAL FIRE HOSE CABINAT	EFHC
FIRE HOSE CABINAT	FHC
UPRIGHT SPRINKLER HEAD	
PENDENT SPRINKLER HEAD	
SIDE WALL SPRINKLER HEAD	
FIRE EXINGUISHER	
FLOW SWITCH	FS
ISOLATION VALVE	IV
2 WAY FIRE BRIGADE INLET	

PROJECT:
PROPOSED RESIDENTIAL "THE ROYAL PALACE" BUILDING ON PLOT NO. - 45 SCHEME -24 (RAJAT VIHAR), JAIPUR.

NAME OF DRAWING:
TERRACE FLOOR FIRE FIGHTING LAYOUT

DRAWING Area calculation	NORTH:
PROJECT NO.:	DATE: 26, JUN. - 2024
SCALE: NTS	REV NO.: R-0
DRAWING NO.:	
PROJECT	CATEGORY
AREA	TYPE
NUMBER	

A-01

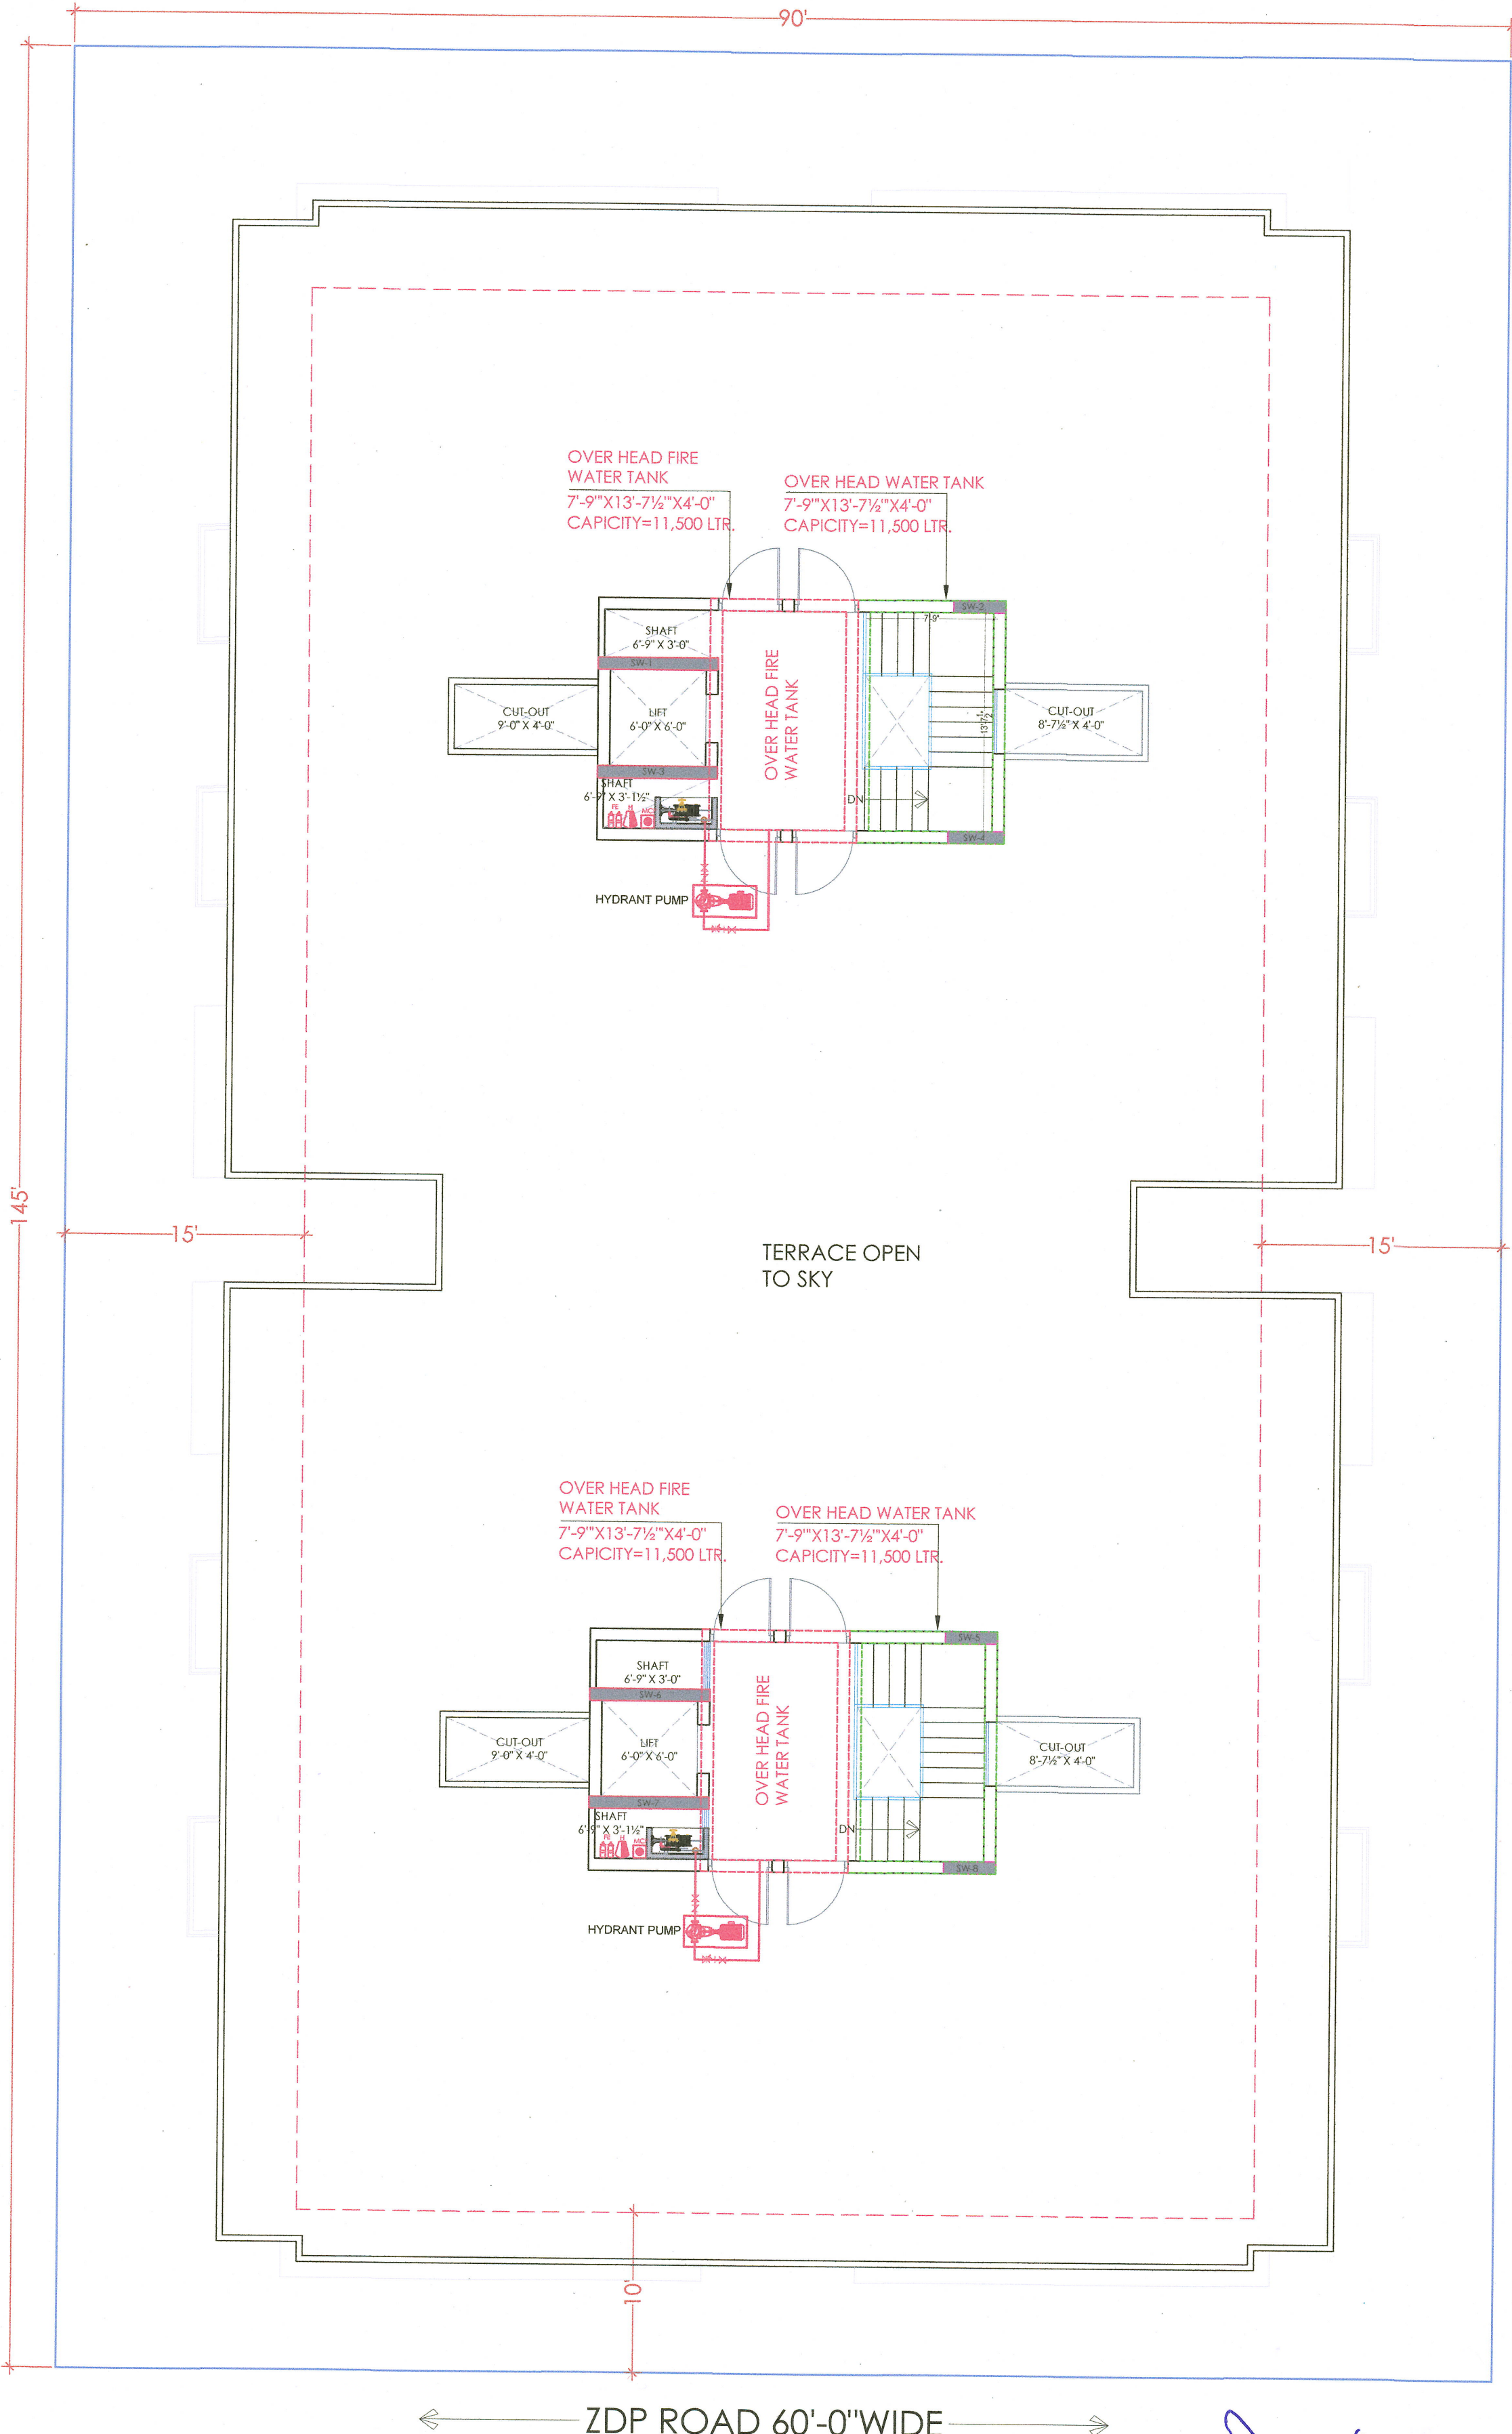

ZDP ROAD 60'-0"WIDE

TERRACE FLOOR FIRE FIGHTING LAYOUT

Er. SANJEEV SHARMA
B.E (Electrical)

PROJECT NAME:
THE ROYAL PALACE

DEVELOPER NAME:
SHREE RAM INFRA

LEGENDS:			
Mounting Height	I D	Symbol	Description
CEILING	FAN/48"		CEILING FAN 48"
CEILING	FAN/30"		CEILING FAN 30"
CEILING	CH1		CHANDELIER
+93"	TL/W		Led Wall Tube Light
+93"	BULB		Led Bulb 20W
+93"	GL		WALL BRACKETS AS DESIGN FOR GANESH LIGHT
+78"	ML		12x2 Led Mirror Light
CEILING	DL		Led 6" Down Lighter 20W (Surface Mounted)
VENTILATOR HT.	CR		CEILING ROSE
VENTILATOR HT.	EXF		9" DIA FRESH AIR FAN
+24"	2wSB		2w SWITCH BOARD
+42"	SB		SWITCH BOARD(6A SOCKET & SWITCH)
+24"	TEL		TELEPHONE POINT
+24"	LP TEL		6 A PLUG POINT FOR TELEPHONE
+48"	TV		TV COAXIAL POINT
+48"	LP TV		6 A PLUG POINT FOR TV
+24"	LP		6 A PLUG POINT FOR SIDE TABLE
+72"	LP-CH		6 A PLUG POINT FOR CHIMNEY
+12"	LP PC		6 A PLUG FOR COMPUTER POINT
+93"	SAC		SPLIT AC INDOOR UNIT
+42"	PP-MIX		16 A POWER POINT FOR MIXER
+42"	PP-MIC		16 A POWER POINT FOR MICROWAVE
+78"	PP-G		16 A POWER POINT FOR GEYSER
+54"	PP-F		16 A POWER POINT FOR FRIDGE
+78"	PP-WP		16 A POWER POINT FOR WATER PURIFIER
+48"	PP-WM		16 A POWER POINT FOR WASHING MACHINE
+12"	PP-INV.		16 A POWER POINT FOR INVERTOR
+93"	PP-AC		25A SWITCH/MCB FOR AC
			CHAMBER(2' X 2')
+18"			6A 2 NOS. SOCKET-1 NOS, 16A SWITCH, TELEPHONE LAN
+60"	MCB DB		MCB DISTRIBUTION BOARD
			CAMERA
			WALL FAN
BSB	6A S/S, FAN REGULATOR, TL SWITCH		
BAC	6A S/S, 25A AC		

- S.No DATE REVISION DESCRIPTION
- GENERAL NOTES :
- All dimension on this drawing are in MKS System Only written dimensions are to be followed. drawing should not be scaled.
 - All measurements must be checked and verified by the contractors prior to execution of work at the site.
 - This drawing is to be read in conjunction with all relevant structural, services & facility planning drawings.
 - Architectural drawings are to be followed for the location of all structural members & masonry walls, for sizes & reinforcement details of structural members, relevant structural drawings are to be referred.
 - Any discrepancies between architectural, structural and services drawings must be brought to the notice of the architects immediately & prior to execution at site.
 - Co-ordinate with services such as hvac, plumbing & electrical, etc. is the responsibility of the contractors.
 - All masonry walls should be aligned with the columns as indicated on the plan, irrespective of the position as calculated with the dimensioning.
 - For details, refer relevant large scale detail drgs. as indicated.


PROJECT:
PROPOSED RESIDENTIAL " THE ROYALS PALACE BUILDING ON PLOT NO. - 45 SCHEME -24 (RAJAT VIHAR) , JAIPUR.

NAME OF DRAWING:
TYPICAL FLOOR ELECTRICAL LAYOUT G+5TH (ELECTRICAL POINT, CEILING POINT,TV)

DRAWING WORKING DRAWING	NORTH:
PROJECT NO. :	DATE : 20-08-2024
SCALE : NTS	REV NO. : R-0

DRAWING NO. :	
PROJECT	CATEGORY
BLOCK	FLOOR
TYPE	NUMBER

A-01

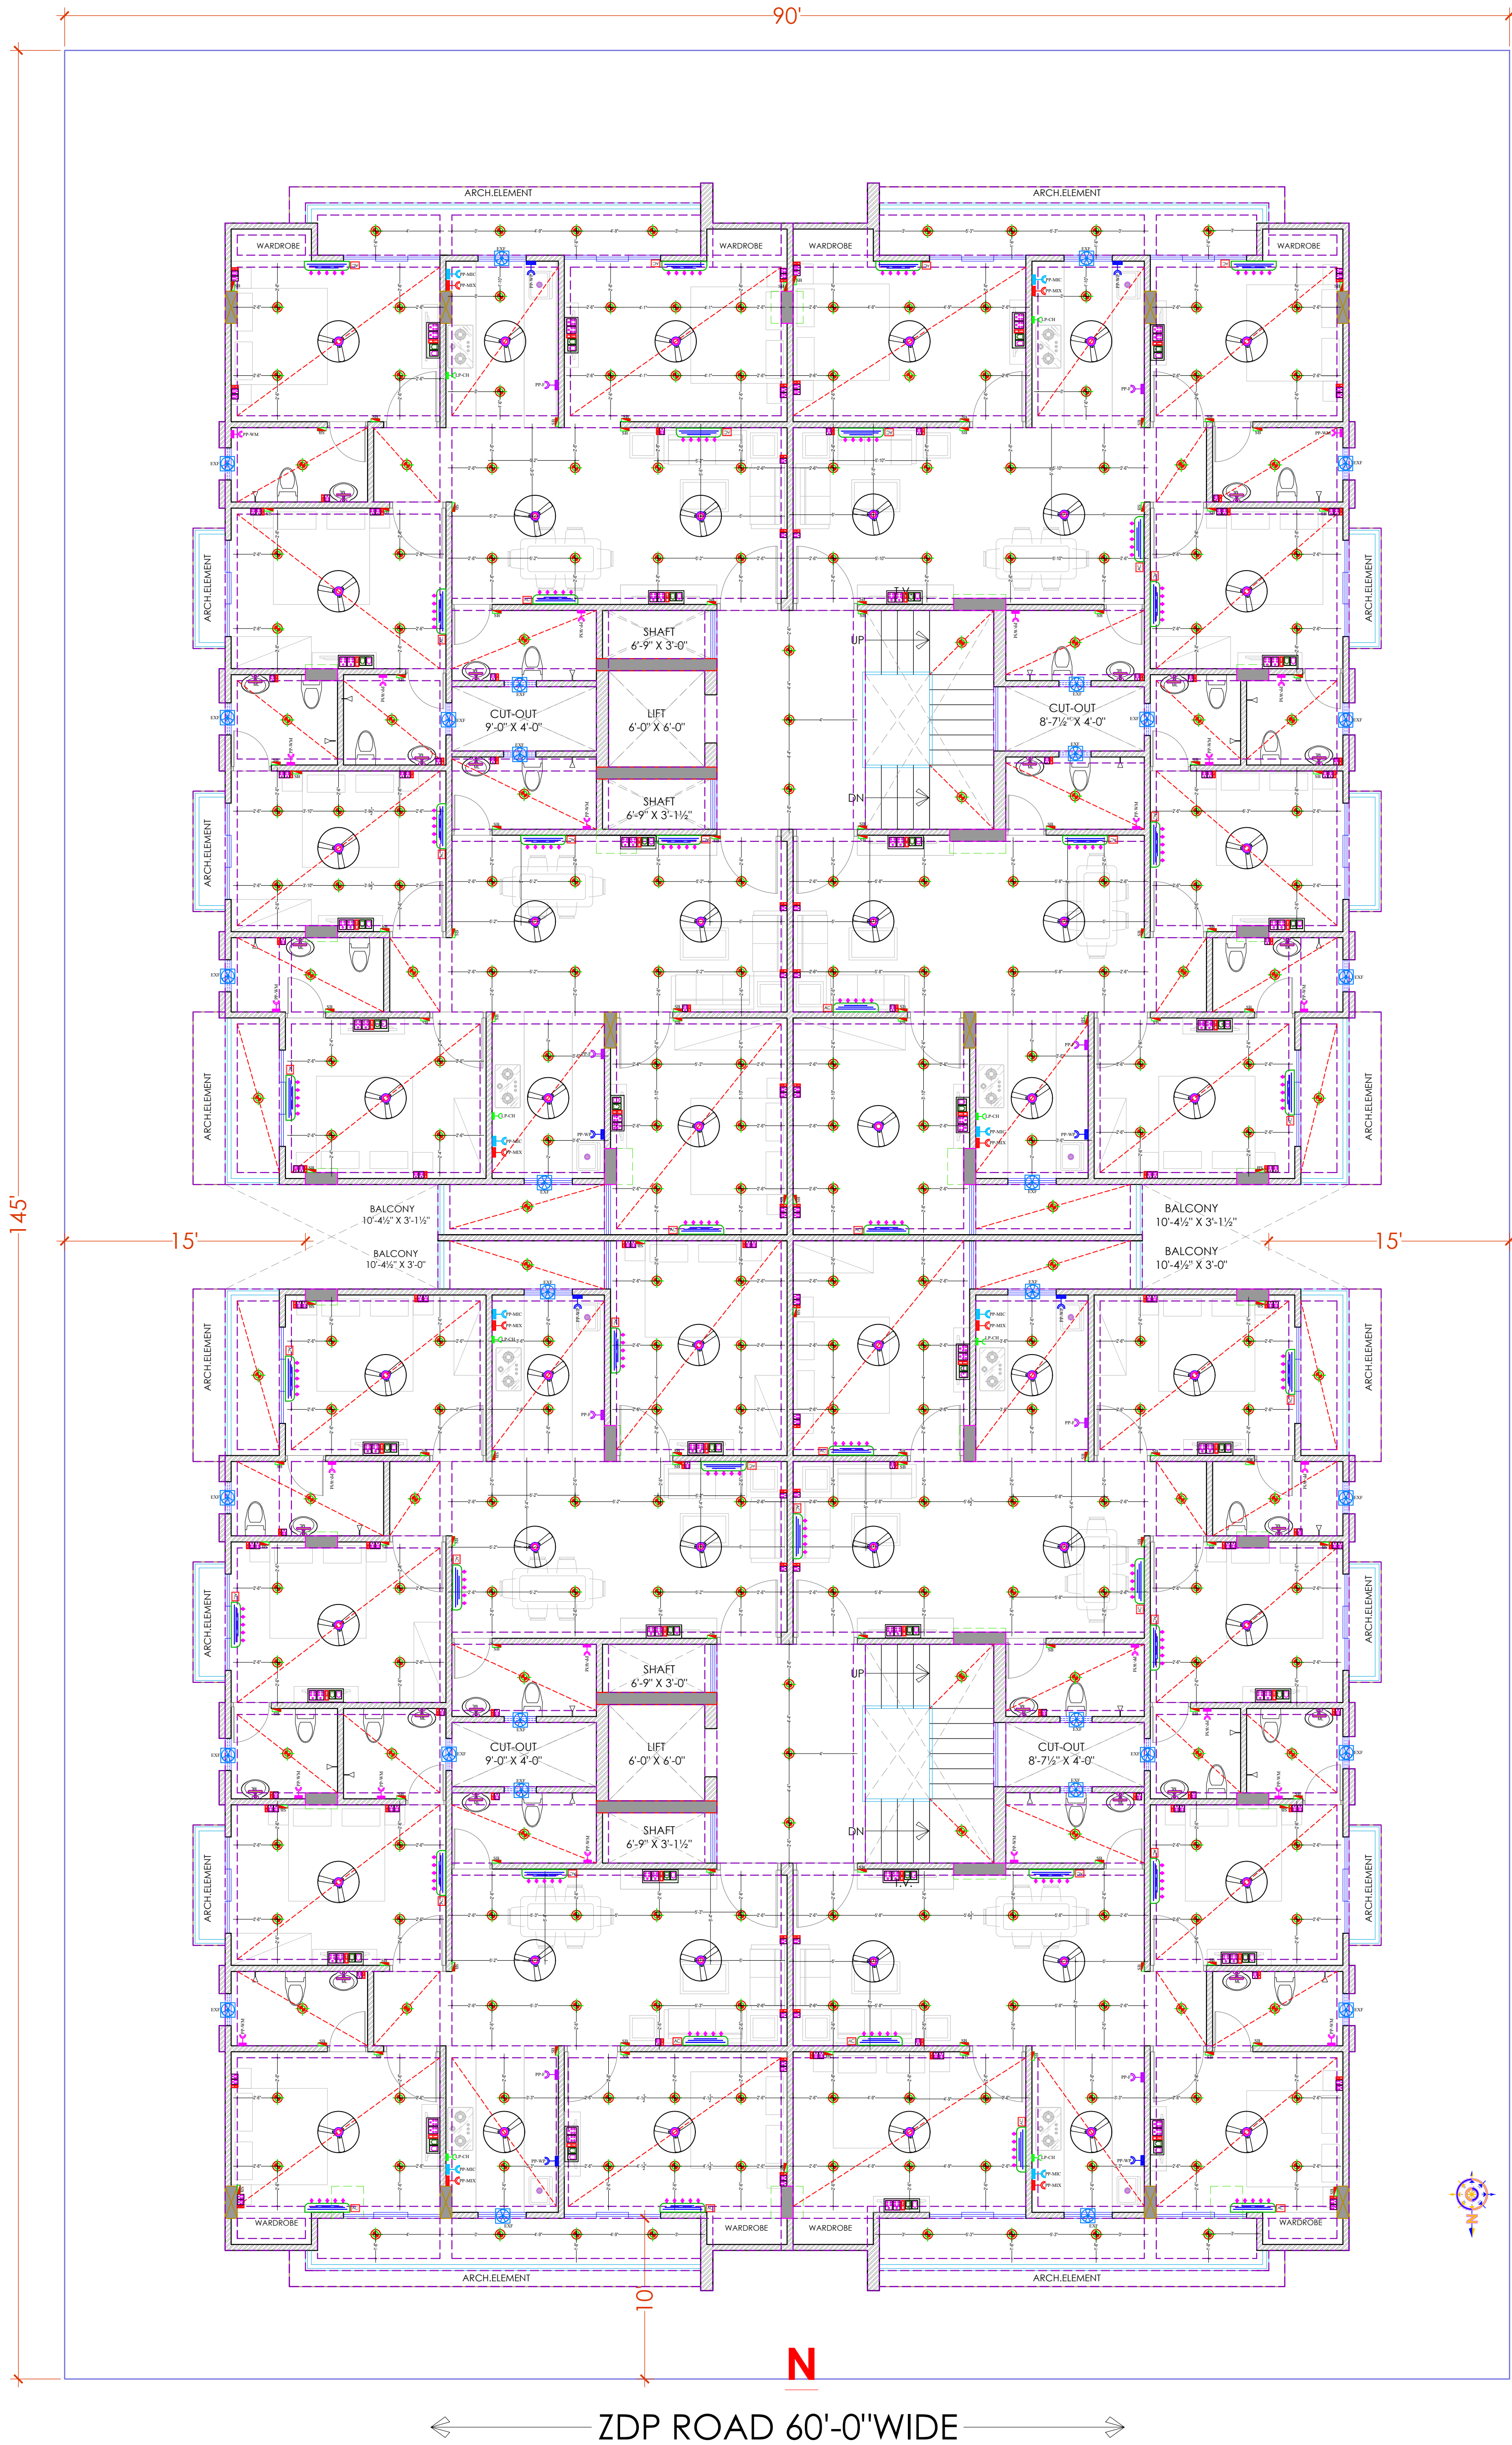

TYPICAL ELECTRICAL LAYOUT (GROUND TO 5TH.)
(ELECTRICAL POINT,CEILING POINT,) Earthing layout,
External Lighting plan/ Layout ,Tv & Telephone Riser
Diagram, Lighting arrester location & Pit location,
coordination drawings

Er. SANJEEV SHARMA
B.E (Electrical)