




OTHER'S PLOT

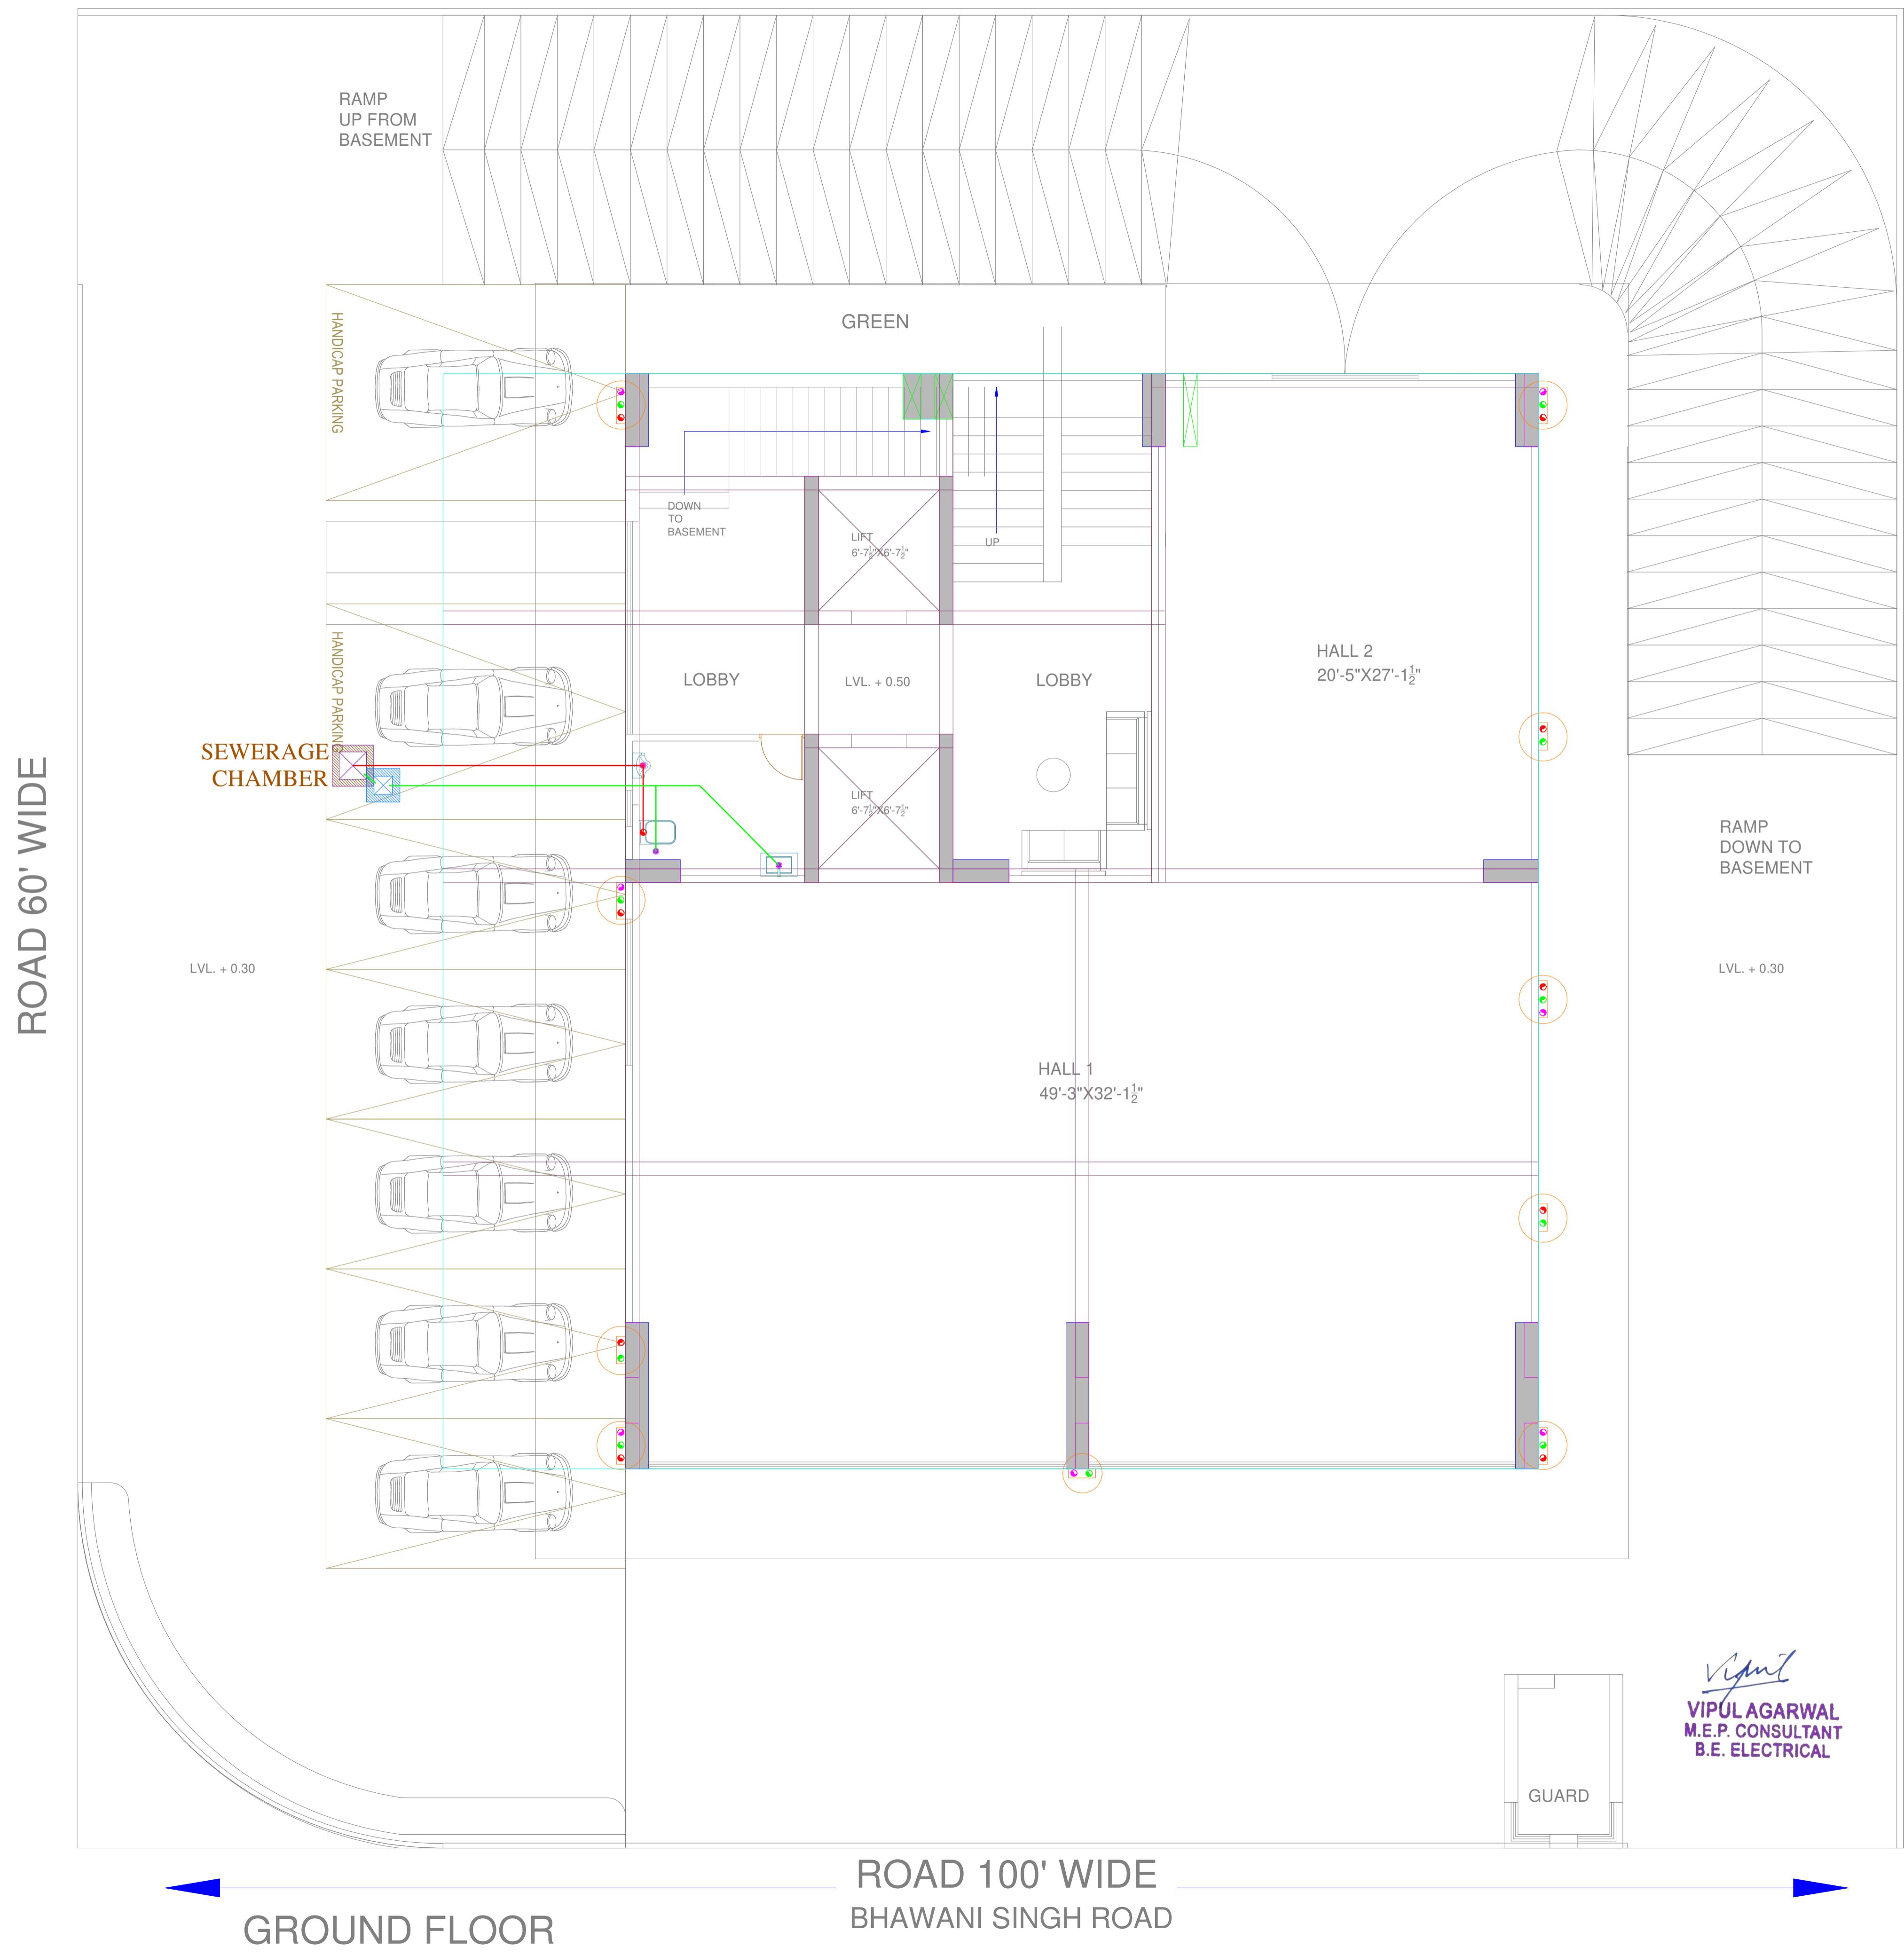

SYMBOL	DESCRIPTION
○	110 mm Soil Waste Water Pipe
○	110 mm Waste Water Pipe
○	110 mm Rain Water Pipe
—	110 mm Soil Waste Water Pipe
—	110 mm Waste Water Pipe
—	110 mm Rain Water Pipe
—	75 mm Waste Water Pipe
—	75 mm Rain Water Pipe
—	50mm Waste Water Pipe
—	Pipe Bottle Trap
○	Floor Trap
→	Flow Direction
PROJECT :-	
GURUKRIPA AARISE	
MEP:-	
SERVICES CONSULTANT: ASHI ASSOCIATES F 9 / 440 , Keshav Marg Chitrakut Scheme, Jaipur PH:91-0-93146-10438 ,0141-2440946 Mail:vipul8599@yahoo.com	
PROPOSED RESIDENTIAL STUDIO APARTMENTS PLOT SB 26 BAPUNAGAR SCHEME , JAIPUR	
GROUND FLOOR COMMON AREA TOILET DRAINAGE PLAN	
DRAWN BY:- NITIN	N
CHECKED BY:- SANJAY	W
	E
S	
DATE : 21-05-2025	SCALE : N.T.S
studio1503 architecture interiors 28032025 studio1503@gmail.com	

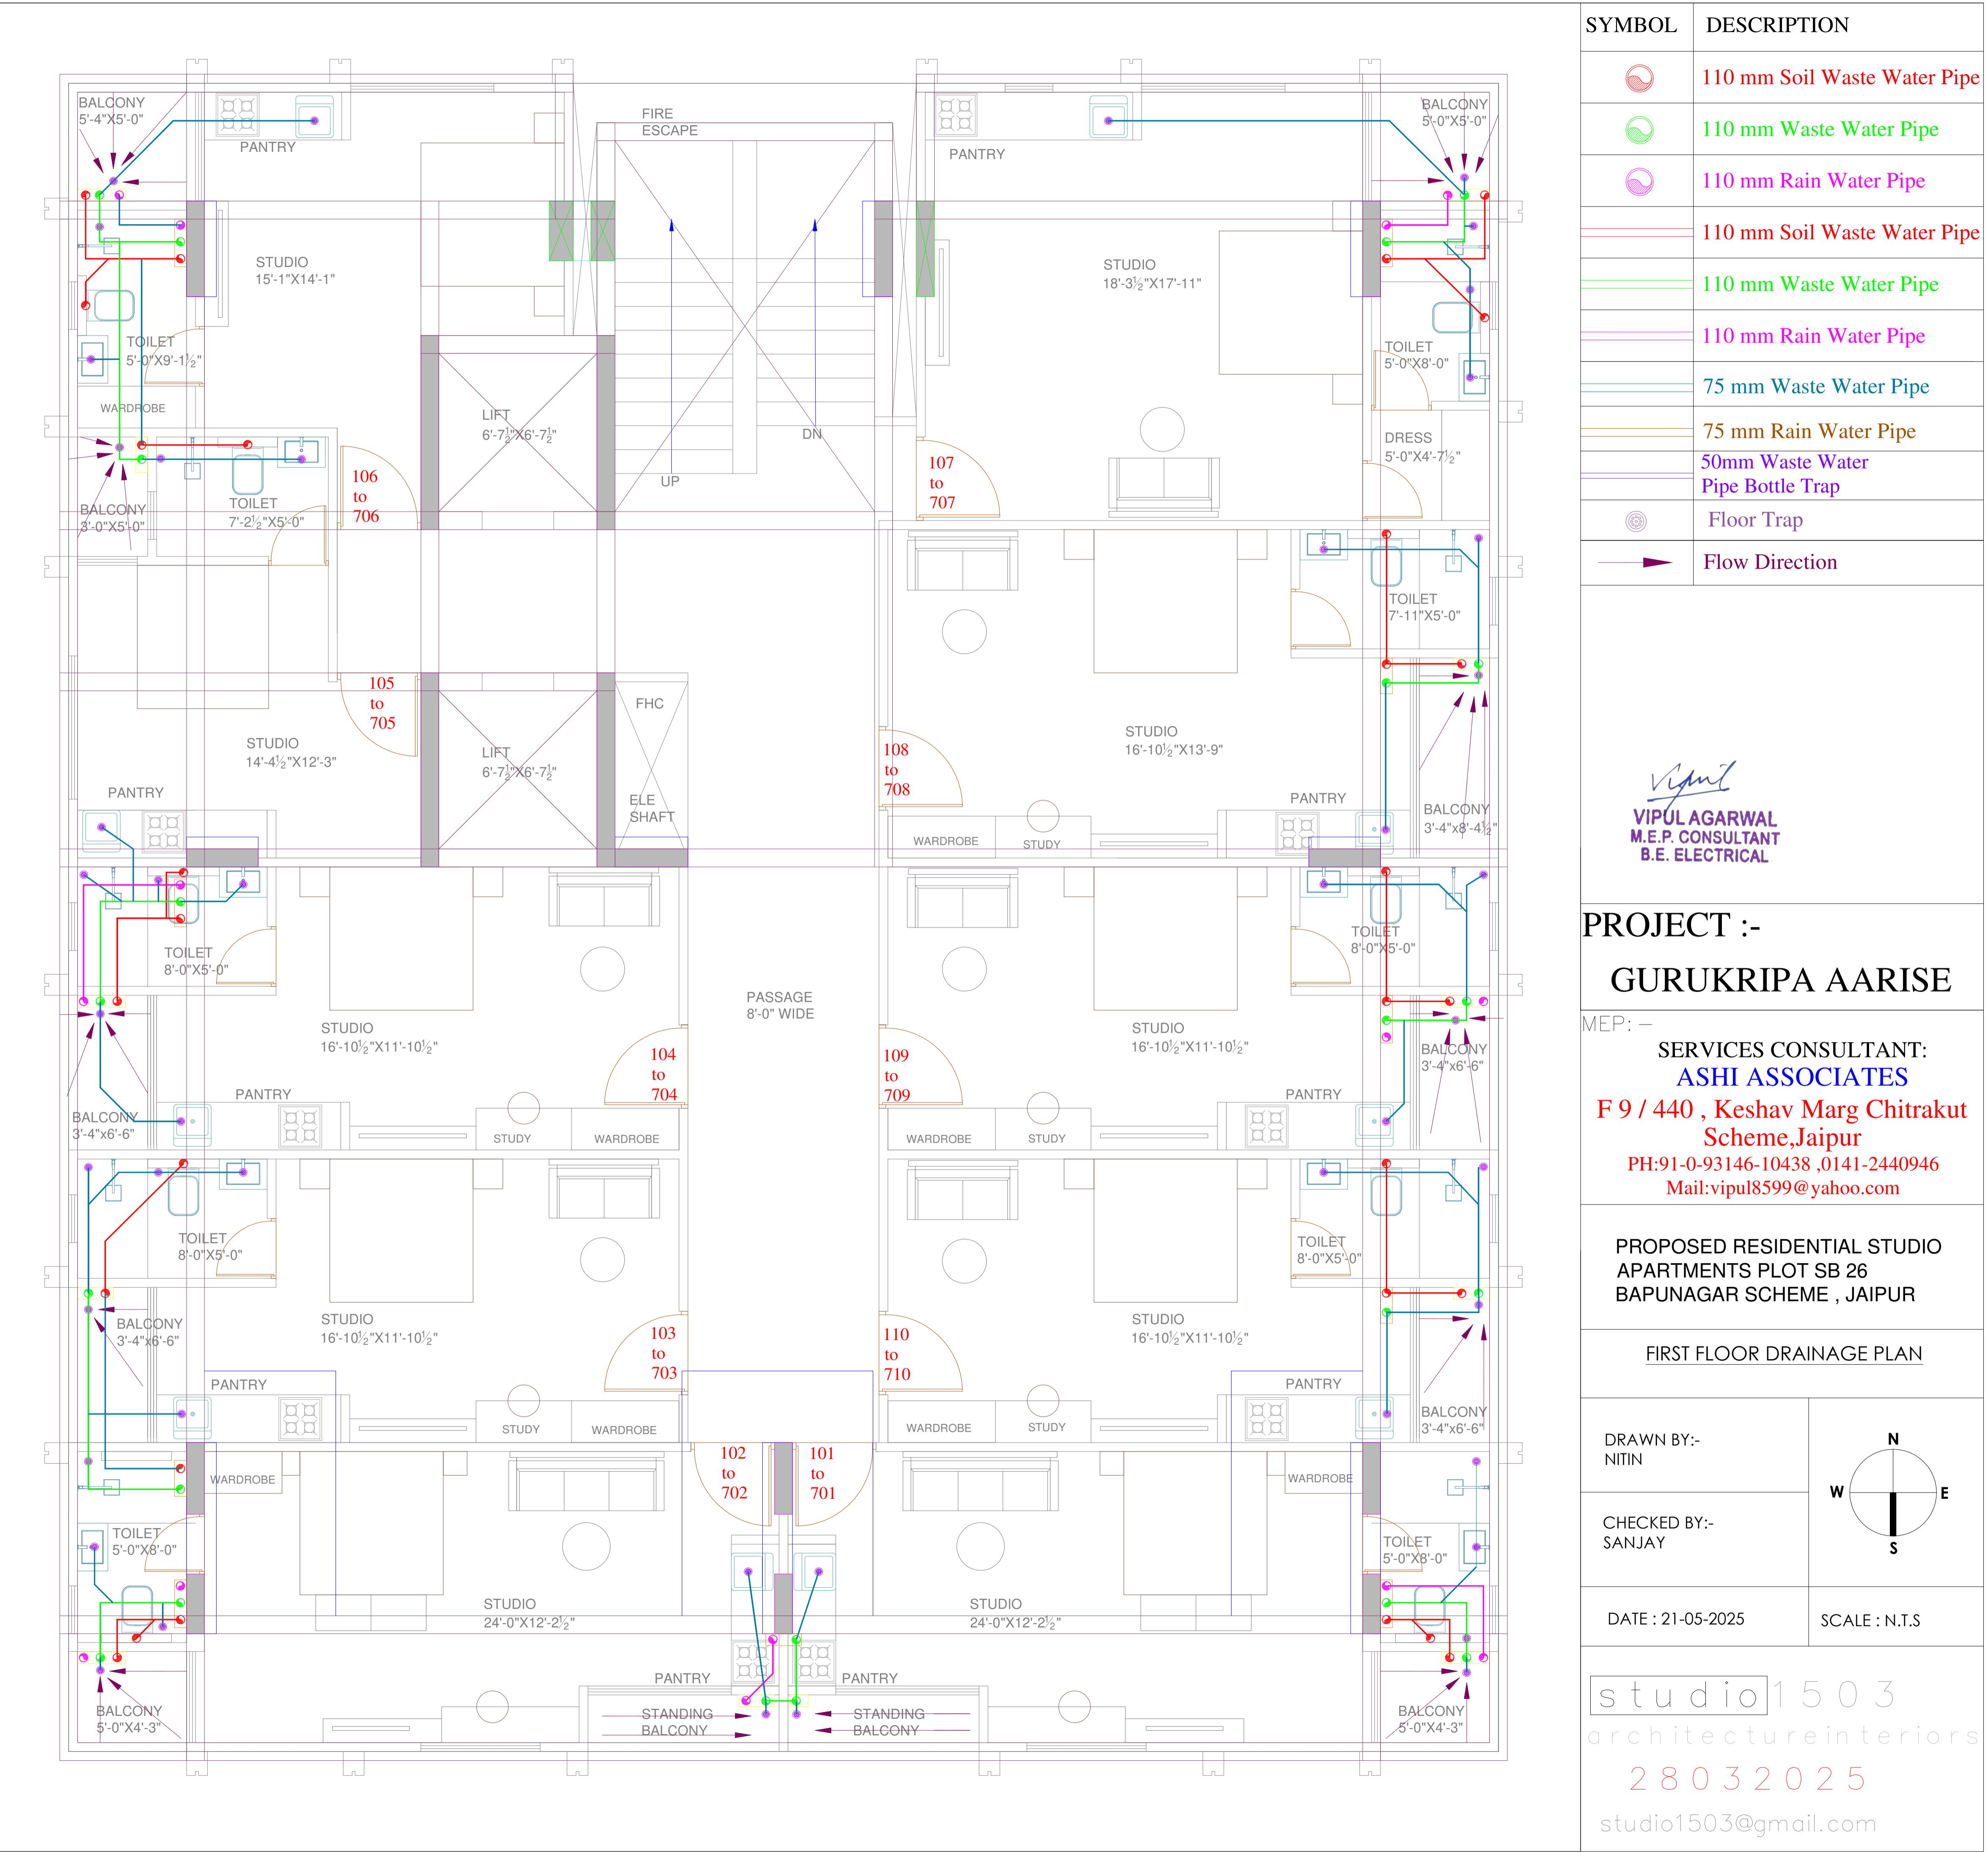

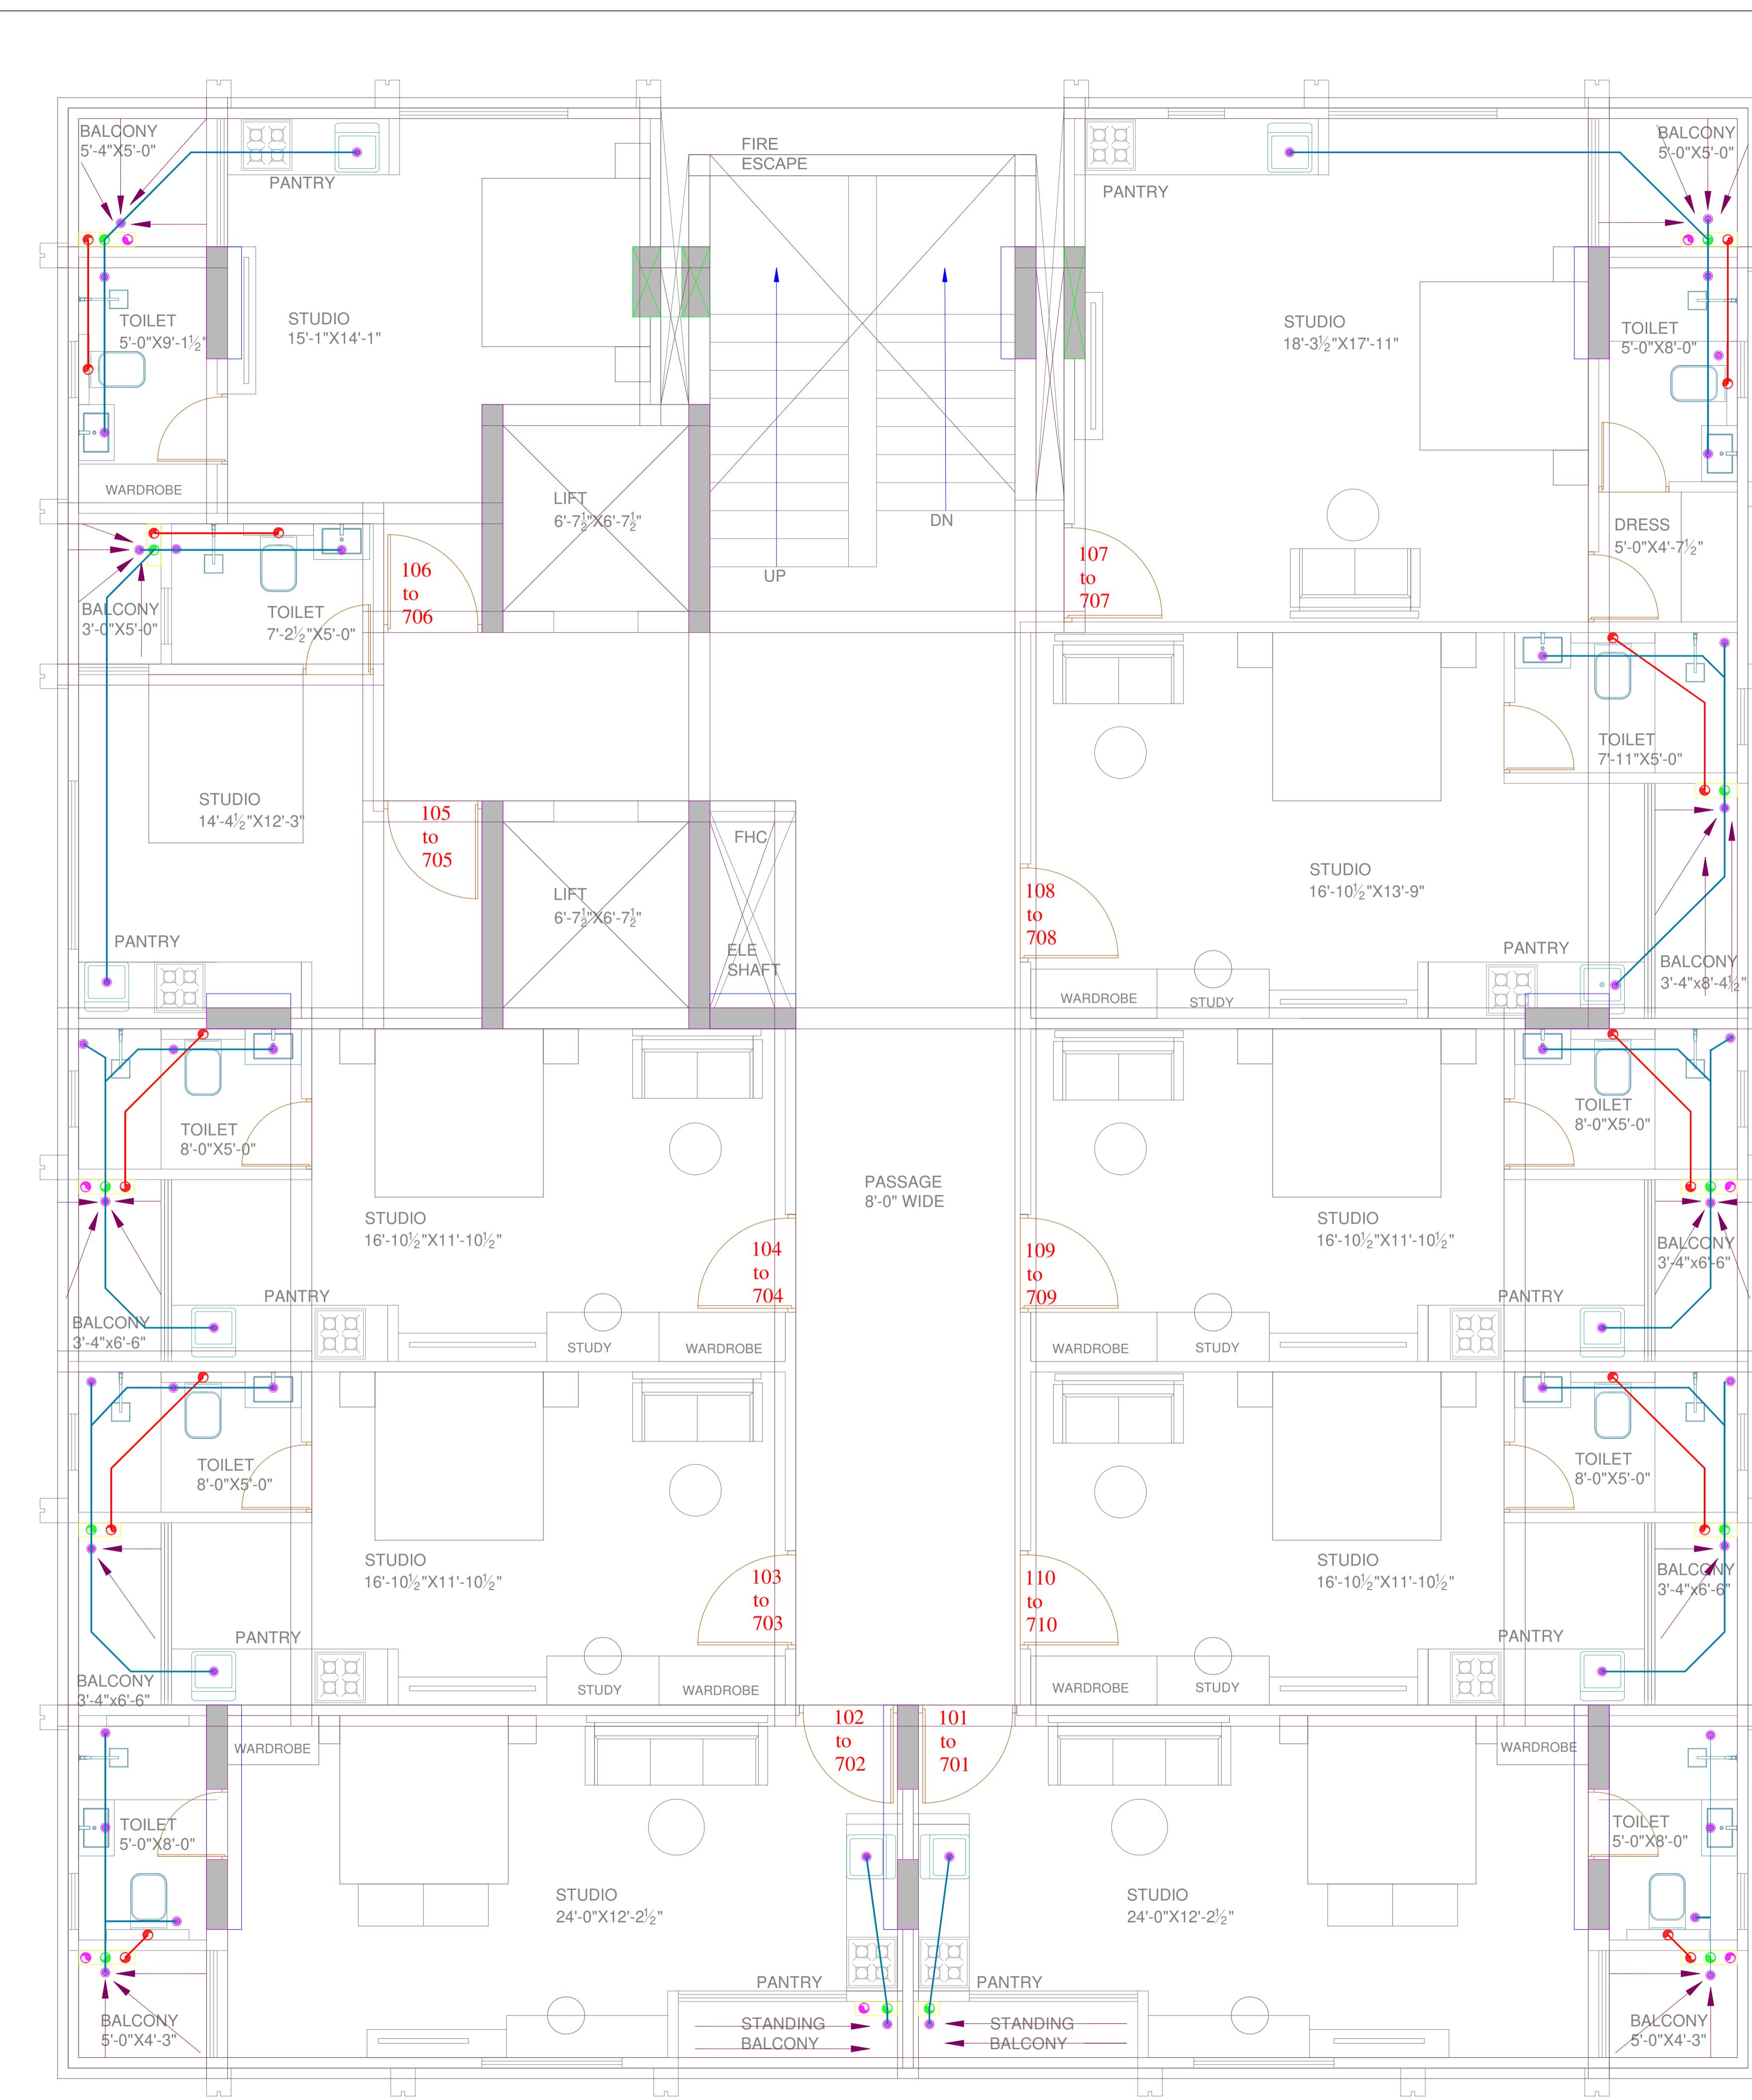

SYMBOL	DESCRIPTION
Red spiral	110 mm Soil Waste Water Pipe
Green spiral	110 mm Waste Water Pipe
Pink spiral	110 mm Rain Water Pipe
Red line	110 mm Soil Waste Water Pipe
Green line	110 mm Waste Water Pipe
Pink line	110 mm Rain Water Pipe
Blue line	75 mm Waste Water Pipe
Brown line	75 mm Rain Water Pipe
Orange line	50mm Waste Water Pipe
Purple circle	Pipe Bottle Trap
Blue circle with a dot	Floor Trap
Blue arrow	Flow Direction

Vipul

VIPUL AGARWAL
M.E.P. CONSULTANT
B.E. ELECTRICAL

PROJECT :-

GURUKRIPA AARISE


MEP:-

SERVICES CONSULTANT:
ASHI ASSOCIATES
F 9 / 440 , Keshav Marg Chitrakut
Scheme, Jaipur
PH:91-0-93146-10438 , 0141-2440946
Mail:vipul8599@yahoo.com

PROPOSED RESIDENTIAL STUDIO
APARTMENTS PLOT SB 26
BAPUNAGAR SCHEME , JAIPUR

SECOND TO EIGHTH FLOOR DRAINAGE PLAN

DRAWN BY:-
NITIN

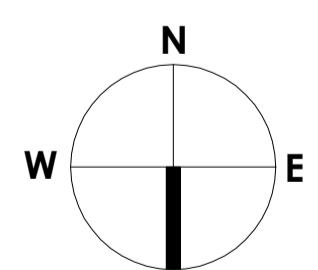

CHECKED BY:-
SANJAY

DATE : 21-05-2025

SCALE : N.T.S

studio1503
architectureinteriors
28032025
studio1503@gmail.com

SYMBOL	DESCRIPTION
	110 mm Soil Waste Water Pipe
	110 mm Waste Water Pipe
	110 mm Rain Water Pipe
	110 mm Soil Waste Water Pipe
	110 mm Waste Water Pipe
	110 mm Rain Water Pipe
	75 mm Waste Water Pipe
	75 mm Rain Water Pipe
	50mm Waste Water Pipe
	Pipe Bottle Trap
	Floor Trap
	Flow Direction

Vipul
VIPUL AGARWAL
M.E.P. CONSULTANT
B.E. ELECTRICAL

PROJECT :-
GURUKRIPA AARISE

MEP: -

SERVICES CONSULTANT:
ASHI ASSOCIATES
F 9 / 440 , Keshav Marg Chitrakut Scheme, Jaipur
PH:91-0-93146-10438 ,0141-2440946
Mail:vipul8599@yahoo.com

PROPOSED RESIDENTIAL STUDIO APARTMENTS PLOT SB 26 BAPUNAGAR SCHEME , JAIPUR

EIGHTH FLOOR ROOF DRAINAGE PIPE VENT PLAN

DRAWN BY:-
NITIN

CHECKED BY:-
SANJAY

DATE : 21-05-2025

SCALE : N.T.S

studio1503
architecture interiors
28032025
studio1503@gmail.com

