


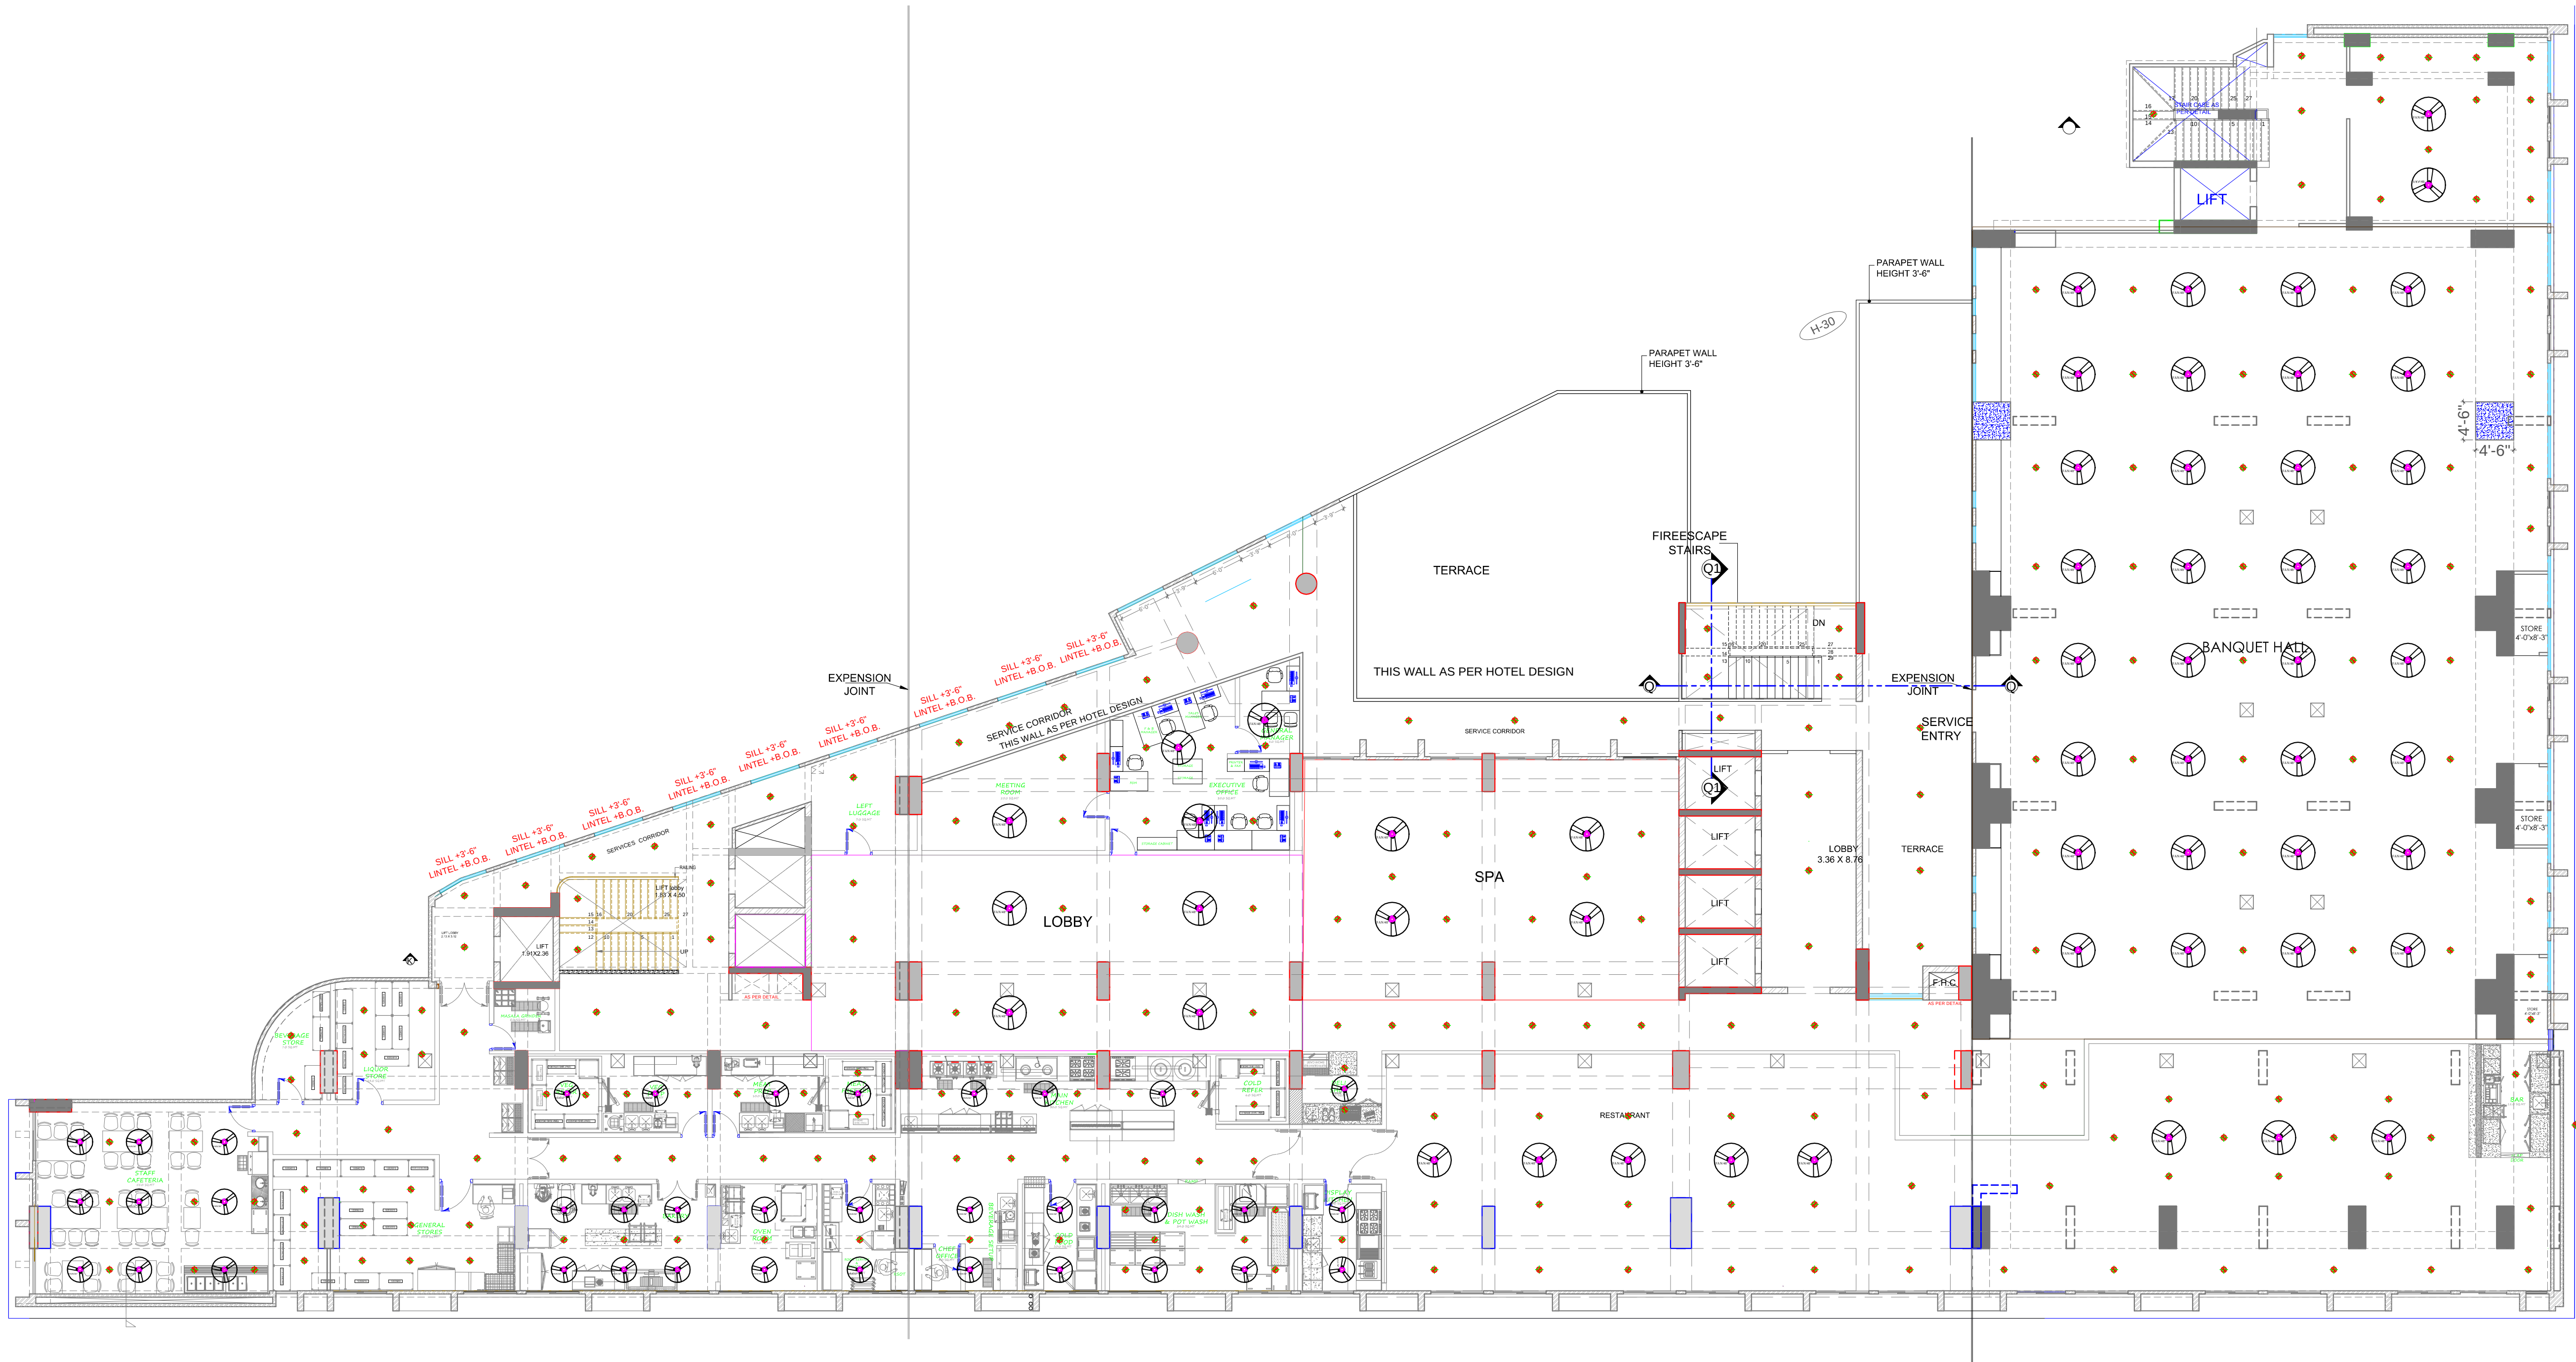

CLIENT :
**ANUKAMPA AVAS
VIKAS LLP**

ARCHITECTS :
des|gn
studio
GRAPHITE DESIGN STUDIO
ARCHITECTS, INTERIOR DESIGNERS, PLANNERS
68, Janak Puri -1st, Indrawati phatak, Opp Jain Mandir, Jaipur
CONTACT NO. +91-9928334414, 0141-2594414
email: studiosgraphite@gmail.com
Website : www.graphitedesignstudio.com

STRUCTURAL CONSULTANTS:

SERVICES CONSULTANTS:

VIPUL AGARWAL
M.E.P. CONSULTANT
B.E. ELECTRICAL

LEGENDS:				
Mounting Height	No.	I D	Symbol	Description
CEILING	54	FAN 48"		CEILING FAN 48"
CEILING	37	FAN 36"		CEILING FAN 36"
CEILING	254	DL		LED 6" DOWN LIGHTER 20W (SURFACE MOUNTED) MAKE : SYRA LED CAT NO. : SDL-15W GLD 6.5KGR

SERVICES CONSULTANT:
ASHI ASSOCIATES
F 9 / 440 , Keshav Marg Chitrakut Scheme,Jaipur
PH:91-0-93146-10438,0141-2440946 Mail:vipul8599@yahoo.com
REV. NO. 000 DATE: 10-06-2024

DRN BY:-	CKD BY:-	APPD.:-
RAJENDER	SANJAY	VIPUL AGARWAL

S.No	DATE	REVISION DESCRIPTION

GENERAL NOTES :
1. All dimensions on this drawing are in feet and inches.
2. Only written dimensions are to be followed. Drawing should not be scaled.
3. All measurements must be checked and verified by the contractor prior to execution of work at the site.
4. This drawing is to be read in conjunction with all relevant structural, services & facility planning drawings.
5. Architectural drawings are to be followed for the location of all structural members & masonry walls, for sizes & reinforcement details of structural members, relevant structural drawings are to be referred.
6. Any discrepancies between architectural, structural and services drawings must be brought to the notice of the architect immediately & prior to execution at site.
7. Co-ordinates with services such as basic, plumbing & electrical, etc. is the responsibility of the contractor.
8. All masonry walls should be aligned with the columns as indicated on the plan.
9. For details, refer relevant large scale detail drg. as indicated.

PROJECT: PROPOSED MIX USE BUILDING
PLOT NO. S-01, NEAR SHYAM
NAGAR, AJMER ROAD JAIPUR

NAME OF DRAWING:

**1ST FLOOR ELECTRIC
POINT MARKED PLAN**

DRAWN BY:	APPROVED BY:
RAJENDER	VIPUL AGARWAL

NORTH:

PROJECT NO. :	DATE :
302019ANUK00100	10-06-2024

SCALE :	REV NO. /DATE :
	REV NO. /DATE :14-05-2019 REV.COLUMN PB 2.17, CB-1.2.16 LOCATION

DRAWING NO. :	
ANU_A_03	

LEGENDS:

Mounting Height	No.	I D	Symbol	Description
CEILING	46	CH		CHANDELIER
CEILING	60	FAN		CEILING FAN
CEILING	88	DL		Led 6" Down Lighter 20W (Surface Mounted) Make:- Syska Led Cat no.:- SDL-15W GLD 6.5K/4K
CEILING	184	HL		HANGING LIGHT
CEILING	598	DL		CEILING LIGHT POINT
+90"	09	TL/W		Led Wall Tube Light Make:- Syska Led Cat no.:- SSK-TS-20W
+21"	59	FL		FLOOR LIGHT MAKE CAT NO:- ACTPTWL08
CEILING		CL		COVE LIGHT POINT
As Per Furniture		WRL		WARD ROBE LIGHT
+42"	203	SB		SWITCH BOARD
+24"	92	2WSB		2 WAY SWITCH BOARD (AT BED SIDE TABLE)
+24"/+42"		6A SC		6A SOCKET ON SWITCH BOARD
+24"		6A S		6A ONE WAY SWITCH
+24"/+42"		16A S		16A POWER SWITCH
+24"/+36"	92	TEL		TELEPHONE POINT FOR BED SIDE
+24"/+36"	92	LP TEL		6 A PLUG POINT FOR TELEPHONE
+42"	46	TV		TV COAXIAL POINT
+42"	92	LP TV		6 A PLUG POINT FOR TV
+24"	140	PC		DATA JACK FOR COMPUTER POINT
+24"/+42"	49	HDMI		HDMI PORT
+24"/+36"	233	LP		6 A PLUG POINT
+42"	46	LP		6 A PLUG POINT FOR TOILET
+72"	46	LP-CHL		6 A PLUG POINT FOR CHIMNEY
+24"	49	PP		16 A POWER POINT FOR STUDY TABLE
+42"	46	PP-MIX.		16 A POWER POINT FOR MIXER
+42"	46	PP-M		16 A POWER POINT FOR MINI BAR
+33"	46	PP-TK		16 A POWER POINT FOR TEA KETTLE
+78"	46	PP-WP		16 A POWER POINT FOR WATER PURIFIER
+78"	92	PP-G		16 A POWER POINT FOR GEYSER
+90"	51	PP-SAC		250W POWER POINT FOR SPLIT AC
+24"	51	AC		AC STARTER
+90"	51	SAC		SPLIT AC INDOOR UNIT
+42"	46	MDB		MAKE MY ROOM, DO NOT DISTURB & BELL PUSH
+42"	46	BZ		BUZZER POINT
+42"	46	KT		KEY TAG FOR ROOMS
+60"	46	R DB		ROOMS MCB DISTRIBUTION BOARD

CLIENT :- ANUKAMPA AVAS VIKAS LLP

PROJECT :- PROPOSED MIX USE BUILDING
PLOT NO. S-01, NEAR SHYAM NAGAR,
AJMER ROAD JAIPUR

DRAWING TYPE :-

2nd & 3rd FLOOR ELECTRIC
POINT MARKING PLAN

DRN. By: MAHENDRA

CHECK. By: SANJAY

DATE: 08-06-2024

SERVICES CONSULTANT:

ASHI ASSOCIATES

F 9 / 440 , Keshav Marg Chitrakut Scheme,Jaipur
PH:91-0-93146-10438 ,0141-2440946
Mail:vipul8599@yahoo.com

ARCHITECT :-
desig studio

GRAPHITE DESIGN STUDIO
ARCHITECTS, INTERIOR DESIGNERS, PLANNERS

68, Janak Puri -1st, Imliwala phatak, Opp Jain Mandir, Jaipur
CONTACT NO. +91-9928334414, 0141-2594414
email: studiographite@gmail.com
Website: www.graphitedesignstudio.com

LEGENDS:

Mounting Height	No.	I D	Symbol	Description
CEILING	52	CHI		CHANDELIER
CEILING	52	FAN		CEILING FAN
CEILING	52	HL		HANGING LIGHT
CEILING	65	DL		Led 6" Down Lighter 20W (Surface Mounted) Make:- Syska Led Cat no.:- SDL-15W GLD 6.5K/4K
CEILING	208	HL		HANGING LIGHT
CEILING	676	DL		CEILING LIGHT POINT
+21"	52	FL		FOOT LIGHT RABTREE MAKE CAT NO.:- ACTPTW108
CEILING		CL		COVE LIGHT POINT
As Per Furniture		WRL		WARD ROBE LIGHT
+42"	218	SB		SWITCH BOARD
+24"	105	2WSB		2 WAY SWITCH BOARD (AT BED SIDE TABLE)
+24"/+42"		6A SC		6A SOCKET ON SWITCH BOARD
+24"		6A S		6A ONE WAY SWITCH
+24"/+42"		16A S		16A POWER SWITCH
+24"/+36"	104	TEL		TELEPHONE POINT FOR BED SIDE
+24"/+36"	104	LP TEL		6 A PLUG POINT FOR TELEPHONE
+42"	52	TV		TV COAXIAL POINT
+42"	104	LP TV		6 A PLUG POINT FOR TV
+24"	104	PC		DATA JACK FOR COMPUTER POINT
+24"/+42"	104	HDMI		HDMI PORT
+24"/+36"	251	LP		6 A PLUG POINT
+42"	52	LP		6 A PLUG POINT FOR TOILET
+72"	52	LP-CHI		6 A PLUG POINT FOR CHIMNEY
+24"	52	PP		16 A POWER POINT FOR STUDY TABLE
+42"	52	PP-MIX		16 A POWER POINT FOR MIXER
+42"	52	PP-M		16 A POWER POINT FOR MINI BAR
+33"	52	PP-TK		16 A POWER POINT FOR TEA KETTLE
+78"	52	PP-WP		16 A POWER POINT FOR WATER PURIFIER
+78"	104	PP-G		16 A POWER POINT FOR GEYSER
+90"	52	PP-SAC		250W POWER POINT FOR SPLIT AC
+24"	52	AC		AC STARTER
+90"	52	SAC		SPLIT AC INDOOR UNIT
+42"	52	MDB		MAKE MY ROOM, DO NOT DISTURB & BELL PUSH
+42"	52	BZ		BUZZER POINT
+42"	52	KT		KEY TAG FOR ROOMS
+60"	52	R DB		ROOMS MCB DISTRIBUTION BOARD

CLIENT :- ANUKAMPA AVAS VIKAS LLP

PROJECT :- PROPOSED MIX USE BUILDING
PLOT NO. S-01, NEAR SHYAM NAGAR,
AJMER ROAD JAIPUR

DRAWING TYPE :-

4th & 10th FLOOR ELECTRIC
POINT MARKING PLAN

DRN. By: MAHENDRA

CHECK. By: SANJAY

DATE: 08-06-2024

SERVICES CONSULTANT:

ASHI ASSOCIATES


F 9 / 440 , Keshav Marg Chitrakut Scheme,Jaipur
PH:91-0-93146-10438 ,0141-2440946
Mail:vipul8599@yahoo.com

ARCHITECT :-

des|gn
studio

GRAPHITE DESIGN STUDIO
ARCHITECTS, INTERIOR DESIGNERS, PLANNERS

68, Janak Puri -1st, Imliwala phatak, Opp Jain Mandir, Jaipur
CONTACT NO. +91-9928334414, 0141-2594414
email: studiosgraphite@gmail.com
Website : www.graphitedesignstudio.com

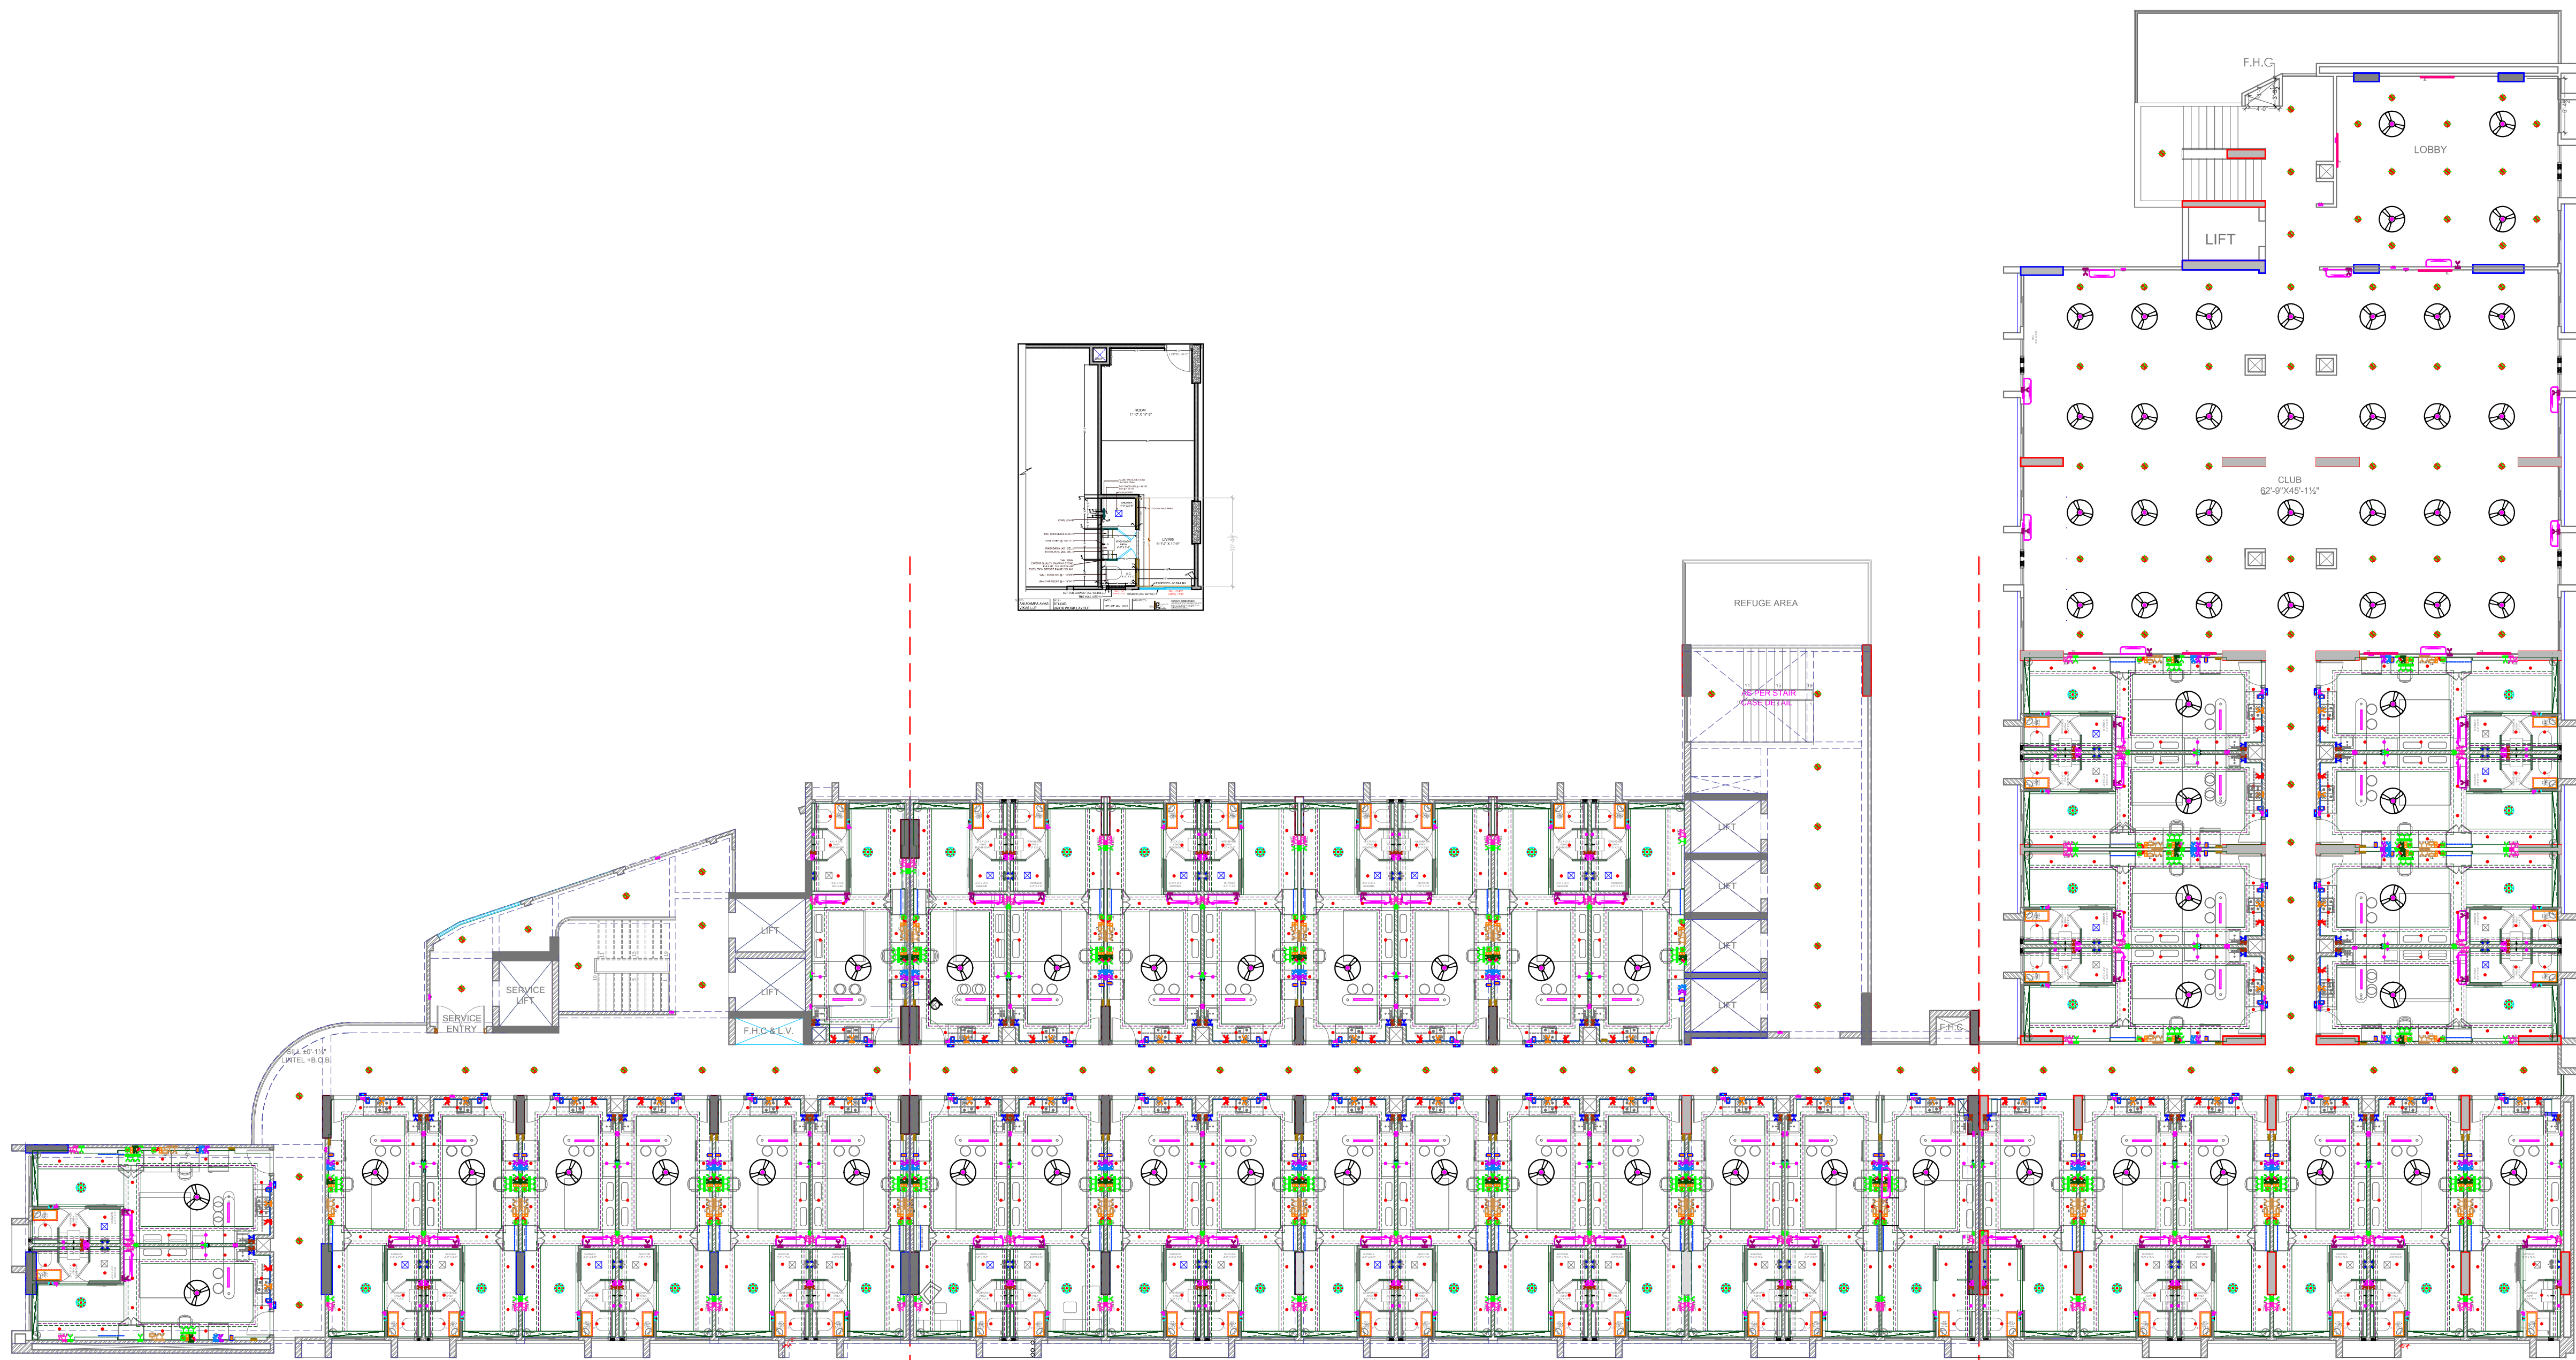

11th FLOOR WORKING PLAN

Vipul
VIPUL AGARWAL
M.E.P. CONSULTANT
B.E. ELECTRICAL

LEGENDS:				
Mounting Height	No.	I D	Symbol	Description
CEILING	42	CHI		CHANDELIER
CEILING	74	FAN		CEILING FAN
CEILING	42	HL		HANGING LIGHT
CEILING	106	DL		Led 6" Down Lighter 20W (Surface Mounted) Make:- Syska Led Cat no:- SDL-15W GLD 6.5K/4K
CEILING	168	HL		HANGING LIGHT
CEILING	546	DL		CEILING LIGHT POINT
+90"	08	TL/W		Led Wall Tube Light Make:- Syska Led Cat no:- SSK-15-20W
+21"	42	FL		FOOT LIGHT MAKE CAT NO:- ACTPFWL08
CEILING		CL		COVE LIGHT POINT
As Per Furniture		WRL		WARD ROBE LIGHT
+42"	189	SB		SWITCH BOARD
+24"	84	2WSB		2 WAY SWITCH BOARD (AT BED SIDE TABLE)
+24"/+42"		6A SC		6A SOCKET ON SWITCH BOARD
+24"		6A S		6A ONE WAY SWITCH
+24"/+42"		16A S		16A POWER SWITCH
+24"/+36"	84	TEL		TELEPHONE POINT FOR BED SIDE
+24"/+36"	84	LP TEL		6 A PLUG POINT FOR TELEPHONE
+42"	42	TV		TV COAXIAL POINT
+42"	84	LP TV		6 A PLUG POINT FOR TV
+24"	84	PC		DATA JACK FOR COMPUTER POINT
+24"/+42"	84	HDMI		HDMI PORT
+24"/+36"	201	LP		6 A PLUG POINT
+42"	42	LP		6 A PLUG POINT FOR TOILET
+72"	42	LP-CHL		6 A PLUG POINT FOR CHIMNEY
+24"	42	PP		16 A POWER POINT FOR STUDY TABLE
+42"	42	PP-MIX		16 A POWER POINT FOR MIXER
+42"	42	PP-M		16 A POWER POINT FOR MINI BAR
+33"	42	PP-TK		16 A POWER POINT FOR TEA KETTLE
+78"	42	PP-WP		16 A POWER POINT FOR WATER PURIFIER
+78"	84	PP-G		16 A POWER POINT FOR GEYSER
+90"	51	PP-SAC		250W POWER POINT FOR SPLIT AC
+24"	51	AC		AC STARTER
+90"	51	SAC		SPLIT AC INDOOR UNIT
+42"	42	MDB		MAKE MY ROOM, DO NOT DISTURB & BELL PUSH
+42"	42	BZ		BLUZZER POINT
+42"	42	KT		KEY TAG FOR ROOMS
+60"	42	R DB		ROOMS MCB DISTRIBUTION BOARD

CLIENT :- ANUKAMPA AVAS VIKAS LLP

PROJECT :- PROPOSED MIX USE BUILDING
PLOT NO. S-01, NEAR SHYAM NAGAR,
AJMER ROAD JAIPUR

DRAWING TYPE :-

11th FLOOR ELECTRIC POINT
MARKING PLAN


DRN. By: MAHENDRA


CHECK. By: SANJAY

DATE: 08-06-2024


SERVICES CONSULTANT:
ASHI ASSOCIATES
F 9 / 440 , Keshav Marg Chitrakut Scheme,Jaipur
PH:91-0-93146-10438 ,0141-2440946
Mail:vipul8599@yahoo.com

ARCHITECT :-
graphite
des|gn studio
GRAPHITE DESIGN STUDIO
ARCHITECTS, INTERIOR DESIGNERS, PLANNERS
68, Janak Puri -1st, milwala phatak, Opp Jain Mandir, Jaipur
CONTACT NO. +91-9928334414, 0141-2594414
email: studiosgraphite@gmail.com
Website : www.graphitedesignstudio.com

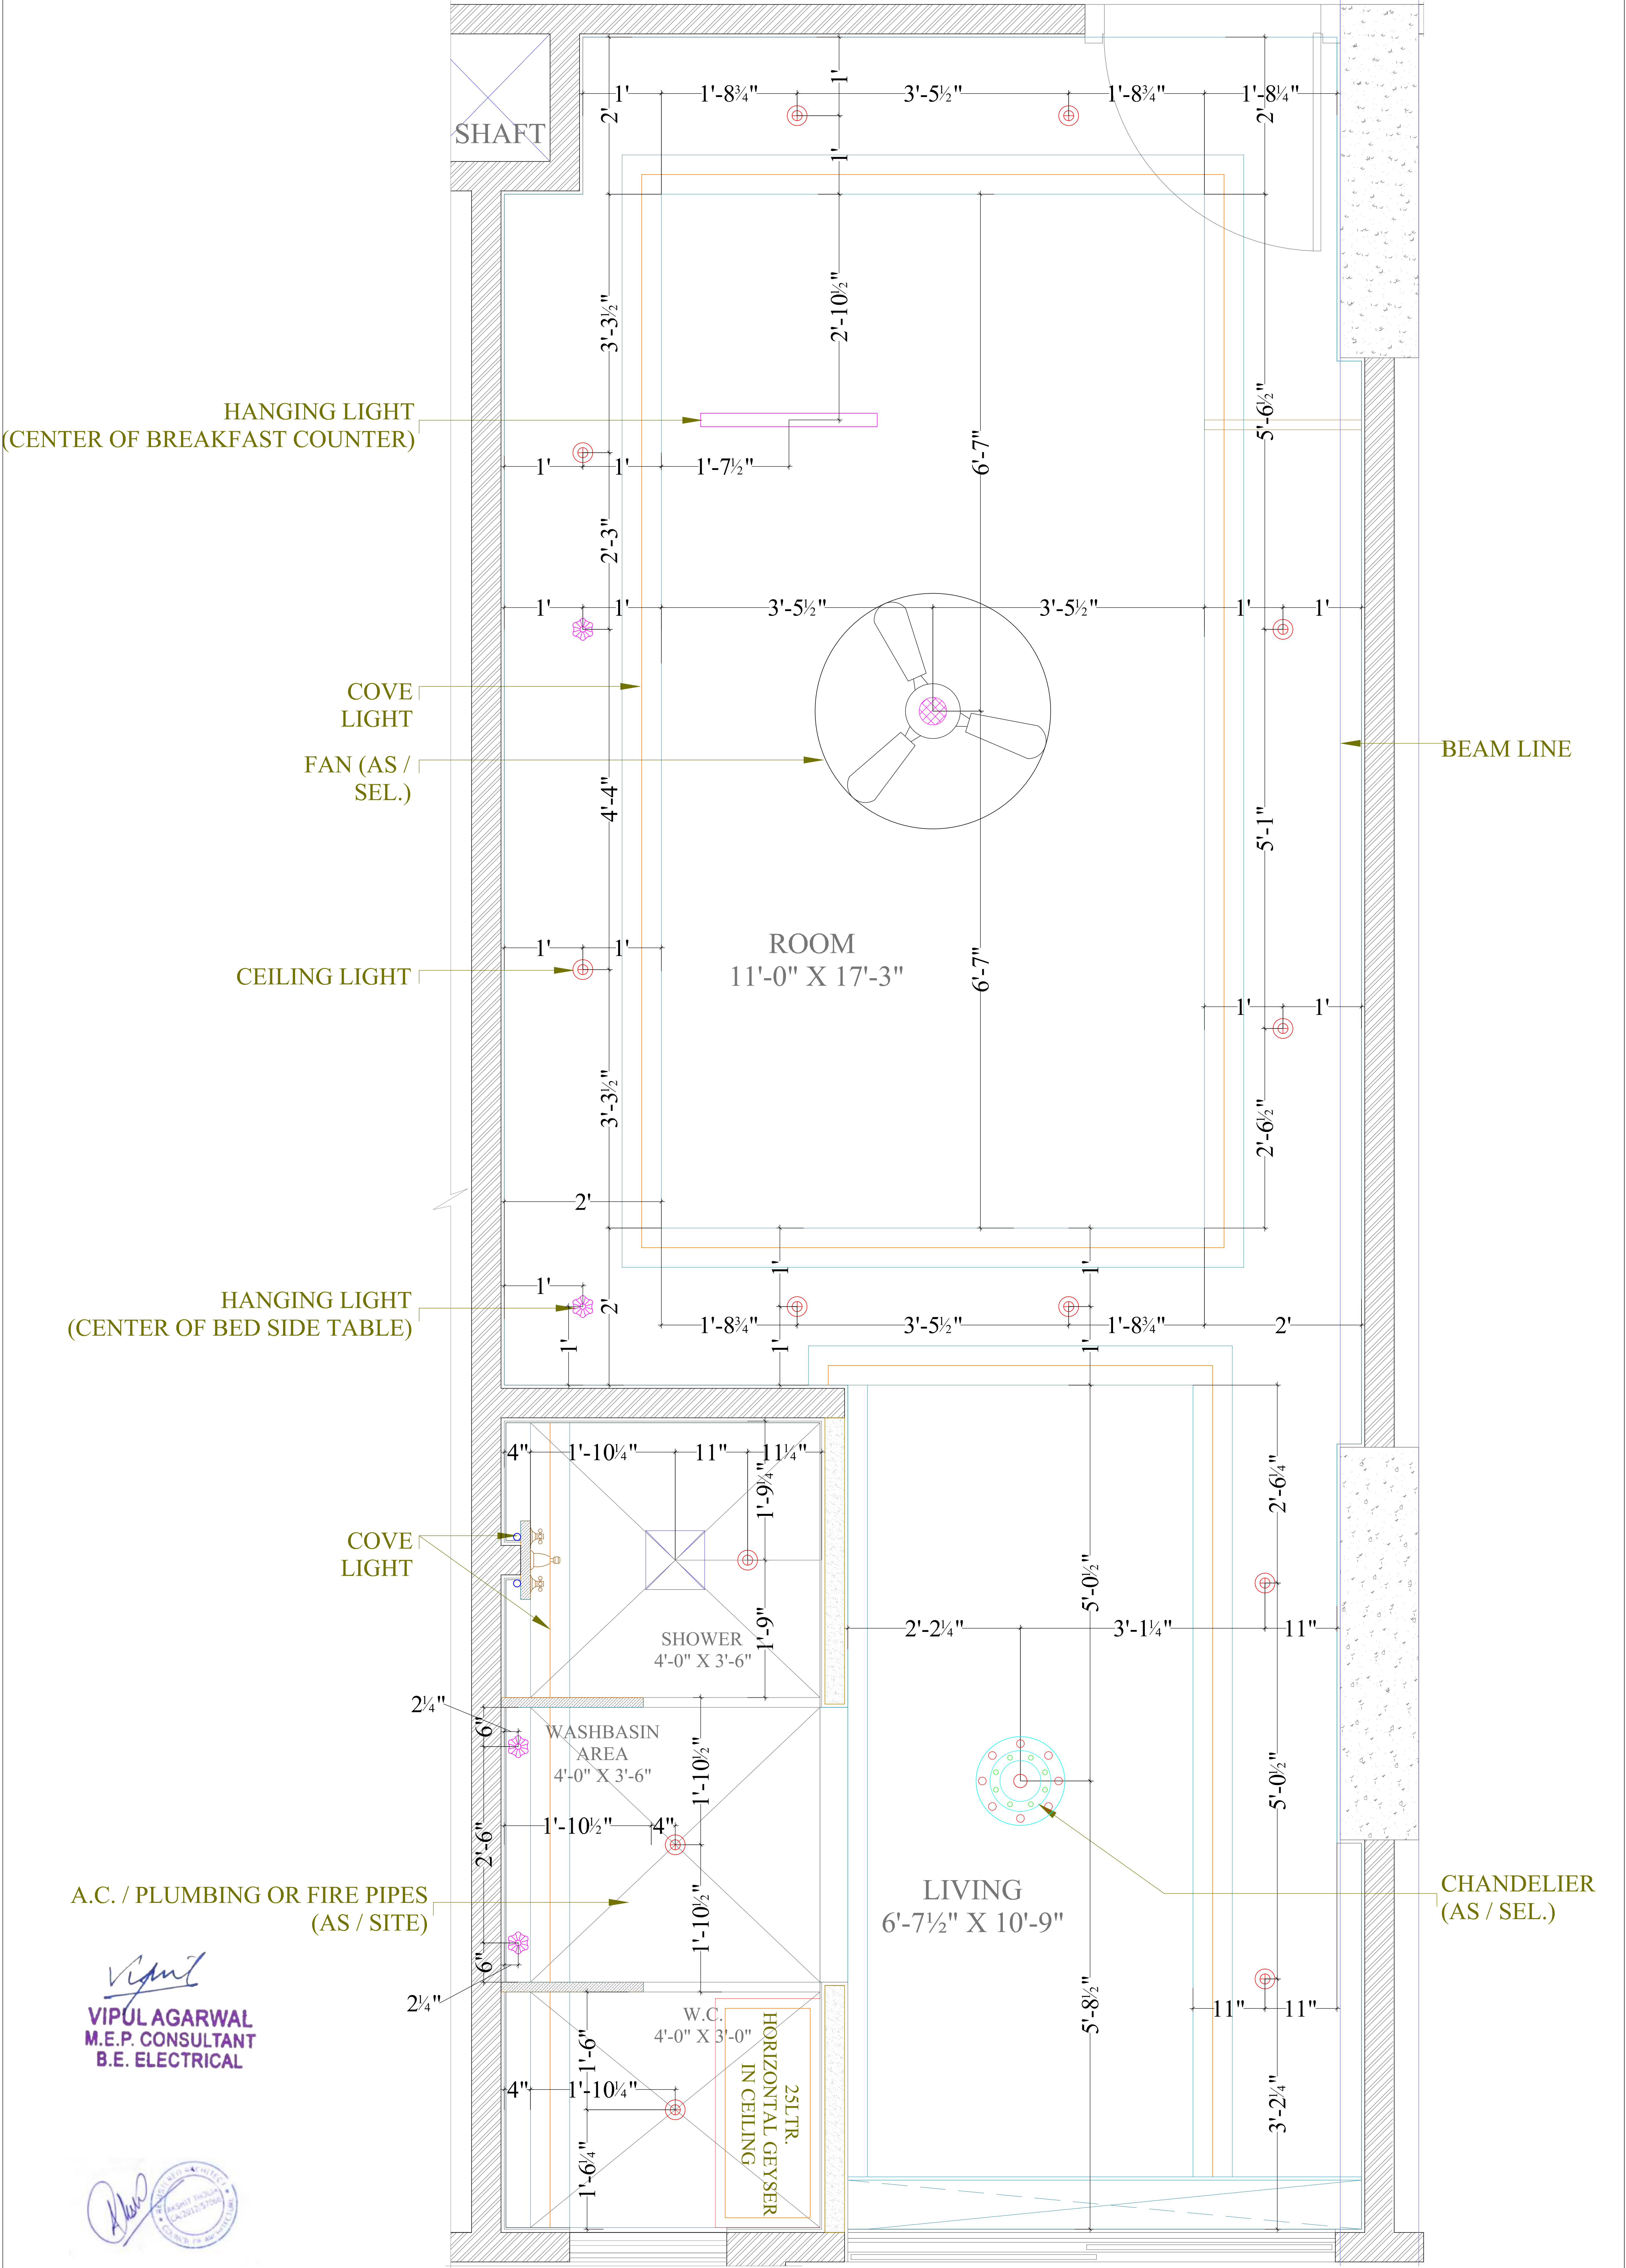


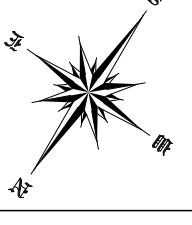CLIENT :	PROJECT:	ARCHITECTS :	NAME OF DRAWING:	DRAWN BY:	PROJECT NO. :	NORTH:	SERVICES CONSULTANT:
ANUKAMPA AVAS VIKAS LLP	PROPOSED MIX USE BUILDING PLOT NO. S-01, NEAR SHYAM NAGAR, AJMER ROAD JAIPUR	 GRAPHITE DESIGN STUDIO ARCHITECTS, INTERIOR DESIGNERS, PLANNERS B8, Janak Puri -1st, Indrawala phatak, Opp. Jain Mandir, Jaipur CONTACT NO. +91-9928334414, 0141-2593414 email: studiosgraphite@gmail.com Website: www.graphitedesignstudio.com	TYPICAL STUDIO UNIT ELECTRIC CEILING POINT DIMENSION PLAN	PAWAN SANJAY	302019ANUK00100 SCALE :	 DRAWING NO. :	VIPUL CONSULTING, F 9 / 440 , Keshav Marg Chitrakut Scheme,Jaipur PH:91-0-93146-10438 ,0141-2440946 Mail:vipul8599@yahoo.com
				APPROVED BY: VIPUL AGARWAL	DATE : 22-02-2020	REV.: 00	ECPD-01

12 WAY SPN DB

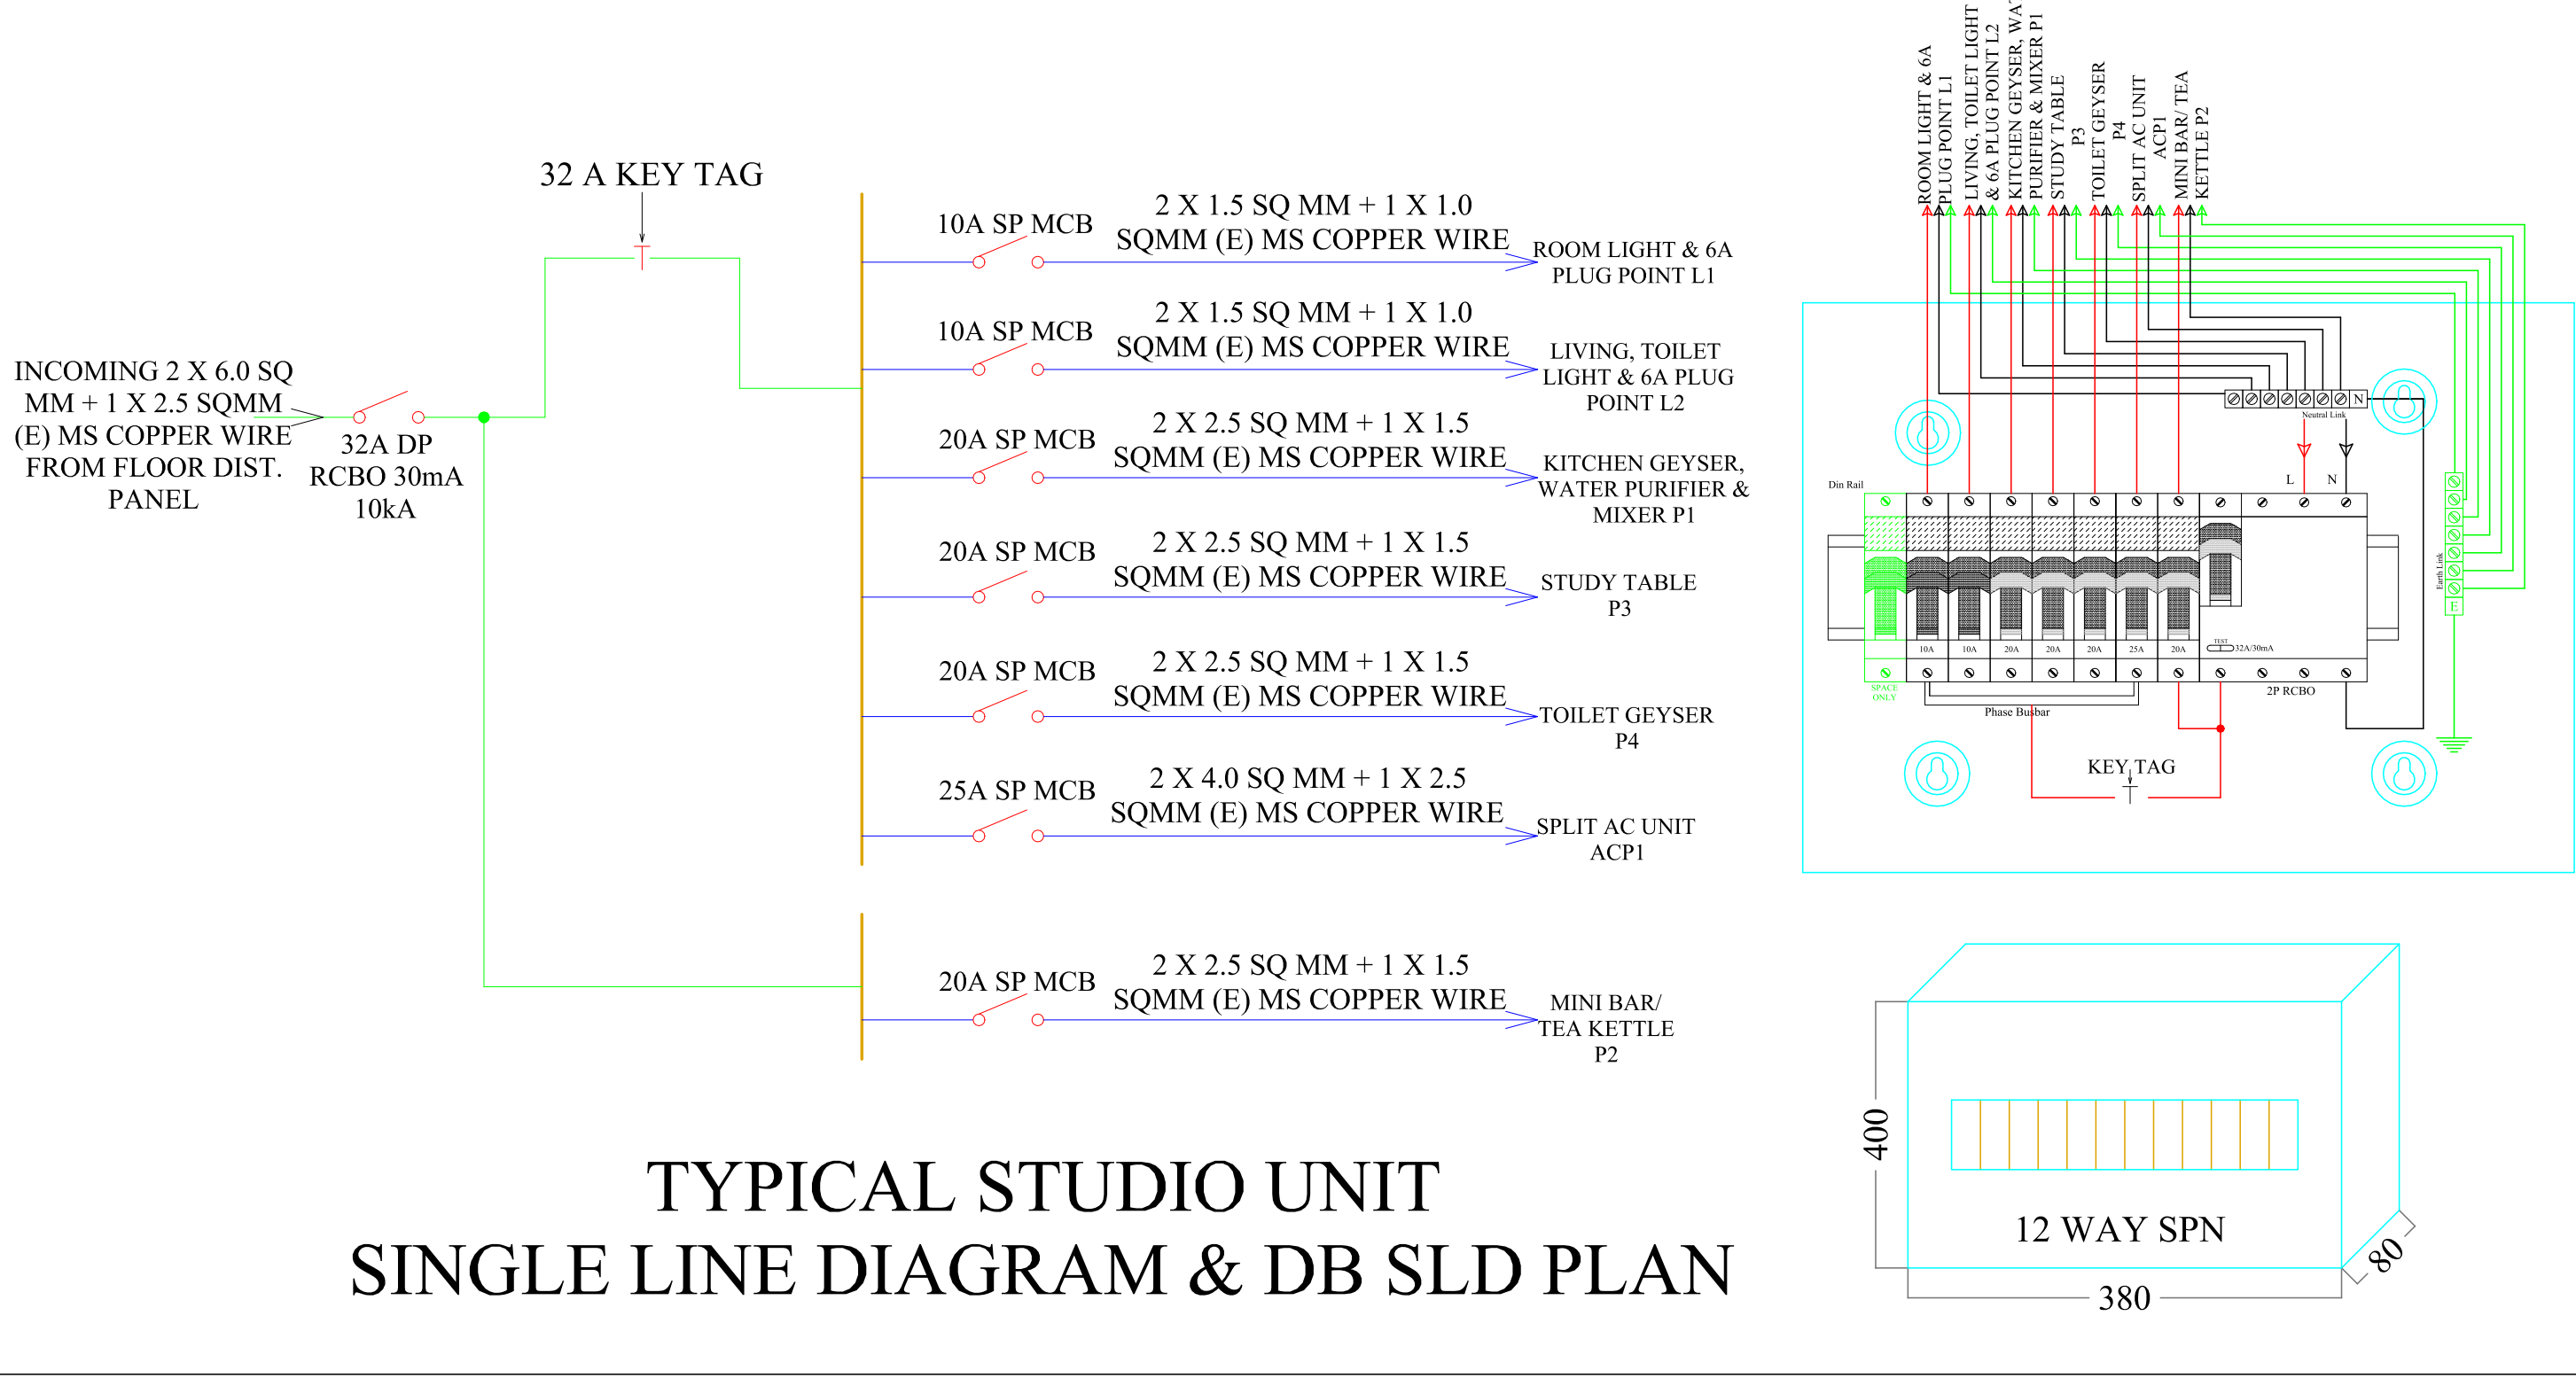

TYPICAL STUDIO UNIT
SINGLE LINE DIAGRAM & DB SLD PLAN

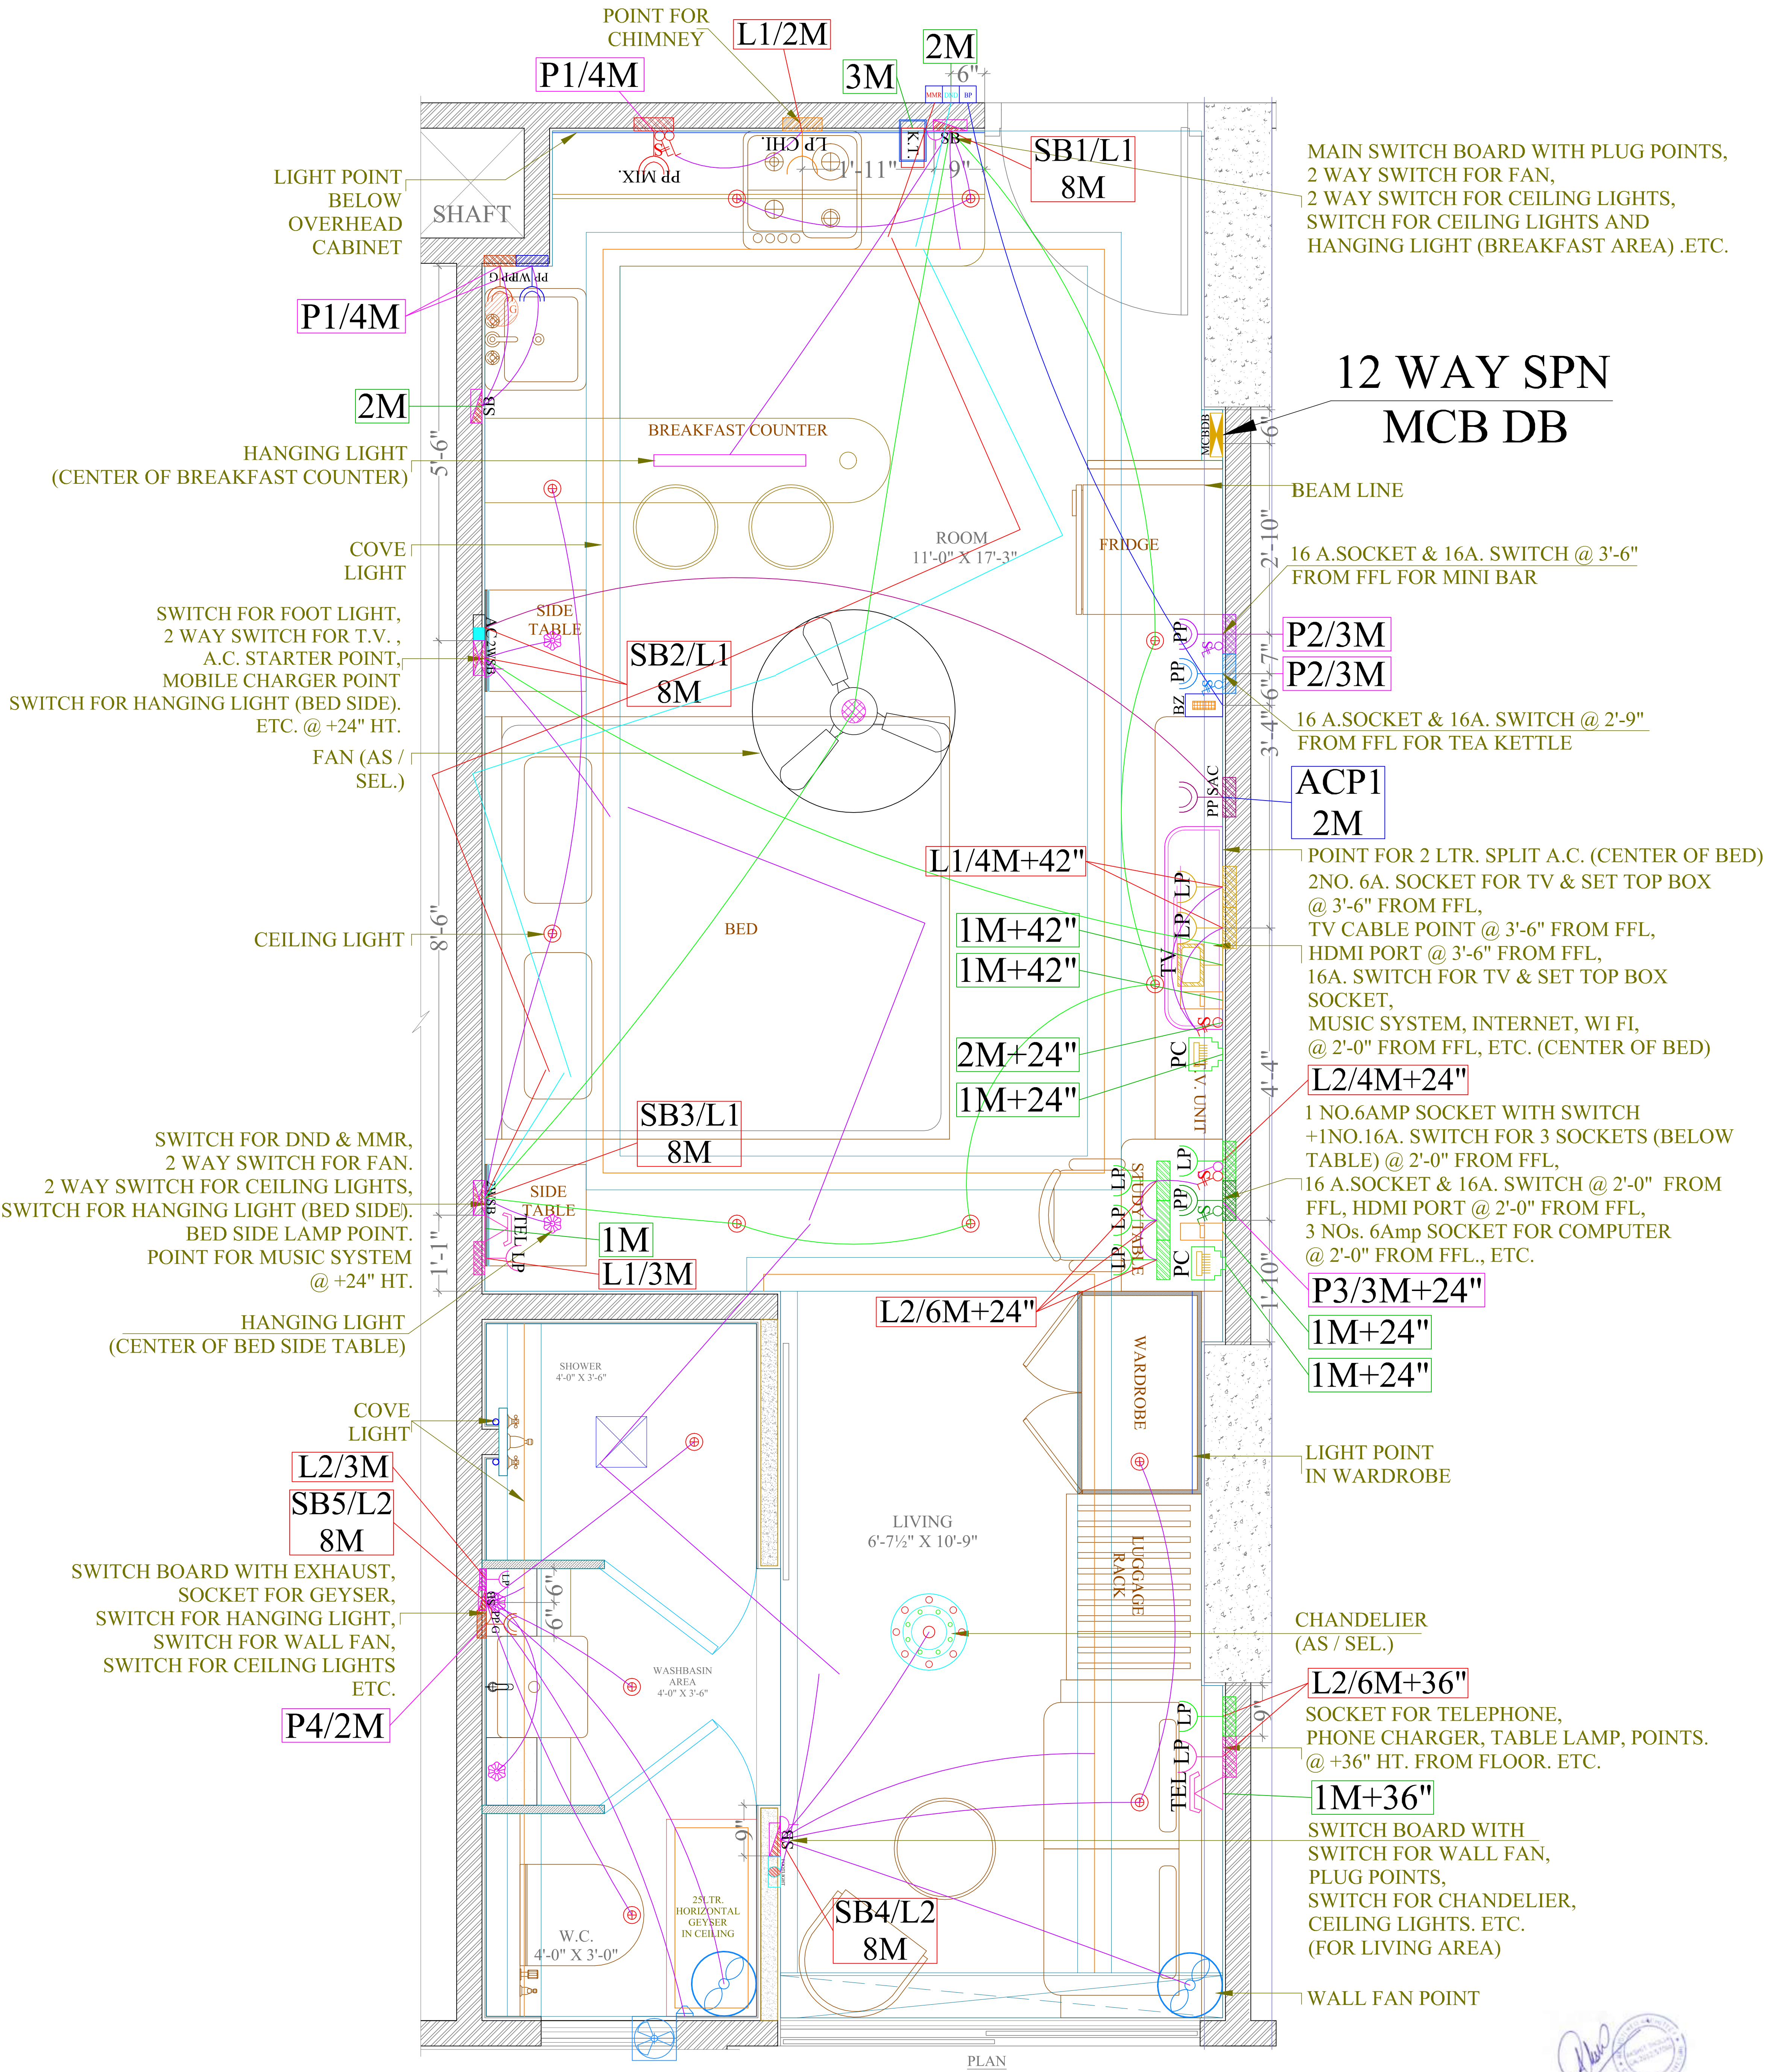


VIPUL AGARWAL
M.E.P. CONSULTANT
B.E. ELECTRICAL

LEGENDS:

Mounting Height	No.	I D	Symbol	Description
IN CONDUIT		WIRE		CONTROL WIRING FOR 2 WAY LIGHT POINT
IN CONDUIT		WIRE		CONTROL WIRING FOR LIGHT POINT
IN CONDUIT		WIRE		CONTROL WIRING FOR BELL PUSH
IN CONDUIT		WIRE		CONTROL WIRING FOR MMR POINT
IN CONDUIT		WIRE		CONTROL WIRING FOR DND POINT
IN CONDUIT		WIRE		CONTROL WIRING FOR GEYSER
CEILING	01	CHI		CHANDELIER
CEILING	01	FAN		CEILING FAN
CEILING	01	HL		HANGING LIGHT
CEILING	04	HL		HANGING LIGHT
CEILING	13	DL		CEILING LIGHT POINT
+21"	01	FL		FOOT LIGHT RABTREE MAKE CAT NO.- ACTPFWL08
CEILING		CL		COVE LIGHT POINT
As Per Furniture		WRL		WARD ROBE LIGHT
+42"	04	SB		SWITCH BOARD
+24"	02	2WSB		2 WAY SWITCH BOARD (AT BED SIDE TABLE)
+24"/+42"		6A SC		6A SOCKET ON SWITCH BOARD
+24"		6A S		6A ONE WAY SWITCH
+24"/+42"		16A S		16A POWER SWITCH
+24"/+36"	02	TEL		TELEPHONE POINT FOR BED SIDE
+24"/+36"	02	LP TEL		6 A PLUG POINT FOR TELEPHONE
+42"	01	TV		TV COAXIAL POINT
+42"	02	LP TV		6 A PLUG POINT FOR TV
+24"	02	PC		DATA JACK FOR COMPUTER POINT
+24"/+42"	02	HDMI		HDMI PORT
+24"/+36"	05	LP		6 A PLUG POINT
+42"	01	LP		6 A PLUG POINT FOR TOILET
+72"	01	LP-CHI		6 A PLUG POINT FOR CHIMNEY
+24"	01	PP		16 A POWER POINT FOR STUDY TABLE
+42"	01	PP-MIX.		16 A POWER POINT FOR MIXER
+42"	01	PP-M		16 A POWER POINT FOR MINI BAR
+33"	01	PP-TK		16 A POWER POINT FOR TEA KETTLE
+78"	01	PP-WP		16 A POWER POINT FOR WATER PURIFIER
+78"	02	PP-G		16 A POWER POINT FOR GEYSER
+90"	01	PP-SAC		25POWER POINT FOR SPLIT AC
+24"	01	AC		AC STARTER
+90"	01	SAC		SPLIT AC INDOOR UNIT
+42"	01	MDB		MAKE MY ROOM, DO NOT DISTURB & BELL PUSH
+42"	01	BZ		BUZZER POINT
+42"	01	KT		KEY TAG FOR ROOMS
+60"	01	R DB		ROOMS MCB DISTRIBUTION BOARD
	02			SWITCH BOARD NO./ LIGHT CIRCUIT NO./MODULAR NO.
	04			POWER CIRCUIT NO./ MODULAR NO.
	01			AC POWER CIRCUIT NO.
				MODULAR NO.

CLIENT :	PROJECT:	ARCHITECTS :	NAME OF DRAWING:	DRAWN BY:	PROJECT NO. :	NORTH:	SERVICES CONSULTANT:
ANUKAMPA AVAS VIKAS LLP	PROPOSED MIX USE BUILDING PLOT NO. S-01, NEAR SHYAM NAGAR, AJMER ROAD JAIPUR	des ^{ig} n studio GRAPHITE DESIGN STUDIO ARCHITECTS, INTERIOR DESIGNERS, PLANNERS 68, Janak Puri -1st, Imliwala phatak, Opp Jain Mandir, Jaipur CONTACT NO. +91-9928334414, 0141-2593414 email: studiographite@gmail.com Website : www.graphitedesignstudio.com	TYPICAL STUDIO UNIT ELECTRIC CONTROL WIRING & DB SLD PLAN	PAWAN SANJAY VIPUL AGARWAL	302019ANUK00100 SCALE : DATE : REV.:	 DRAWING NO. : ECW-02	VIPUL CONSULTING, F 9 / 440 , Keshav Marg Chitrakut Scheme,Jaipur PH:91-0-93146-10438 ,0141-2440946 Mail:vipul8599@yahoo.com

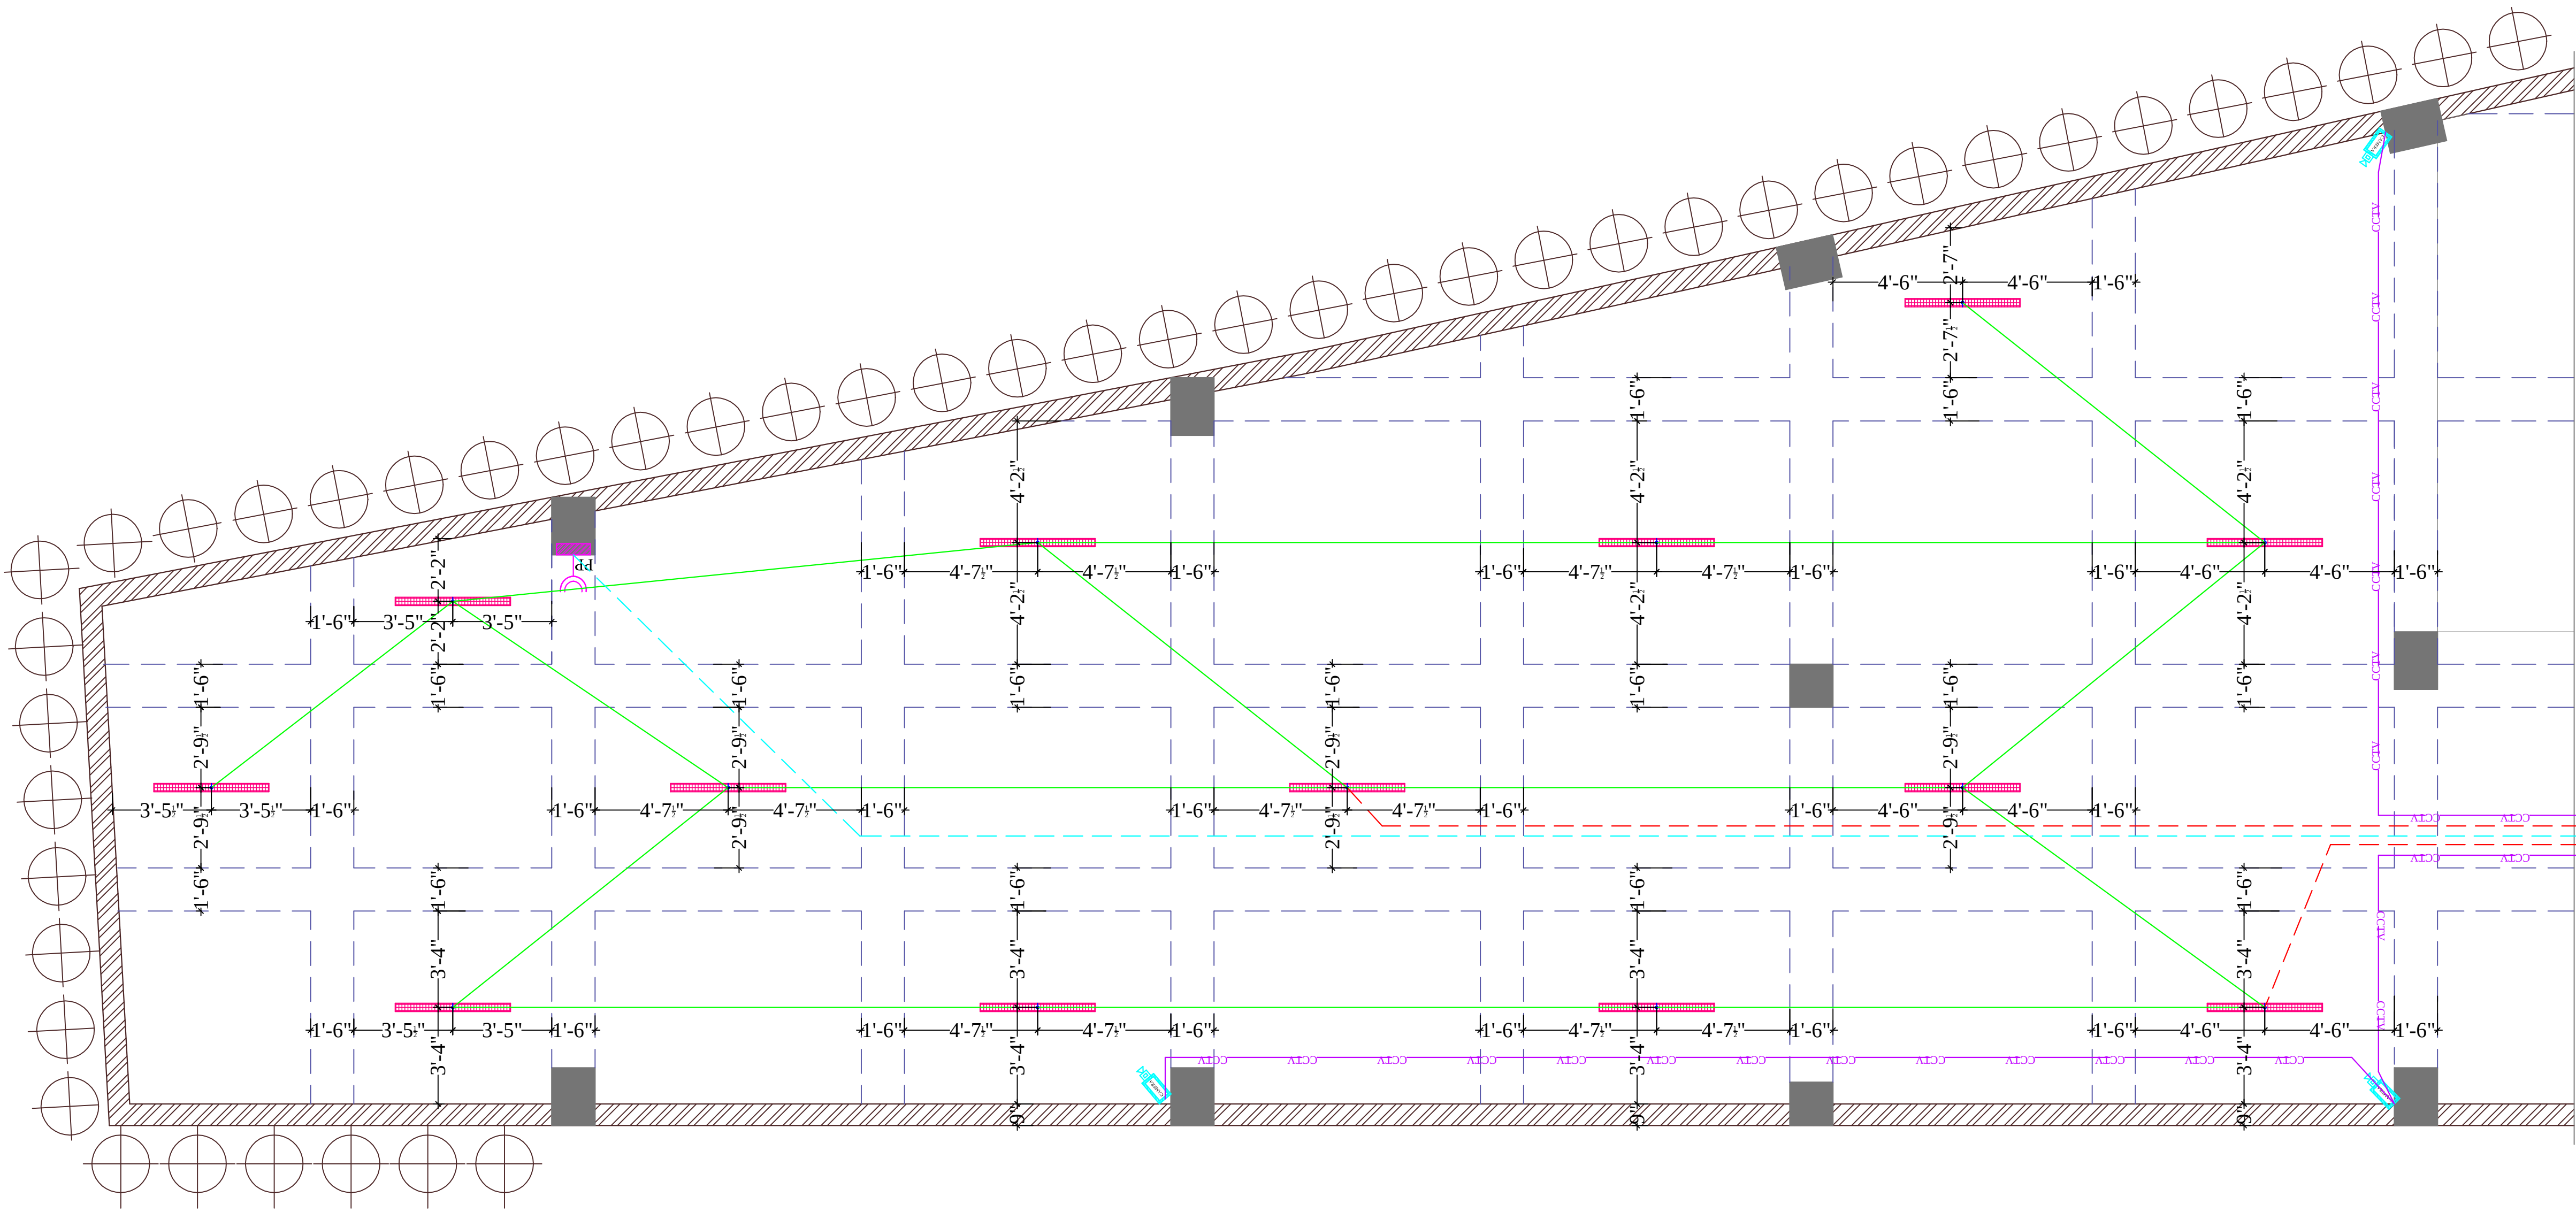

LEGENDS:				
Mounting Height	No.	I D	Symbol	Description
IN RCC SLAB		CONDUIT		Rigid PVC Conduit 25mm/1.5 sqmm wire for Light points
IN RCC SLAB		CONDUIT		Rigid PVC Conduit 25mm/2.5 sqmm wire for Light Circuits
IN RCC SLAB		CONDUIT		Rigid PVC Conduit 25mm/4.00 sqmm wire for POWER Circuits
IN RCC SLAB		CONDUIT		CCTV Rigid PVC 25mm dia. Conduit /3+1 Coaxial Wire For Security Camera (C.C.T.V.).
CEILING	13	TL/C		LED CEILING TUBE LIGHT MAKE:- SYSKA LED CAT NO.:- SSK-T5-20W
+18"	01	PP		16A POWER POINT FOR SUMP
+90"	03	CCTV		WALL MOUNTED CCTV CAMERA

TO BE
CONTINUE

Vipul
VIPUL AGARWAL
M.E.P. CONSULTANT
B.E. ELECTRICAL

CLIENT :

ANUKAMPA AVAS
VIKAS LLP

PROPOSED MIX USE BUILDING
PLOT NO. S-01, NEAR SHYAM
NAGAR, AJMER
ROAD JAIPUR

ARCHITECTS :

desig
n studio

GRAPHITE DESIGN STUDIO

ARCHITECTS, INTERIOR DESIGNERS, PLANNERS

68, Janak Puri -1st, Imliwala phatak, Opp Jain Mandir, Jaipur
CONTACT NO. +91-9928334414, 0141-2593414
email: studiosgraphite@gmail.com
Website : www.graphitedesignstudio.com

GENERAL NOTES

1. All dimensions on this drawing are in feet and inches.
2. Only written dimensions are to be followed. Drawing should not be scaled.
3. All measurements must be checked and verified by the contractors prior to execution of work at the site.
4. This drawing is to be read in conjunction with all relevant structural, services & facility planning drawings.
5. Architectural drawings are to be followed for the location of all structural members & masonry walls. For sizes & reinforcement details of structural members, relevant structural drawings are to be referred.
6. Any discrepancies between architectural, structural and services drawings must be brought to the notice of the architects immediately & prior to execution at site.
7. Co-ordination with services such as hvac, plumbing & electrical, etc. is the responsibility of the contractors.
8. All masonry walls should be aligned with the columns as indicated on the plan, irrespective of the position as calculated with the dimensioning.
9. For details, refer relevant large scale detail drgs. as indicated.

PROJECT:

PROPOSED MIX USE BUILDING
PLOT NO. S-01, NEAR SHYAM NAGAR, AJMER
ROAD JAIPUR

NORTH:



NAME OF DRAWING:

BASEMENT FLOOR LEFT SIDE PART
ELE. & LV CONDUIT PLAN

PROJECT NO. :

302019ANUK00100

DATE :

12-03-19

DRAWN BY:

PAWAN



CKD. BY:

SANJAY

DRAWING NO. :

MEP/ANKU/B.F./LSP/ELE./LV-01

THIS DRAWING IS THE PROPERTY OF GRAPHITE DESIGN STUDIO PVT. LTD., JAIPUR. IT SHALL NOT BE COPIED OR USED WITHOUT THEIR WRITTEN PERMISSION NOR MADE KNOWN TO A THIRD PARTY. THE INFORMATION IS ISSUED ON THE UNDERSTANDING THAT NO PART THEREOF SHALL BE DUPLICATED FOR THE PURPOSE OTHER THAN THE EXPRESSED PURPOSE.

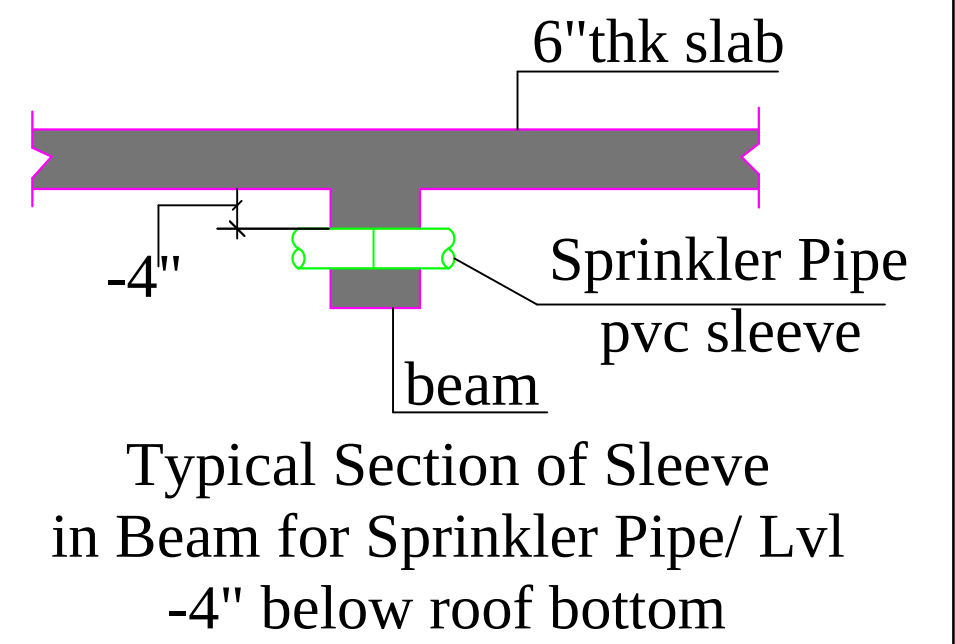
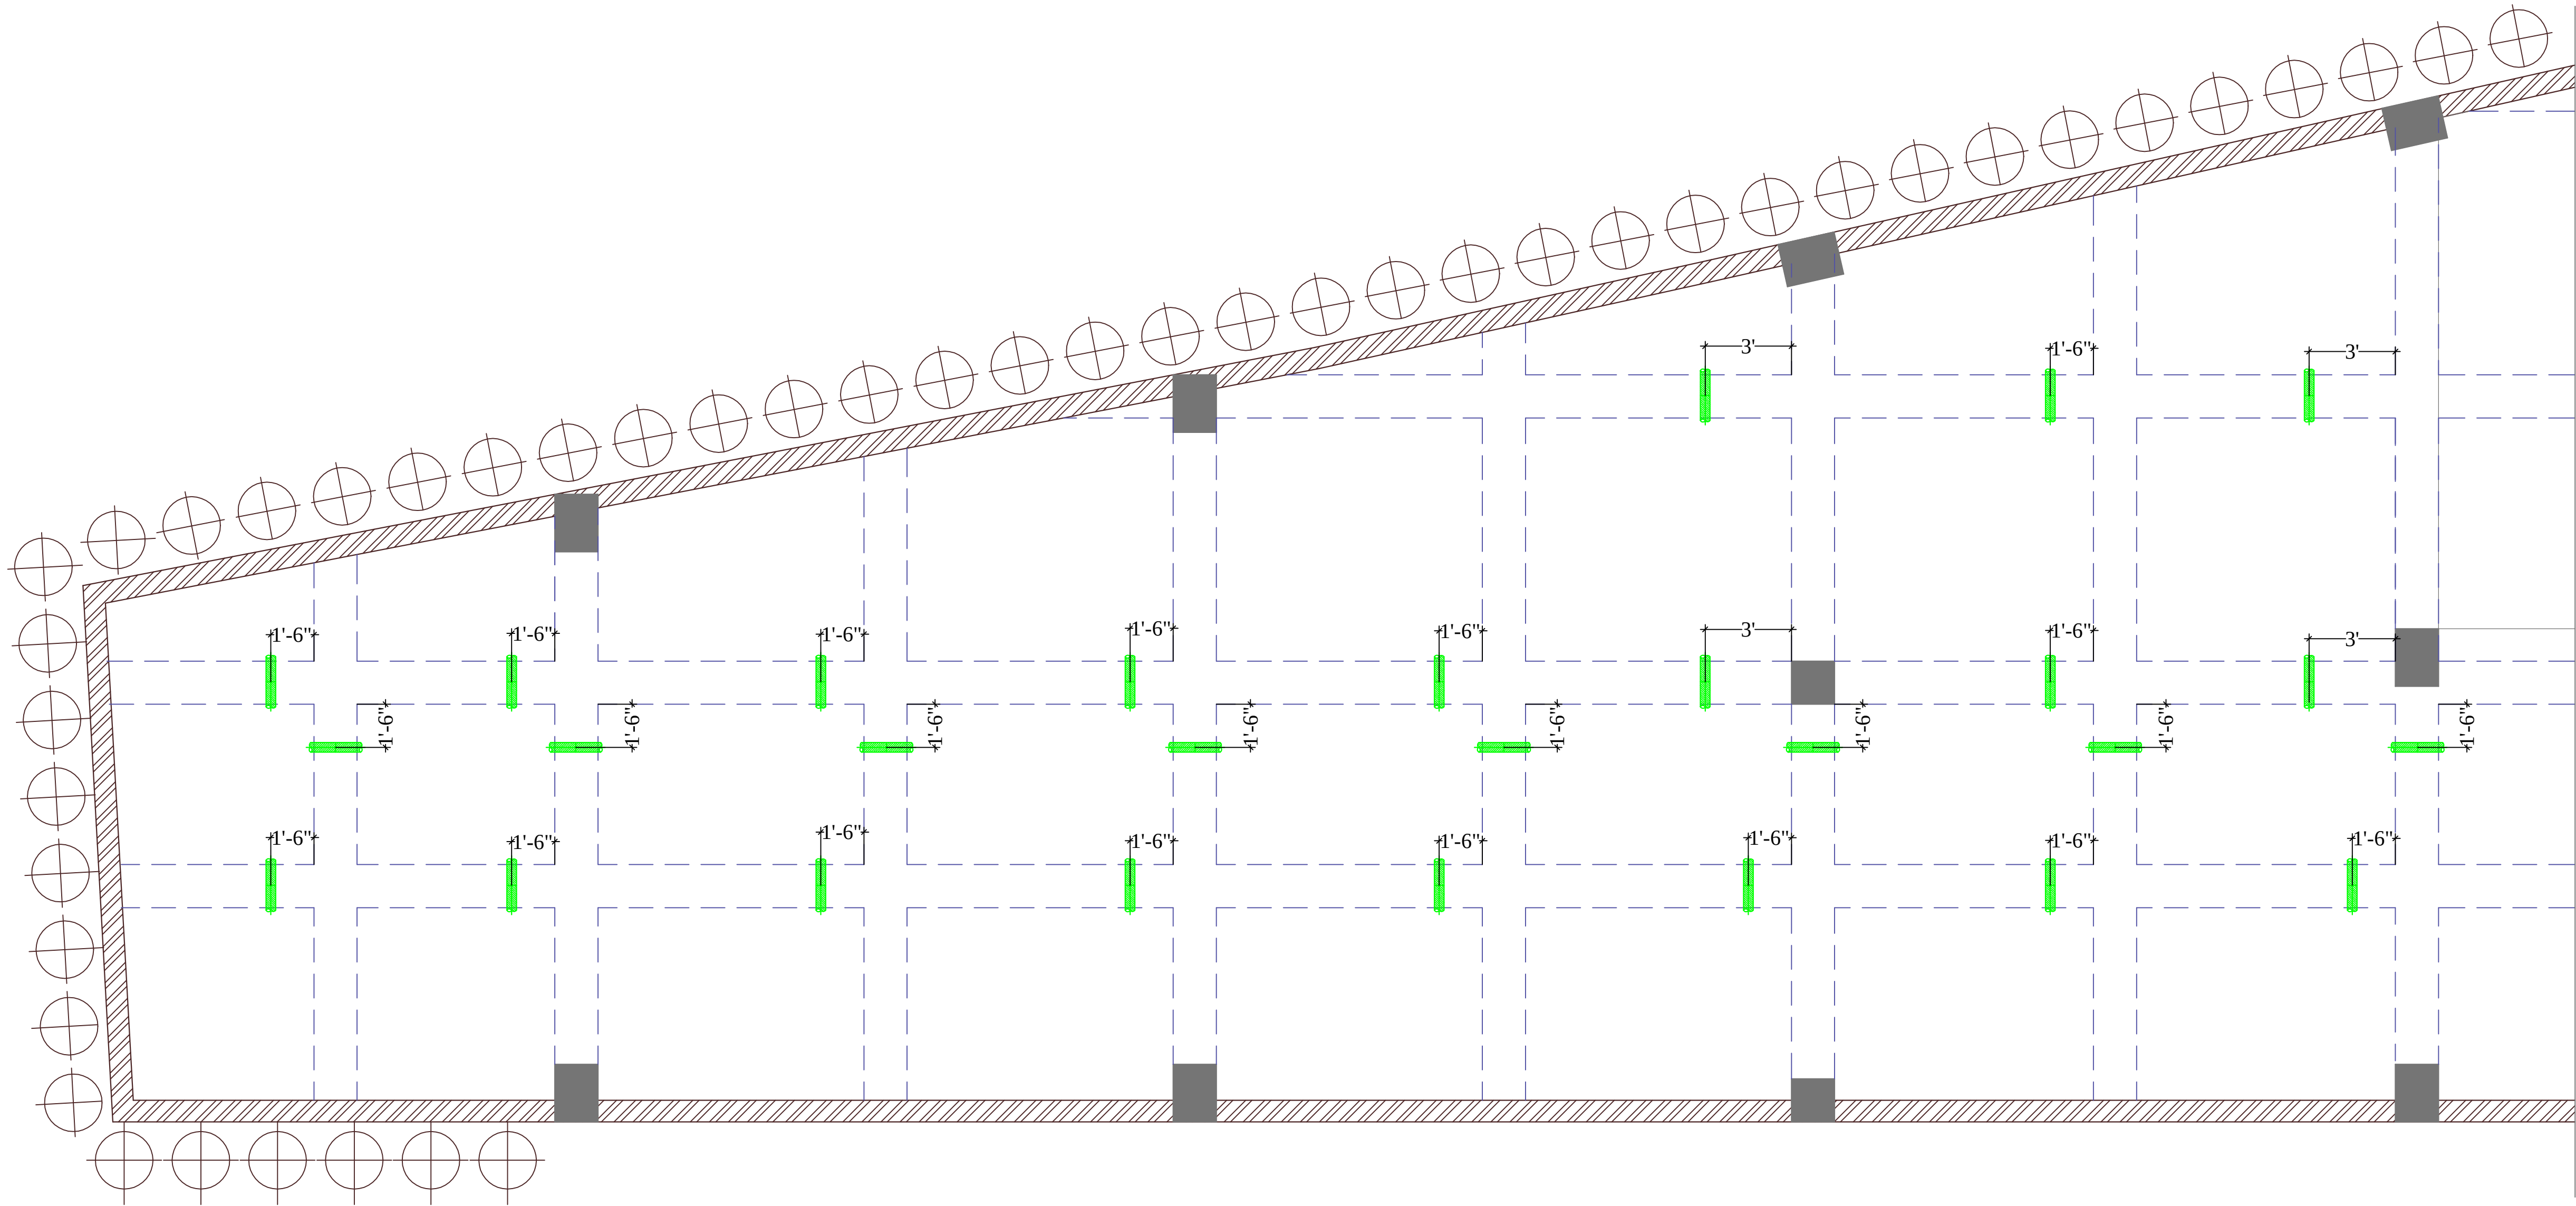


LEGENDS:


Qty.	Symbol	Description
		100 MM DIA. SLEEVE

Vipul
VIPUL AGARWAL
M.E.P. CONSULTANT
B.E. ELECTRICAL

CLIENT : ANUKAMPA AVAS VIKAS LLP	PROPOSED MIX USE BUILDING PLOT NO. S-01, NEAR SHYAM NAGAR, AJMER ROAD JAIPUR	ARCHITECTS :  GRAPHITE DESIGN STUDIO ARCHITECTS, INTERIOR DESIGNERS, PLANNERS 68, Janak Puri -1st, Imliwala phatak, Opp Jain Mandir, Jaipur CONTACT NO. +91-9928334414, 0141-2593414 email: studiosgraphite@gmail.com Website : www.graphitedesignstudio.com	GENERAL NOTES 1. All dimensions on this drawing are in feet and inches. 2. Only written dimensions are to be followed . drawing should not be scaled. 3. All measurements must be checked and verified by the contractors prior to execution of work at the site. 4. This drawing is to be read in conjunction with all relevant structural, services & facility planning drawings. 5. Architectural drawings are to be followed for the location of all structural members & masonry walls, for sizes & reinforcement details of structural members, relevant structural drawings are to be referred. 6. Any discrepancies between architectural, structural and services drawings must be brought to the notice of the architects immediately & prior to execution at site. 7. Co-ordinatio with services such as hvac, plumbing & electrical, etc. is the responsibility of the contractors. 8. All masonry walls should be aligned with the columns as indicated on the plan, irrespective of the position as calculated with the dimensioning. 9. For details, refer relevant large scale detail drgs. as indicated.	PROJECT: PROPOSED MIX USE BUILDING PLOT NO. S-01, NEAR SHYAM NAGAR, AJMER ROAD JAIPUR	NORTH: 
		BASEMENT FLOOR LEFT SIDE PART SPRINKLER SLEEVE PLAN	PROJECT NO. : 302019ANUK00100	DATE : 12-03-19	
			SCALE :	REV NO./DATE : R-00/	
			DRAWN BY: PAWAN	CKD. BY: SANJAY	DRAWING NO. : MEP/ANKU/B.F./LSP/SL-02
			APPROVED BY: VIPUL AGARWAL		
THIS DRAWING IS THE PROPERTY OF GRAPHITE DESIGN STUDIO PVT. LTD. , JAIPUR IT SHALL NOT BE COPIED OR USED WITHOUT THEIR WRITTEN PERMISSION NOR MADE KNOWN TO A THIRD PARTY. THE INFORMATION IS ISSUED ON THE UNDERSTANDING THAT NO PART THEREOF SHALL BE DUPLICATED FOR THE PURPOSE OTHER THAN THE EXPRESSED PURPOSE.					

  LEGENDS:				
Mounting Height	No.	ID	Symbol	Description
IN RCC SLAB		CONDUIT		Rigid PVC Conduit 25mm/1.5 sqmm wire for Light points
IN RCC SLAB		CONDUIT		Rigid PVC Conduit 25mm/2.5 sqmm wire for Light Circuits
IN RCC SLAB		CONDUIT		Rigid PVC Conduit 25mm/4.00 sqmm wire for POWER Circuits
IN RCC SLAB		CONDUIT		Rigid PVC 25mm dia. Conduit /3+1 Coaxial Wire For Security Camera (C.C.T.V.).
IN RCC SLAB		CONDUIT		Rigid PVC Conduit 25mm/ 2X1.5 sq. mm Copper Wire for Fire Alarm
CEILING	38	TL/C		LED CEILING TUBE LIGHT MAKE:- SYSKA LED CAT NO.-: SSK-T5-20W
+90"	02	TL/W		LED WALL TUBE LIGHT MAKE:- SYSKA LED CAT NO.-: SSK-T5-20W
+18"	01	PP		16A POWER POINT FOR SUMP
+60"	01	MCBDB		MCB DISTRIBUTION BOARD
+90"	03	CCTV		WALL MOUNTED CCTV CAMERA
+42"	01	MCP		MANUAL CALL POINT
+90"	01	HT		HOOTER POINT

Vipul
VIPUL AGARWAL
M.E.P. CONSULTANT
B.E. ELECTRICAL

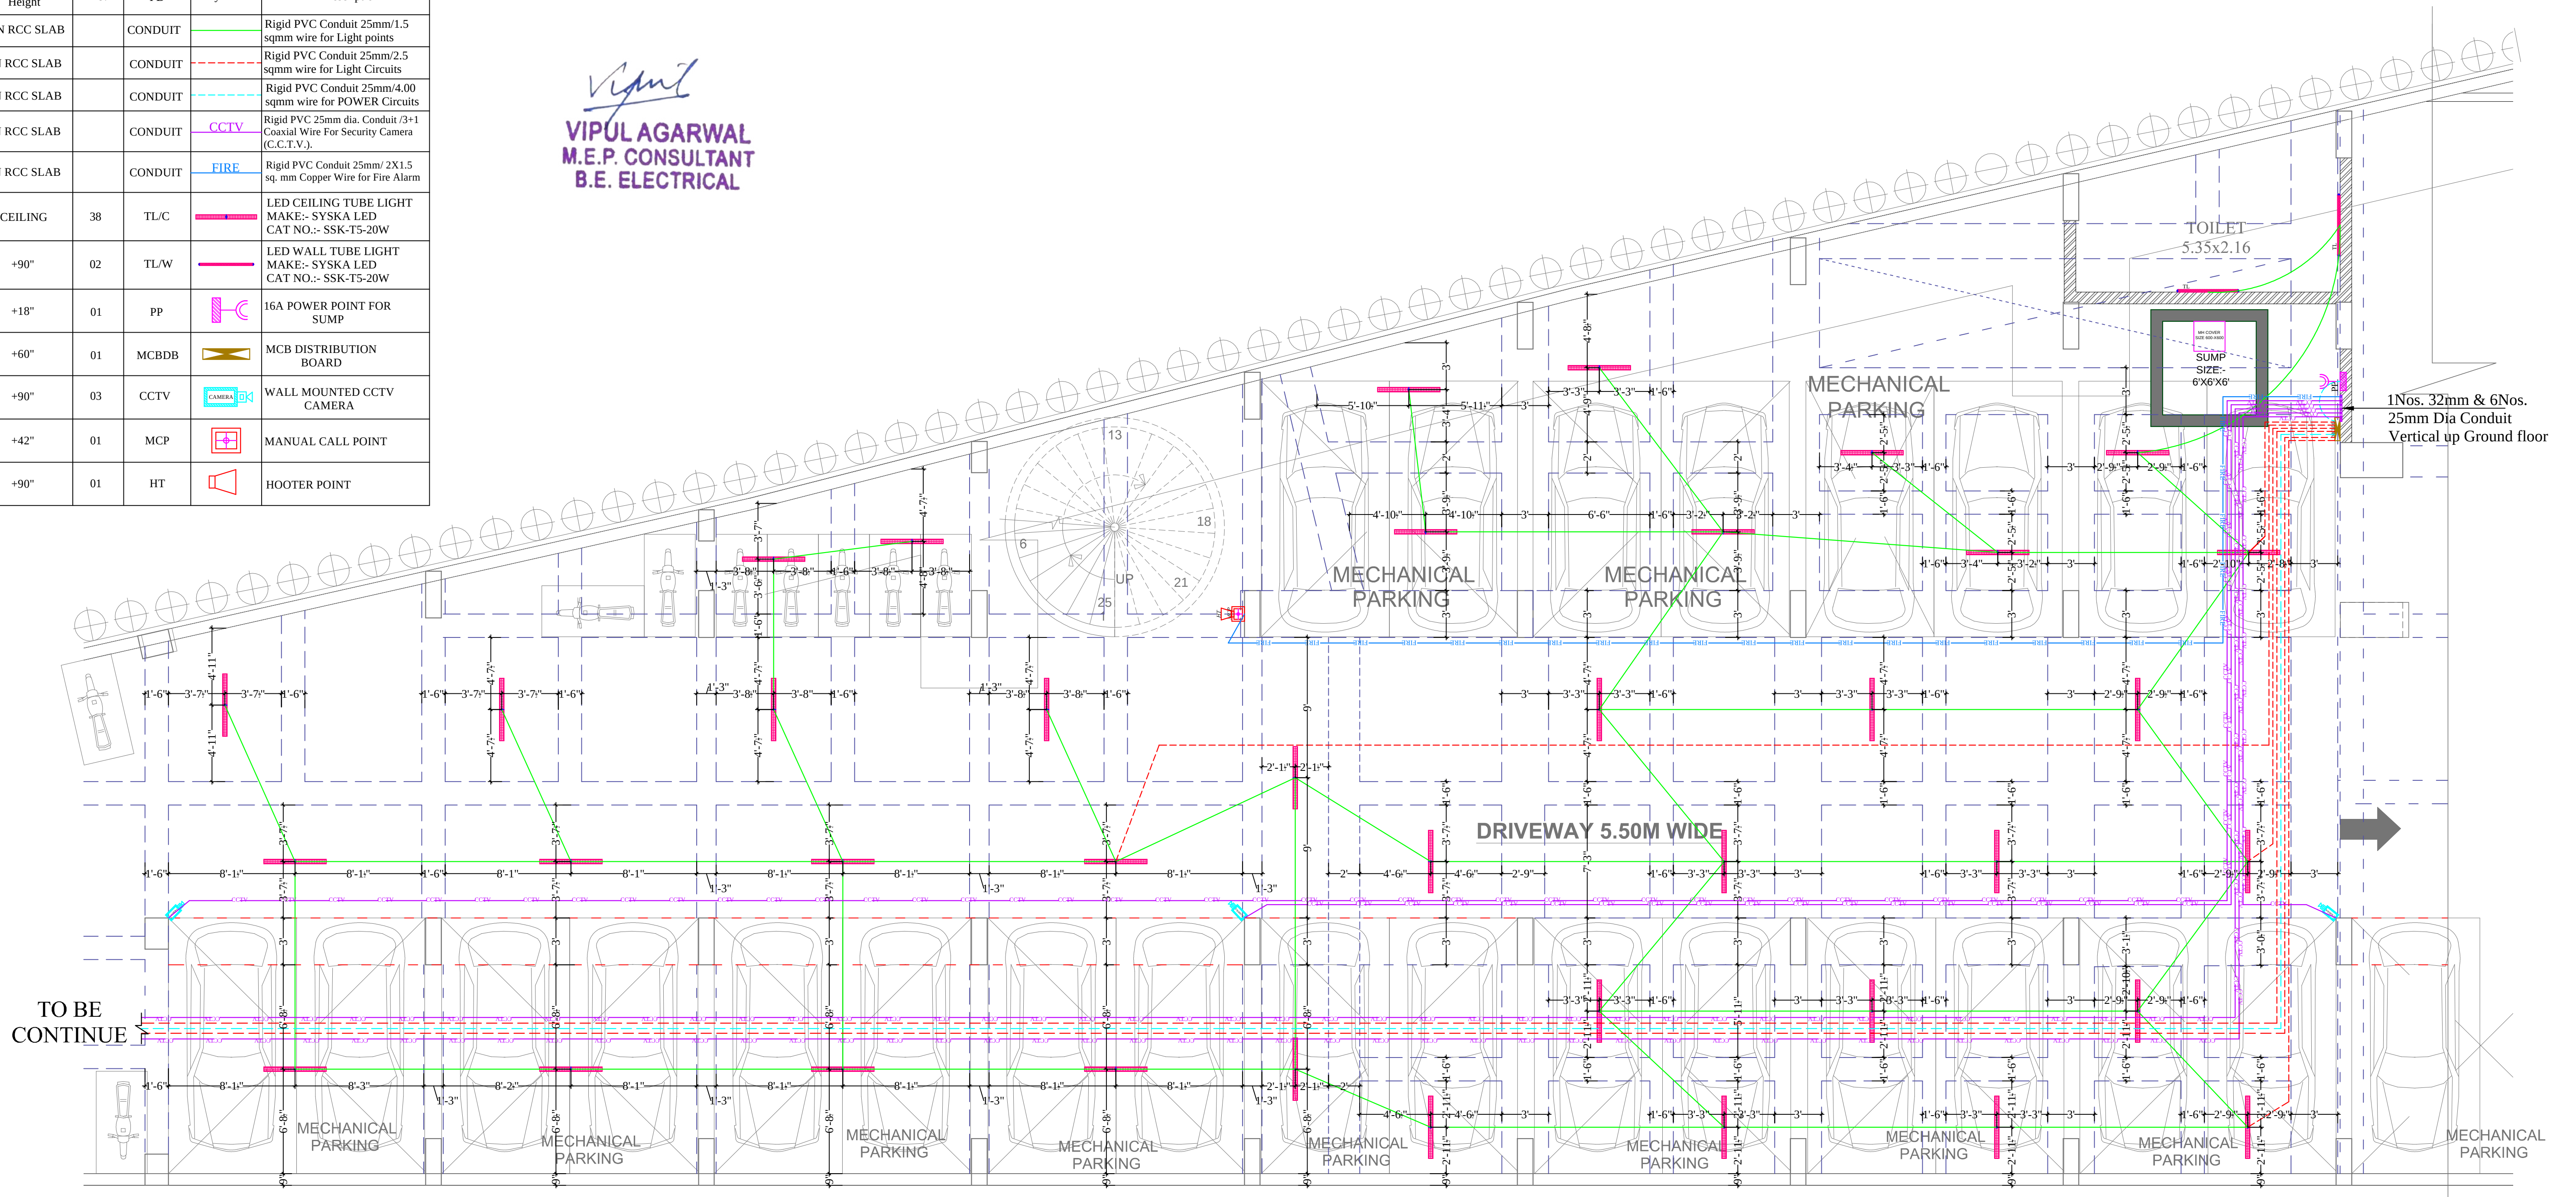

CLIENT :

ANUKAMPA AVAS
VIKAS LLP

PROPOSED MIX USE BUILDING
PLOT NO. S-01, NEAR SHYAM
NAGAR, AJMER
ROAD JAIPUR

ARCHITECTS :

des **g**raphite
n
studio

GRAPHITE DESIGN STUDIO
ARCHITECTS, INTERIOR DESIGNERS, PLANNERS
68, Janak Puri -1st, Imliwala phatak, Opp Jain Mandir, Jaipur
CONTACT NO. +91-9928334414, 0141-2593414
email: studiosgraphite@gmail.com
Website : www.graphitedesignstudio.com

GENERAL NOTES

1. All dimensions on this drawing are in feet and inches.
2. Only written dimensions are to be followed , drawing should not be scaled.
3. All measurements must be checked and verified by the contractors prior to execution of work at the site.
4. This drawing is to be read in conjunction with all relevant structural, services & facility planning drawings.
5. Architectural drawings are to be followed for the location of all structural members & masonry walls, for sizes & reinforcement details of structural members, relevant structural drawings are to be referred.
6. Any discrepancies between architectural, structural and services drawings must be brought to the notice of the architects immediately & prior to execution at site.
7. Co-ordinatio with services such as hvac, plumbing & electrical, etc. Is the responsibility of the contractors.
8. All masonry walls should be aligned with the columns as indicated on the plan, irrespective of the position as calculated with the dimensioning.
9. For details, refer relevant large scale detail drgs. as indicated.

PROJECT:

PROPOSED MIX USE BUILDING
PLOT NO. S-01, NEAR SHYAM NAGAR, AJMER
ROAD JAIPUR

NAME OF DRAWING:

BASEMENT FLOOR LEFT SIDE PART
ELE. & LV CONDUIT PLAN

DRAWN BY:


VIJESH

SANJAY

APPROVED BY:

VIPUL AGARWAL

NORTH:

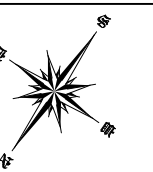

DATE : _____

01-04-19

SCALE :

REV NO./DATE :

R-00/

DRAWING NO. :


MEP/ANKU/B.F./LSP/ELE./LV-01



VIPUL AGARWAL
M.E.P. CONSULTANT
B.E. ELECTRICAL

LEGENDS:

Qty.	Symbol	Description
52		100 MM DIA. SLEEVE
05		150 MM DIA. SLEEVE

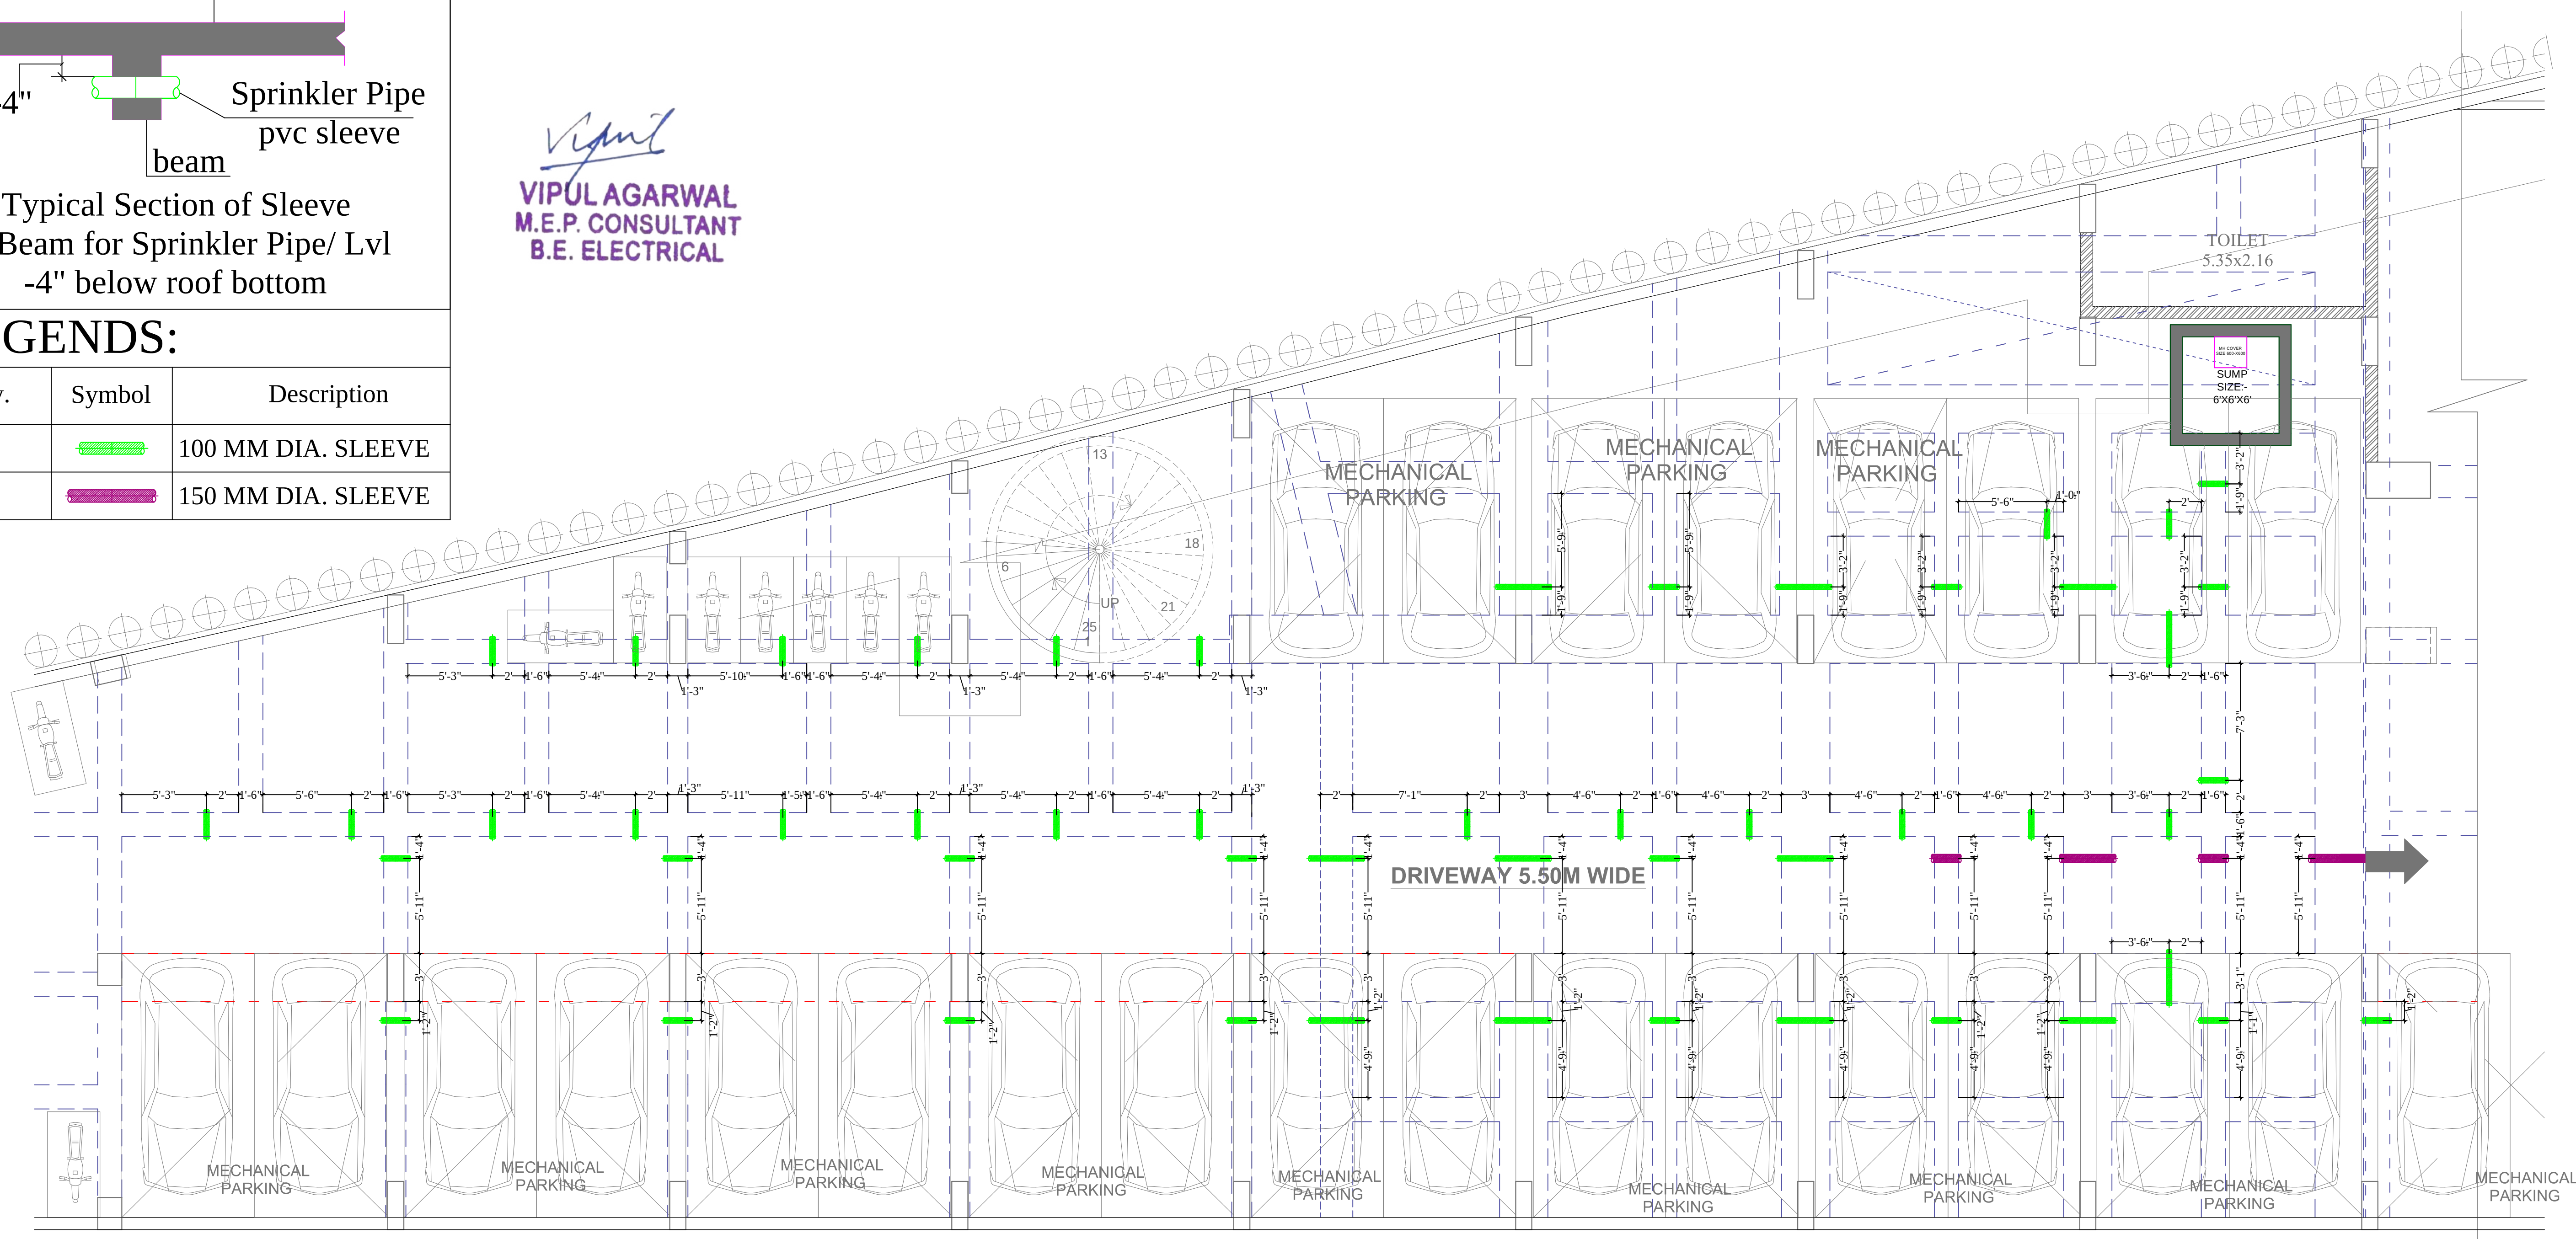

CLIENT :

ANUKAMPA AVAS
VIKAS LLP

PROPOSED MIX USE BUILDING
PLOT NO. S-01, NEAR SHYAM
NAGAR, AJMER
ROAD JAIPUR

ARCHITECTS :

des **g**raphite
n
tudio

GRAPHITE DESIGN STUDIO

ARCHITECTS, INTERIOR DESIGNERS, PLANNERS

68, Janak Puri -1st, Imliwala phatak, Opp Jain Mandir, Jaipur
CONTACT NO. : 01-2622224444, 0141-2522444

CONTACT NO. +91-9928334414,
email: studiosgraphite@gmail.com

Website : www.graphitedesignstudio.com

GENERAL NOTES

1. All dimensions on this drawing are in feet and inches.
2. Only written dimensions are to be followed , drawing should not be scaled.
3. All measurements must be checked and verified by the contractors prior to execution of work at the site.
4. This drawing is to be read in conjunction with all relevant structural, services & facility planning drawings.
5. Architectural drawings are to be followed for the location of all structural members & masonry walls, for sizes & reinforcement details of structural members, relevant structural drawings are to be referred.
6. Any discrepancies between architectural, structural and services drawings must be brought to the notice of the architects immediately & prior to execution at site.
7. Co-ordination with services such as hvac, plumbing & electrical, etc. Is the responsibility of the contractors.
8. All masonry walls should be aligned with the columns as indicated on the plan, irrespective of the position as calculated with the dimensioning.
9. For details, refer relevant large scale detail drgs. as indicated.

PROJECT:

PROPOSED MIX USE BUILDING
PLOT NO. S-01, NEAR SHYAM NAGAR, AJMER
ROAD JAIPUR

NAME OF DRAWING:

BASEMENT FLOOR LEFT SIDE PART
SPRINKLER SLEEVE PLAN

DRAWN BY:

VIJESH

CKD. BY:	
----------	--

SANJAY

APPROVED BY:

VIPUL AGARWAL

	NORTH:
--	--------



PROJECT NO.:

PROJECT NO. :

302019A

100

	DRAWING NO.
--	-------------

MEP/ANKU/B.F./LSP/SL-02

THIS DRAWING IS THE PROPERTY OF GRAPHITE DESIGN STUDIO PVT. LTD. , JAIPUR IT SHALL NOT BE COPIED OR USED WITHOUT THEIR WRITTEN PERMISSION NOR MADE KNOWN TO A THIRD PARTY. THE INFORMATION IS ISSUED ON THE UNDERSTANDING THAT NO PART THEREOF SHALL BE DUPLICATED FOR THE PURPOSE OTHER THAN THE EXPRESSED PURPOSE.

SERVICES CONSULTANT:
VIPUL CONSULTING,
F 9 / 440 , Keshav Marg Chitrakut Scheme,Jaipur
PH:91-0-93146-10438 ,0141-2440946 Mail:vipul8599@yahoo.com

ARCHITECTS :
desig
GRAPHITE DESIGN STUDIO
ARCHITECTS, INTERIOR DESIGNERS, PLANNERS
68, Janak Puri -1st, Jhilmwala phatak, Opp Jain Mandir, Jaipur
CONTACT NO. +91-9928334414, 0141-2593414
email: studiosgraphite@gmail.com
Website : www.graphitedesignstudio.com

CLIENT :

ANUKAMPA AVAS
VIKAS LLP

PROJECT:

PROPOSED MIX USE BUILDING
PLOT NO. S-01, NEAR SHYAM
NAGAR, AJMER ROAD JAIPUR

NAME OF DRAWING:

BASEMENT FLOOR
ELECTRIC CONTROL
WIRING PLAN

DRAWN BY: CKD. BY: APPROVED BY:

PAWAN SANJAY VIPUL AGARWAL

NORTH:

PROJECT NO. : DATE : REV.:-

302019ANUK00100 04-12-19 00

SCALE : DRAWING NO. :

MEP/AS/B.F/ECW-01

LEGENDS:					
Mounting Height	No.	I D	Symbol	Description	
IN CONDUIT		WIRE		Control Wiring For Light Point 1.5 sqmm Red (Phase),Black (Neutral), 1.5 sqmm Green (Earth)	
IN CONDUIT		WIRE		Control Wiring For Emergency Point 1.5 sqmm Red (Phase),Black (Neutral),1.5 sqmm Green (Earth)	
IN CONDUIT		WIRE		Light Circuit 2.5 sqmm Red (Phase),Black (Neutral),1.5 sqmm Green (Earth)	
IN CONDUIT		WIRE		Power Circuit 4.0 sqmm Red (Phase),Black (Neutral),2.5 sqmm Green (Earth)	
IN CONDUIT		WIRE		AC Circuit 4.0 sqmm Red (Phase),Black (Neutral),2.5 sqmm Green (Earth)	
CEILING	01	FB		FAN BOX	
CEILING	28	FAN/48"		CEILING FAN 48"	
CEILING	01	FAN/30"		CEILING FAN 30"	
CEILING	193	TL/C		Led Ceiling Tube Light Make:- Syska Led Cat no:- SSK-TS-20W	
+90"	34	TL/W		Led Wall Tube Light Make:- Syska Led Cat no:- SSK-TS-20W	
CEILING	71	CFL		Led 6" Down Lighter 20W (Surface Mounted) Make:- Syska Led Cat no:- SSK-TSW GLD 6.5K/4K	
+21"	09	FL		Foot Light Rabreco Make Cat no:- ACTPFW1.08	
+42"	28	SB		SWITCH BOARD	
+18"	04	FP		16 A POWER POINT FOR SUMP	
+60"	05	MCB DB		MCB DISTRIBUTION BOARD	
	08			DB NO. EMERGENCY LIGHT CIRCUIT NO.	
	22			DB NO. SWITCH BOARD NO./ LIGHT CIRCUIT NO./MODULAR NO.	
	04			DB NO./POWER CIRCUIT NO./ MODULAR NO.	
	59			EMERGENCY LIGHT POINT	

VIPUL
VIPUL AGARWAL
M.E.P. CONSULTANT
B.E. ELECTRICAL

4 WAY TPN DB-1
LIGHT CIRCUIT-06
POWER CIRCUIT-02
EMERGENCY CIRCUIT-02
TOTAL CIRCUIT-10

EXPENSIN JOINT

MCBDB-1

MCBDB-2

MCBDB-3

MCBDB-4

MCBDB-5

6 WAY TPN DB-5
LIGHT CIRCUIT-08
POWER CIRCUIT-02
EMERGENCY CIRCUIT-03
TOTAL CIRCUIT-13

4 WAY TPN DB-4
LIGHT CIRCUIT-06
EMERGENCY CIRCUIT-02
TOTAL CIRCUIT-08

DB1/P1 3M

DB1/L1 3M

DB1/L2 3M

DB1/L3 3M

DB1/L708 3M


DB1/L709 3M

DB1/L710 3M

DB1/L711 3M

DB1/L712 3M


DB1/L

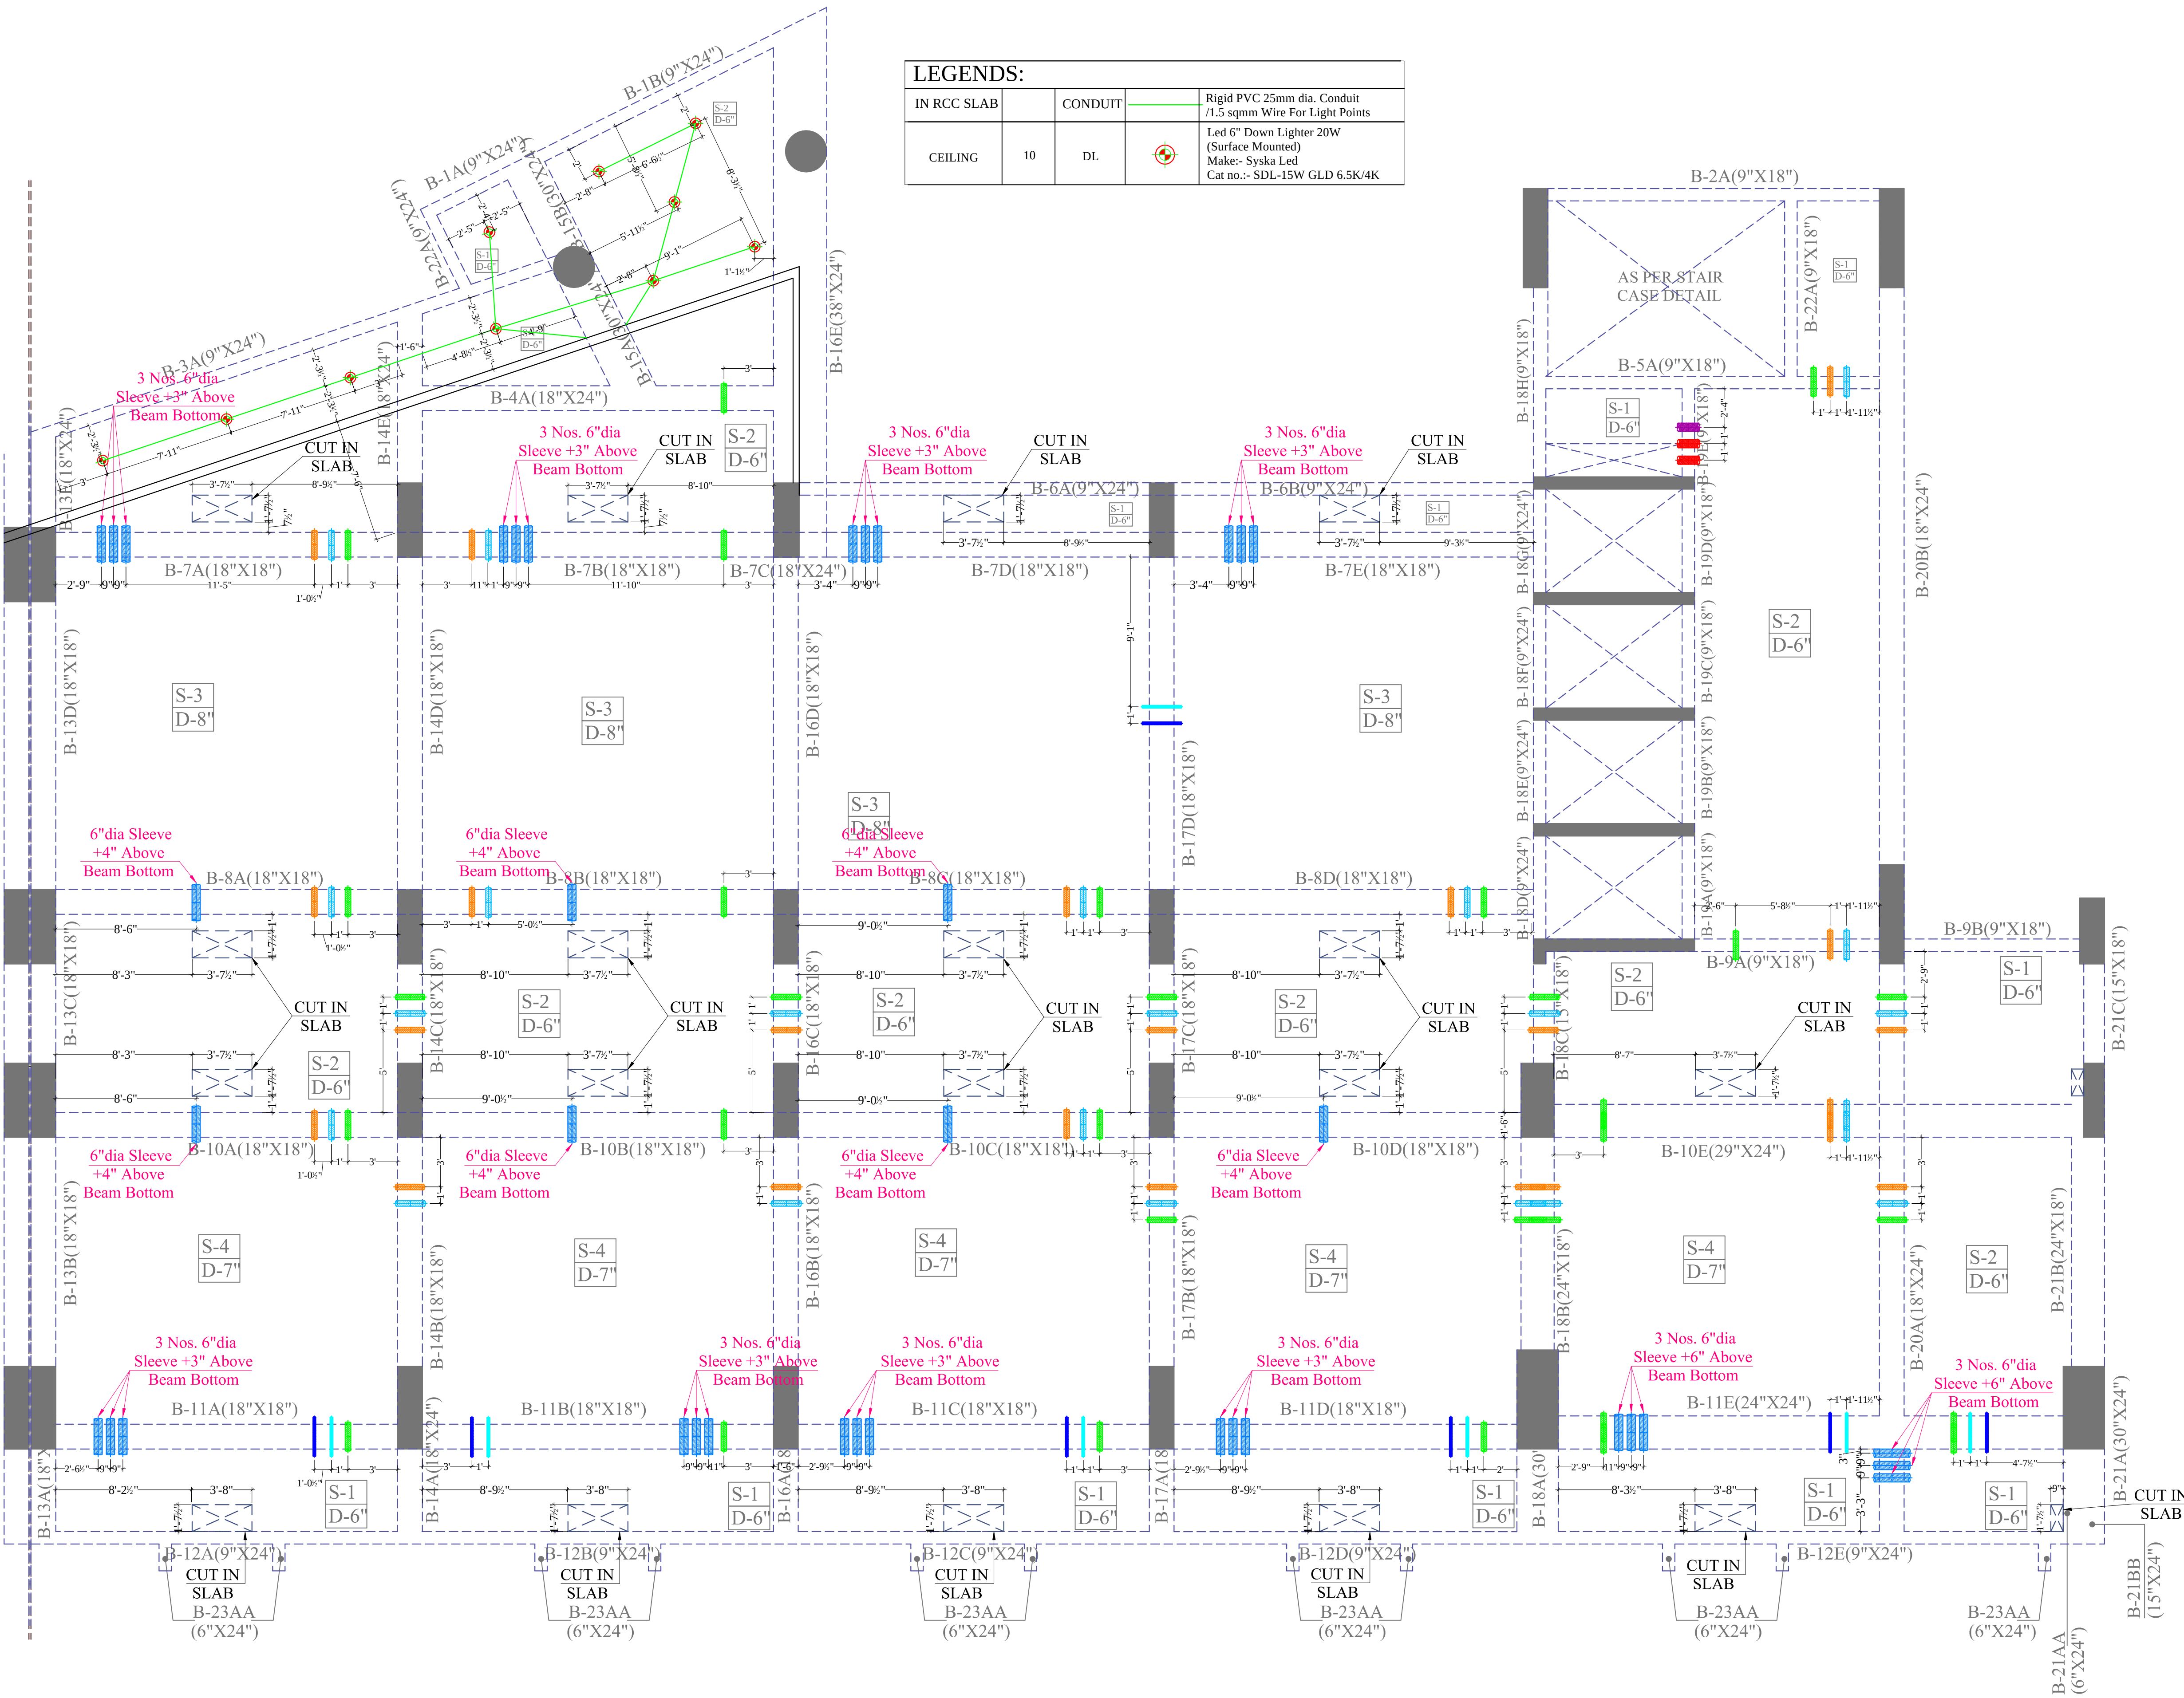

LEGENDS:				
IN RCC SLAB		CONDUIT		Rigid PVC 25mm dia. Conduit /1.5 sqmm Wire For Light Points
CEILING	10	DL		Led 6" Down Lighter 20W (Surface Mounted) Make:- Syska Led Cat no.:- SDL-15W GLD 6.5K/4K

VIPUL AGARWAL
M.E.P. CONSULTANT
B.E. ELECTRICAL

LEGENDS:	
Symbol	Description
	6" Dia PVC SLEEVE IN BEAM FOR ELECTRIC CABLE -3" BELOW SLAB BOTTOM LVL
	4" Dia PVC SLEEVE IN BEAM FOR ELECTRIC CABLE -3" BELOW SLAB BOTTOM LVL
	2" Dia PVC SLEEVE IN BEAM FOR ELECTRIC CABLE -3" BELOW SLAB BOTTOM LVL
	4" Dia PVC SLEEVE IN BEAM FOR LV CABLE -3" BELOW SLAB BOTTOM LVL
	2" Dia PVC SLEEVE IN BEAM FOR LV CABLE -3" BELOW SLAB BOTTOM LVL
	6" Dia PVC SLEEVE IN BEAM FOR SPRINKLER PIPE -4" BELOW SLAB BOTTOM LVL
	4" Dia PVC SLEEVE IN BEAM FOR SPRINKLER PIPE -4" BELOW SLAB BOTTOM LVL
	6" Dia PVC SLEEVE IN BEAM FOR DRAINAGE PIPE -4" BELOW SLAB BOTTOM LVL
SERVICES CONS.:-	
ASHI ASSOCIATES F 9/440, Keshav Marg, Chitrakoot Scheme, Ajmer Road, Jaipur TEL:-+91-141-2440946,M:+91-9314610438 email : vipul8599@yahoo.com	
ARCHITECTS :	
des ign studio GRAPHITE DESIGN STUDIO ARCHITECTS, INTERIOR DESIGNERS, PLANNERS 68, Janak Puri -1st, Imliwala phatak, Opp Jain Mandir, Jaipur CONTACT NO. +91-9928334414, 0141-2593414 email: studiosgraphite@gmail.com Website : www.graphitedesignstudio.com	
CLIENT :	
ANUKAMPA AVAS VIKAS LLP	
PROJECT:	
PROPOSED MIX USE BUILDING PLOT NO. S-01, NEAR SHYAM NAGAR, AJMER ROAD JAIPUR	
NAME OF DRAWING:	
(GRID NO:- V-29 TO V-44) BLOCK-B FIRST FLOOR ELECTRIC CONDUIT & ROOF SERVICES SLEEVE PLAN	
DRAWN BY:	CKD. BY:
RAJENDER	SANJAY
APPROVED BY:	
VIPUL AGARWAL	
NORTH:	
PROJECT NO. :	DATE :
302019ANUK00100	04-10-2019
SCALE :	REV:-
	00
DRAWING NO. :	
MEP/AS/B/1.F/V-29TOV-44/SL.-01	

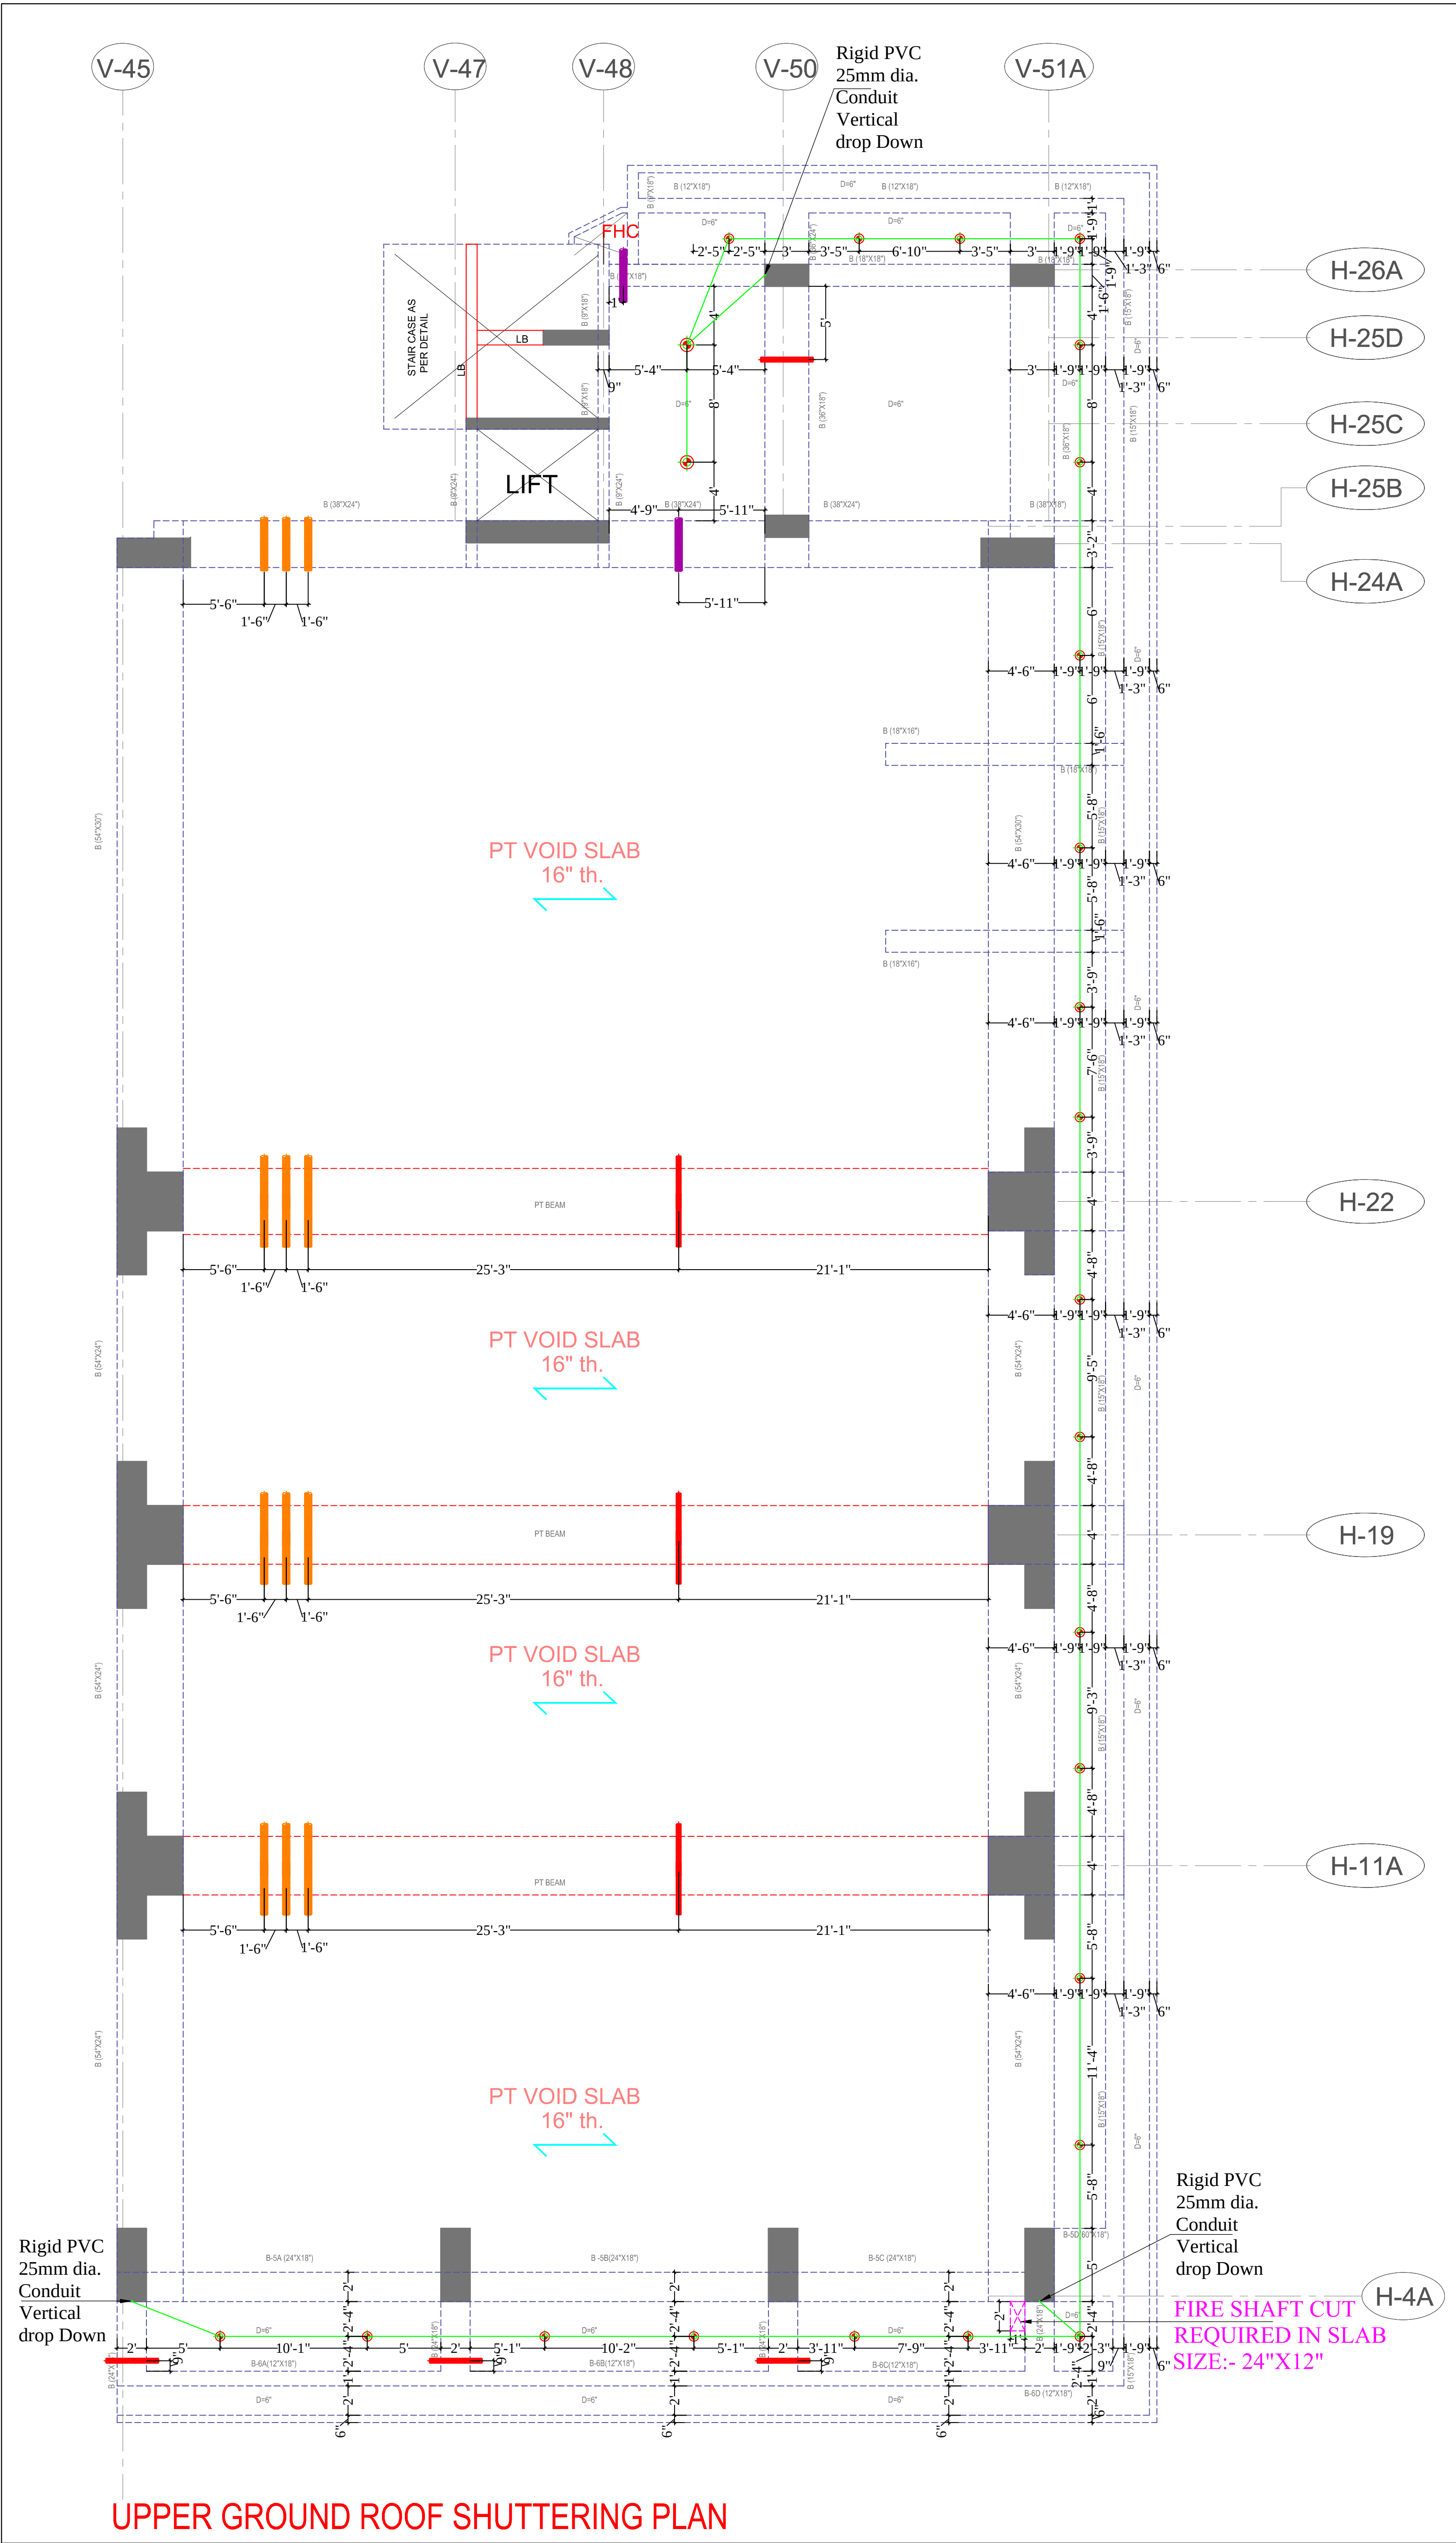

Vipul
VIPUL AGARWAL
M.E.P. CONSULTANT
B.E. ELECTRICAL


LEGENDS:				
Mounting Height	No.	I D	Symbol	Description
IN RCC SLAB		CONDUIT		Rigid PVC 25mm dia. Conduit /1.5 sqmm Wire For Light Points
CEILING	25	DL		Led 6" Down Lighter 20W (Surface Mounted) Make:- Syska Led Cat no.:- SDL-15W GLD 6.5K/4K

LEGENDS:		
Qty.	Symbol	Description
02		6" Dia PVC SLEEVE IN BEAM FOR SPRINKLER PIPE -4" BELOW SLAB BOTTOM LVL
07		4" Dia PVC SLEEVE IN BEAM FOR SPRINKLER PIPE -4" BELOW SLAB BOTTOM LVL
12		6" Dia PVC SLEEVE IN BEAM FOR AC PIPE -4" BELOW SLAB BOTTOM LVL


SERVICES CONSULTANT: VIPUL CONSULTING, F 9 / 440 , Keshav Marg Chitrakut Scheme,Jaipur PH:91-0-93146-10438 ,0141-2440946 Mail:vipul8599@yahoo.com		
ARCHITECTS : GRAPHITE DESIGN STUDIO ARCHITECTS, INTERIOR DESIGNERS, PLANNERS 68, Janak Puri -1st, Imliwala phatak, Opp Jain Mandir, Jaipur CONTACT NO. +91-9928334414, 0141-2593414 email: studiosgraphite@gmail.com Website : www.graphitedesignstudio.com		
CLIENT : ANUKAMPA AVAS VIKAS LLP		
PROJECT: PROPOSED MIX USE BUILDING PLOT NO. S-01, NEAR SHYAM NAGAR, AJMER ROAD JAIPUR		
NAME OF DRAWING: (GRID NO:- V-43 TO V-51A) BLOCK-C UPPER GROUND FLOOR ROOF AC & SPRINKLER SLEEVE & ELECTRIC CONDUIT PLAN		
DRAWN BY: VIJESH	CKD. BY: SANJAY	APPROVED BY: VIPUL AGARWAL
NORTH: 		
PROJECT NO. : 302019ANUK00100	DATE : 06-02-2020	REV.:- 00
SCALE :		DRAWING NO. : MEP/AS/U.G.F./C/SL-01

Mounting Height	No.	I D	Symbol	Description
IN RCC SLAB		CONDUIT		Rigid PVC 25mm dia. Conduit /1.5 sqmm Wire For Light Points
IN RCC SLAB		CONDUIT		Rigid PVC 25mm dia. Conduit /2.5 sqmm Wire For Light Circuits
IN RCC SLAB		CONDUIT		Rigid PVC 25mm dia. Conduit / 4.00 sqmm Wire For Power Circuits
IN RCC SLAB		CONDUIT		Submain Wire to DB From Main Panel on Ground Floor in 1 nos. 32 mm dia Conduits
CEILING	84	FAN/48"		CEILING FAN 48"
+90"	73	TL/W		Led Wall Tube Light Make:- Syska Led Cat no.- SSK-T5-20W
+90"	09	GL		WALL BRACKETS AS DESIGN FOR GANESH LIGHT
CEILING	126	DL		Led 6" Down Lighter 20W (Surface Mounted) Make:- Syska Led Cat no.-: SDL-15W GLD 6.5K/4K
+18"	09	SET		1Nos. 6A Socket Controlled by 1No. 6A Switch ,1Nos. 16A 5Pin Socket Controlled by 1No. 16A Switch, 1No.Telephone jack & 1No. TV Coaxial Jack
+42"	27	SB		SWITCH BOARD
+60"	09	MCB DB		MCB DISTRIBUTION BOARD

F 9 / 440 , Keshav Marg Chitrakut Scheme,Jaipur
PH:91-0-93146-10438 ,0141-2440946 Mail:vipul8599@yahoo.com

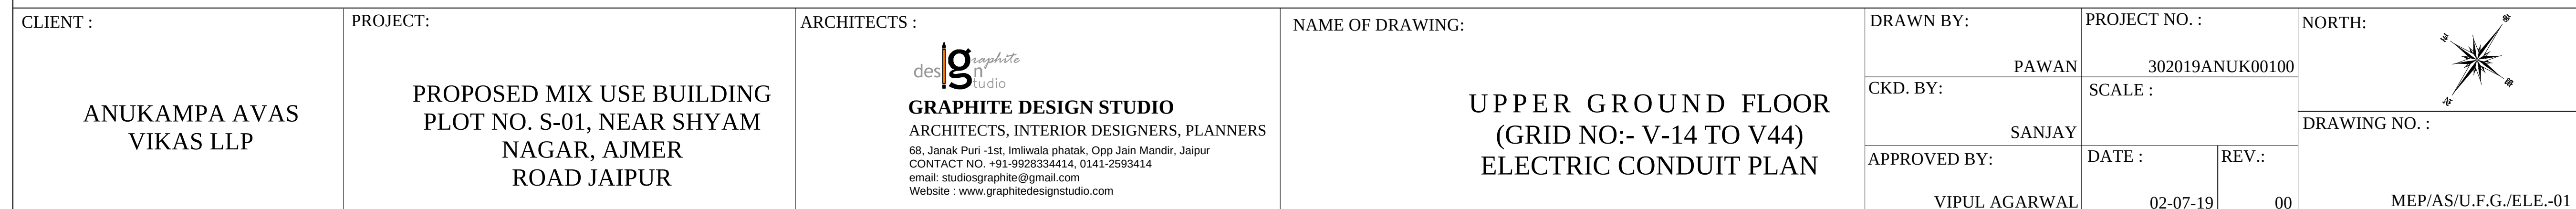

LEGENDS:				
Mounting Height	No.	ID	Symbol	Description
IN CONDUIT		WIRE		Control Wiring For Light Point 1.5 sqmm Red [Phase],Black [Neutral], 1.5 sqmm Green [Earth]
IN CONDUIT		WIRE		Control Wiring For Emergency Point 1.5 sqmm Red [Phase],Black [Neutral], 1.5 sqmm Green [Earth]
IN CONDUIT		WIRE		Light Circuit 2.5 sqmm Red [Phase],Black [Neutral], 1.5 sqmm Green [Earth]
IN CONDUIT		WIRE		Power Circuit 4.0 sqmm Red [Phase],Black [Neutral], 2.5 sqmm Green [Earth]
IN CONDUIT		WIRE		AC Circuit 4.0 sqmm Red [Phase],Black [Neutral], 2.5 sqmm Green [Earth]
CEILING	241	CL		CONCEALED LIGHT POINT
CEILING	01	CHI		CHANDELIER
+42"	02	SB		SWITCH BOARD
ABOVE FALSE CEILING	16	PP		16 A POWER POINT
+60"	01	LDB		LIGHT DISTRIBUTION BOARD 4WAY TPN LIGHT DB
+60"	01	EDB		EMERGENCY LIGHT DISTRIBUTION BOARD 4WAY TPN EMERGENCY LIGHT DB
+60"	01	ACDB		AC DISTRIBUTION BOARD 6WAY TPN AC DB
	11			LIGHT DB/ SWITCH BOARD NO./ LIGHT CIRCUIT NO./MODULAR NO.
	10			EMERGENCY LIGHT DB/ EMERGENCY LIGHT CIRCUIT NO.
	16			AC DB/ AC CIRCUIT NO.
	106			EMERGENCY LIGHT POINT
SERVICES CONSULTANT: VIPUL CONSULTING, F 9 / 440 , Keshav Marg Chitrakut Scheme,Jaipur PH:91-0-93146-10438 ,0141-2440946 Mail:vipul8599@yahoo.com				

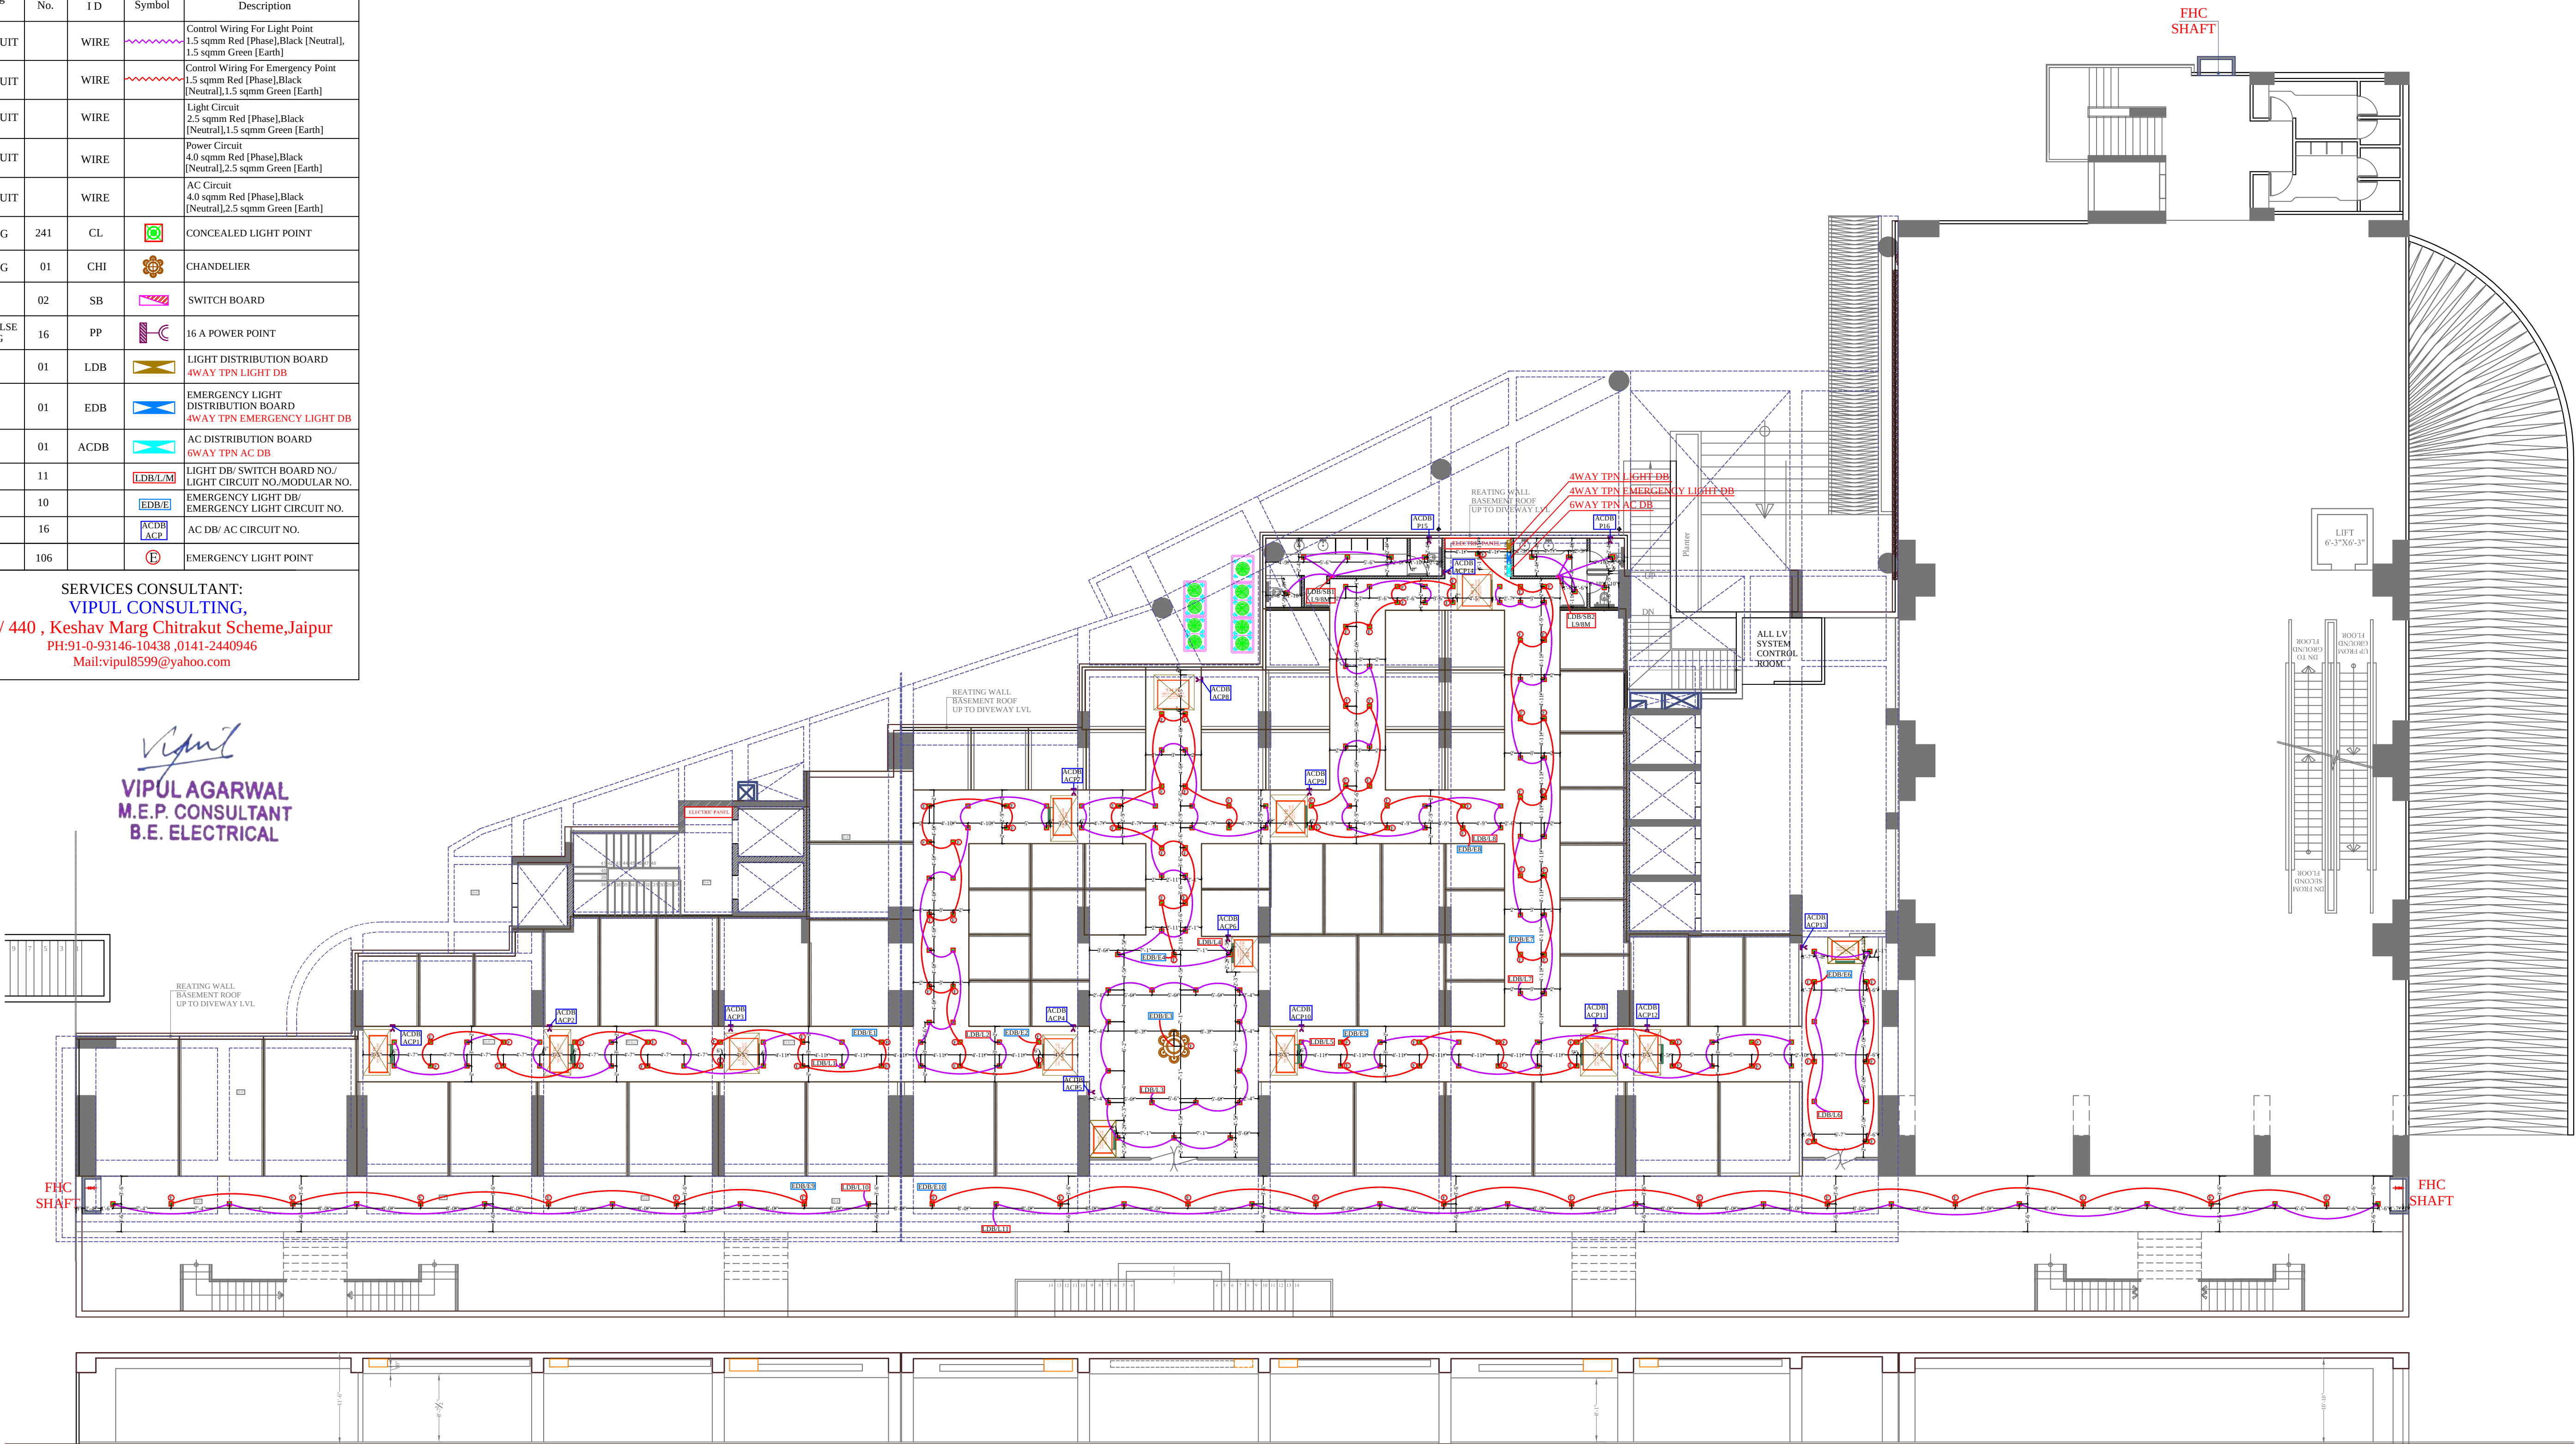


CLIENT :	PROJECT:	ARCHITECTS :	NAME OF DRAWING:	DRAWN BY:	PROJECT NO. :	NORTH:	
ANUKAMPA AVAS VIKAS LLP	PROPOSED MIX USE BUILDING PLOT NO. S-01, NEAR SHYAM NAGAR, AJMER ROAD JAIPUR	 GRAPHITE DESIGN STUDIO ARCHITECTS, INTERIOR DESIGNERS, PLANNERS 68, Janak Puri -1st, Imliwala phatak, Opp Jain Mandir, Jaipur CONTACT NO. +91-9928334414, 0141-2593414 email: studiosgraphite@gmail.com Website : www.graphitedesignstudio.com	LOWER GROUND FLOOR COMMON AREAS ELECTRIC CONTROL WIRING PLAN	PAWAN	302019ANUK00100		
				CKD. BY:	SCALE :		
				APPROVED BY:	DATE :	REV.:	DRAWING NO. :
				VIPUL AGARWAL	26-11-19	00	MEP/AS/L.F.G./ECW.-02

LEGENDS:

Mounting Height	No.	I D	Symbol	Description
IN CONDUIT		WIRE		Control Wiring For Light Point 1.5 sqmm Red [Phase],Black [Neutral], 1.5 sqmm Green [Earth]
IN CONDUIT		WIRE		Light Circuit 2.5 sqmm Red [Phase],Black [Neutral],1.5 sqmm Green [Earth]
IN CONDUIT		WIRE		Power Circuit 4.0 sqmm Red [Phase],Black [Neutral],2.5 sqmm Green [Earth]
CEILING	228	CL		CONCEALED LIGHT POINT
+42"	73	SB		SWITCH BOARD

SERVICES CONSULTANT:
VIPUL CONSULTING,
F 9 / 440 , Keshav Marg Chitrakut Scheme,Jaipur
PH:91-0-93146-10438 ,0141-2440946
Mail:vipul8599@yahoo.com

NOTE:- ALL KIOSK & SHOPS 6MODULAR
SWITCH BOARD REQUIRED

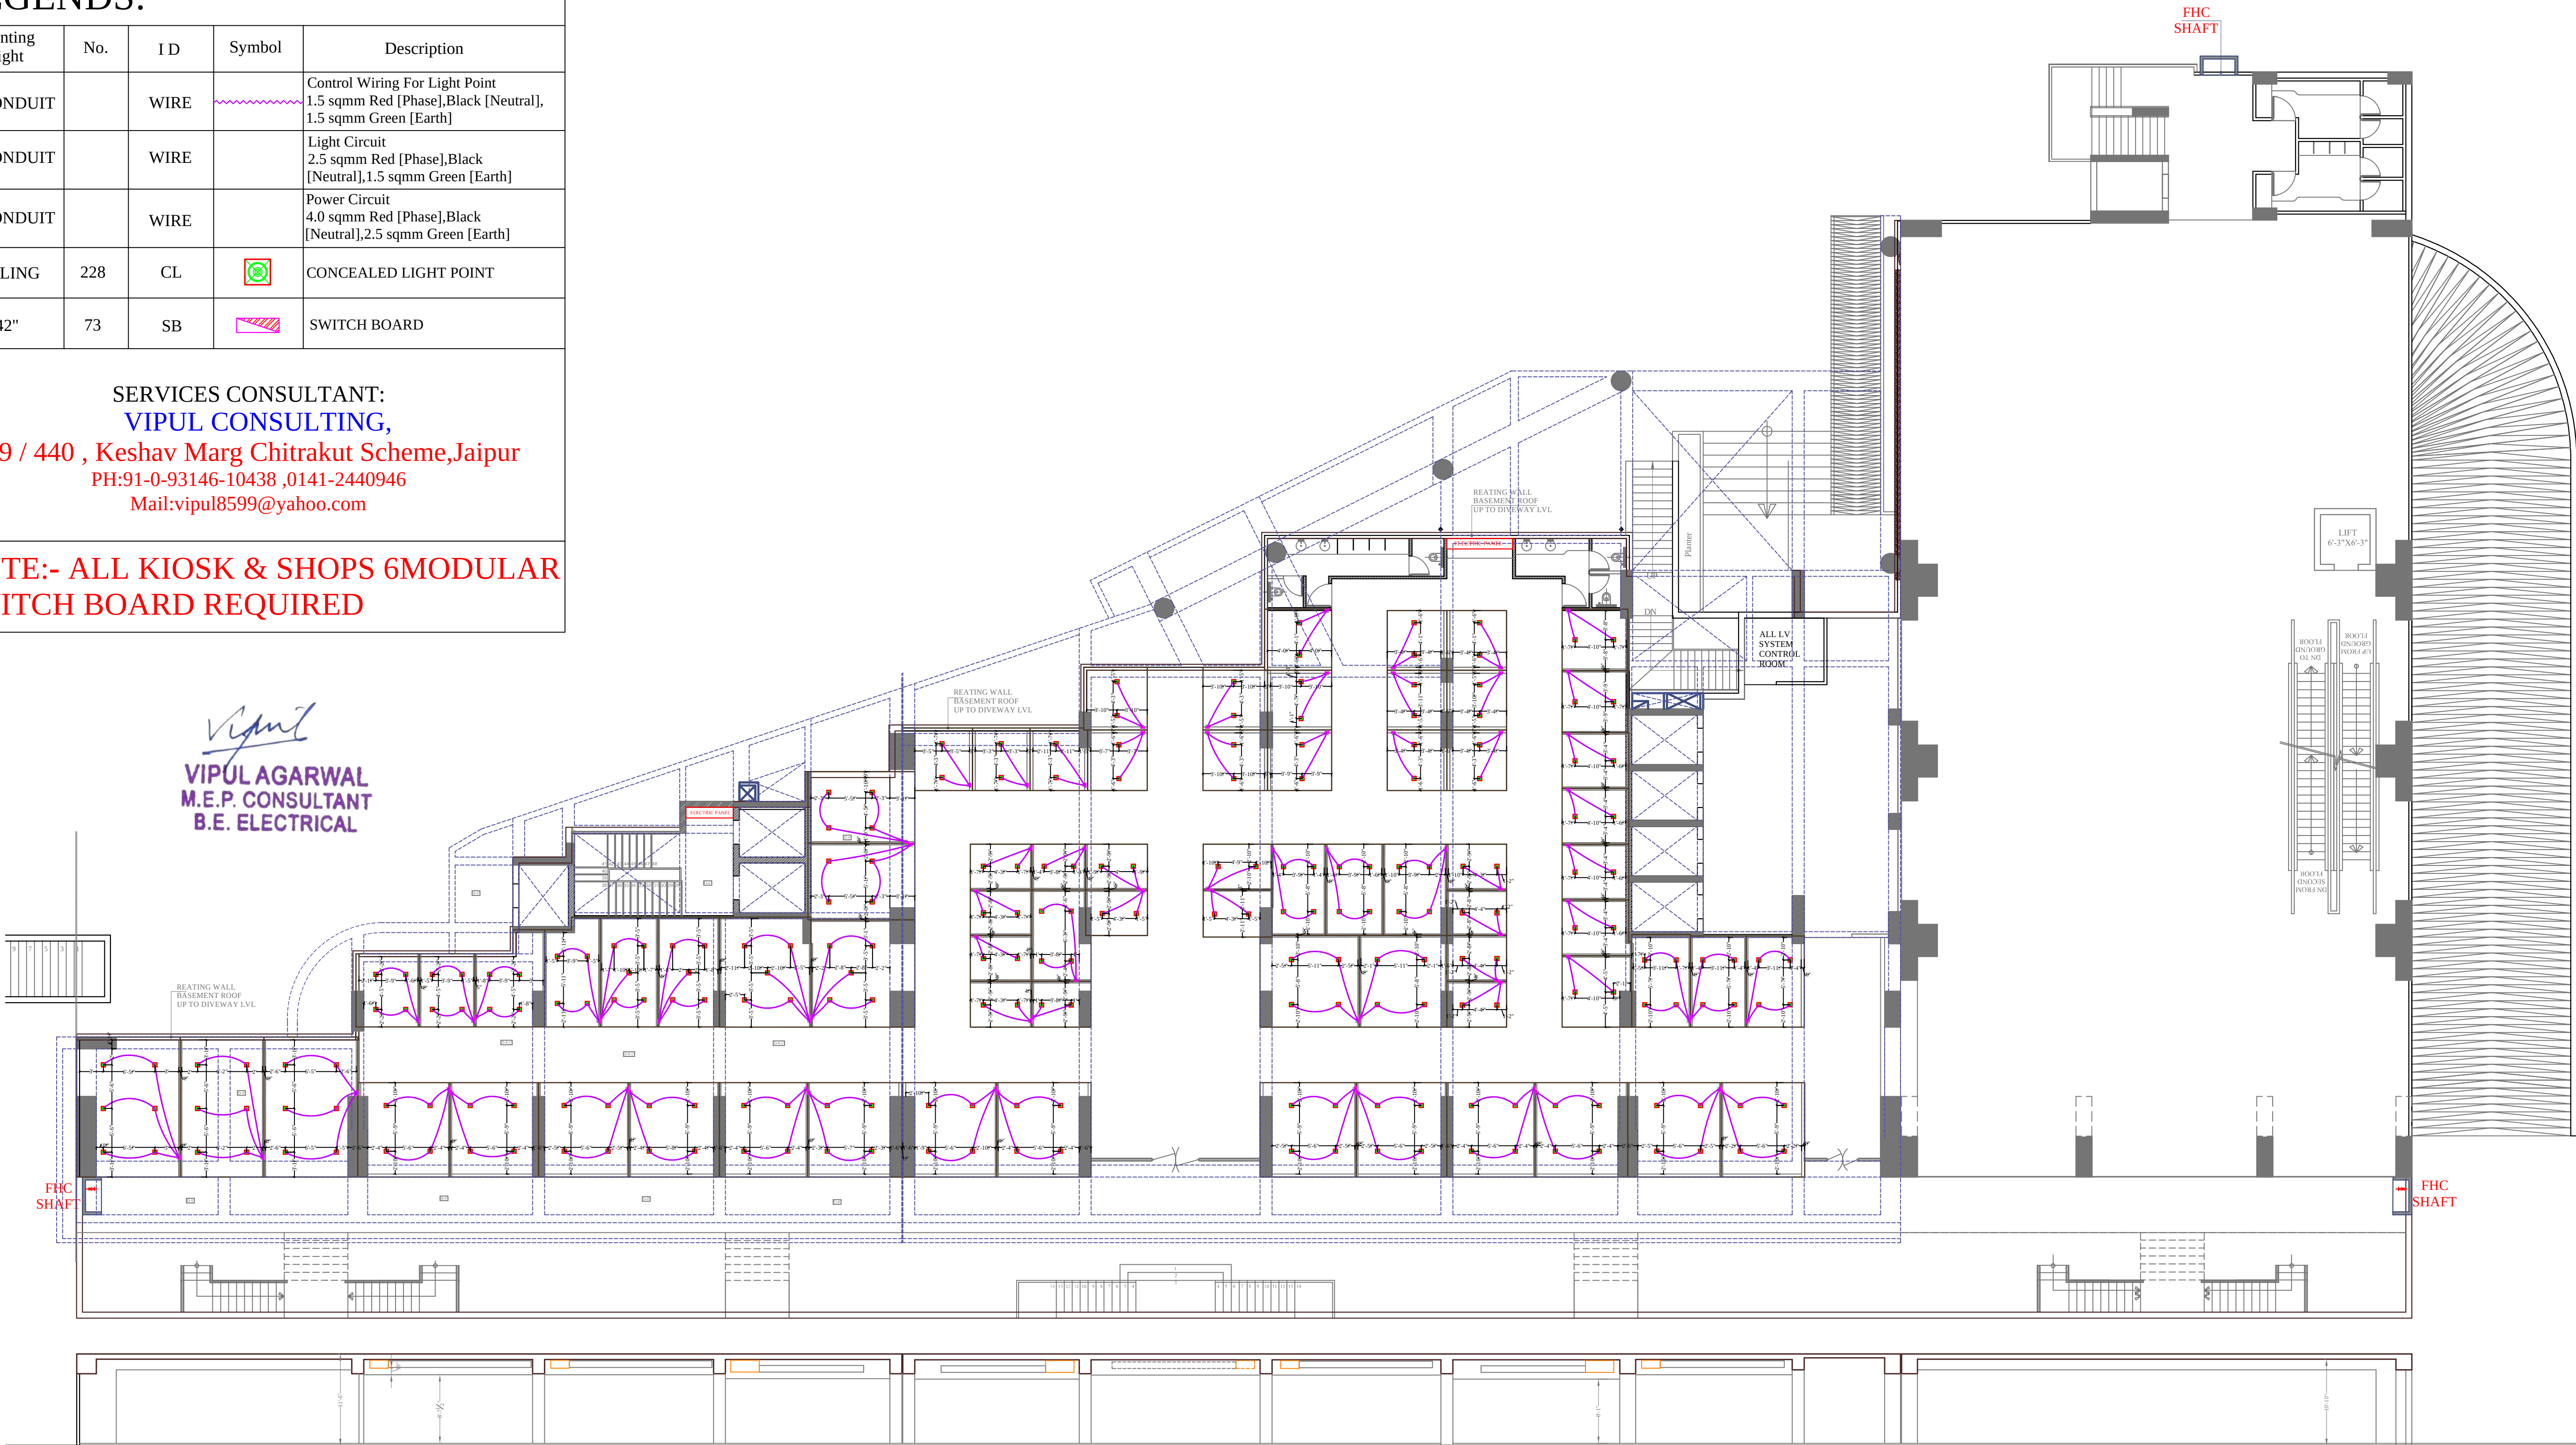


LEGENDS:


Mounting Height	No.	I D	Symbol	Description
IN CABLE TRAY			TV	RG6 CABLE FOR TV WIRING
IN CABLE TRAY			TEL	0.5MM 2 PAIR WIRE FOR TEL WIRING
IN CABLE TRAY				MCBDB ELECTRIC CABLE
IN CABLE TRAY			CCTV	3+1 COAXIAL WIRE FOR SECURITY CAMERA (C.C.T.V.)
+18"	73	SET		1No.Telephone Jack, 1No. TV Coaxial Jack, 1Nos. 6A Socket Controlled by 1No. 6A Switch & 1Nos. 16A 5Pin Socket Controlled by 1No. 16A Switch
+60"	73	MCB DB		MCB DISTRIBUTION BOARD
CEILING	11	CCTV		CEILING CCTV CAMERA


SERVICES CONSULTANT:
VIPUL CONSULTING,
F 9 / 440 , Keshav Marg Chitrakut Scheme,Jaipur
PH:91-0-93146-10438 ,0141-2440946
Mail:vipul8599@yahoo.com

LEGENDS:

Mounting Height	Symbol	Description
CEILING		CEILING SUSPENDED ELECTRIC CABLE TRAY WIDE:-18"
CEILING		CEILING SUSPENDED ELECTRIC CABLE TRAY WIDE:-12"
CEILING		CEILING SUSPENDED ELECTRIC CABLE TRAY WIDE:-9"
CEILING		CEILING SUSPENDED LV CABLE TRAY WIDE:-18"
CEILING		CEILING SUSPENDED LV CABLE TRAY WIDE:-15"
CEILING		CEILING SUSPENDED LV CABLE TRAY WIDE:-12"
CEILING		CEILING SUSPENDED LV CABLE TRAY WIDE:-9"

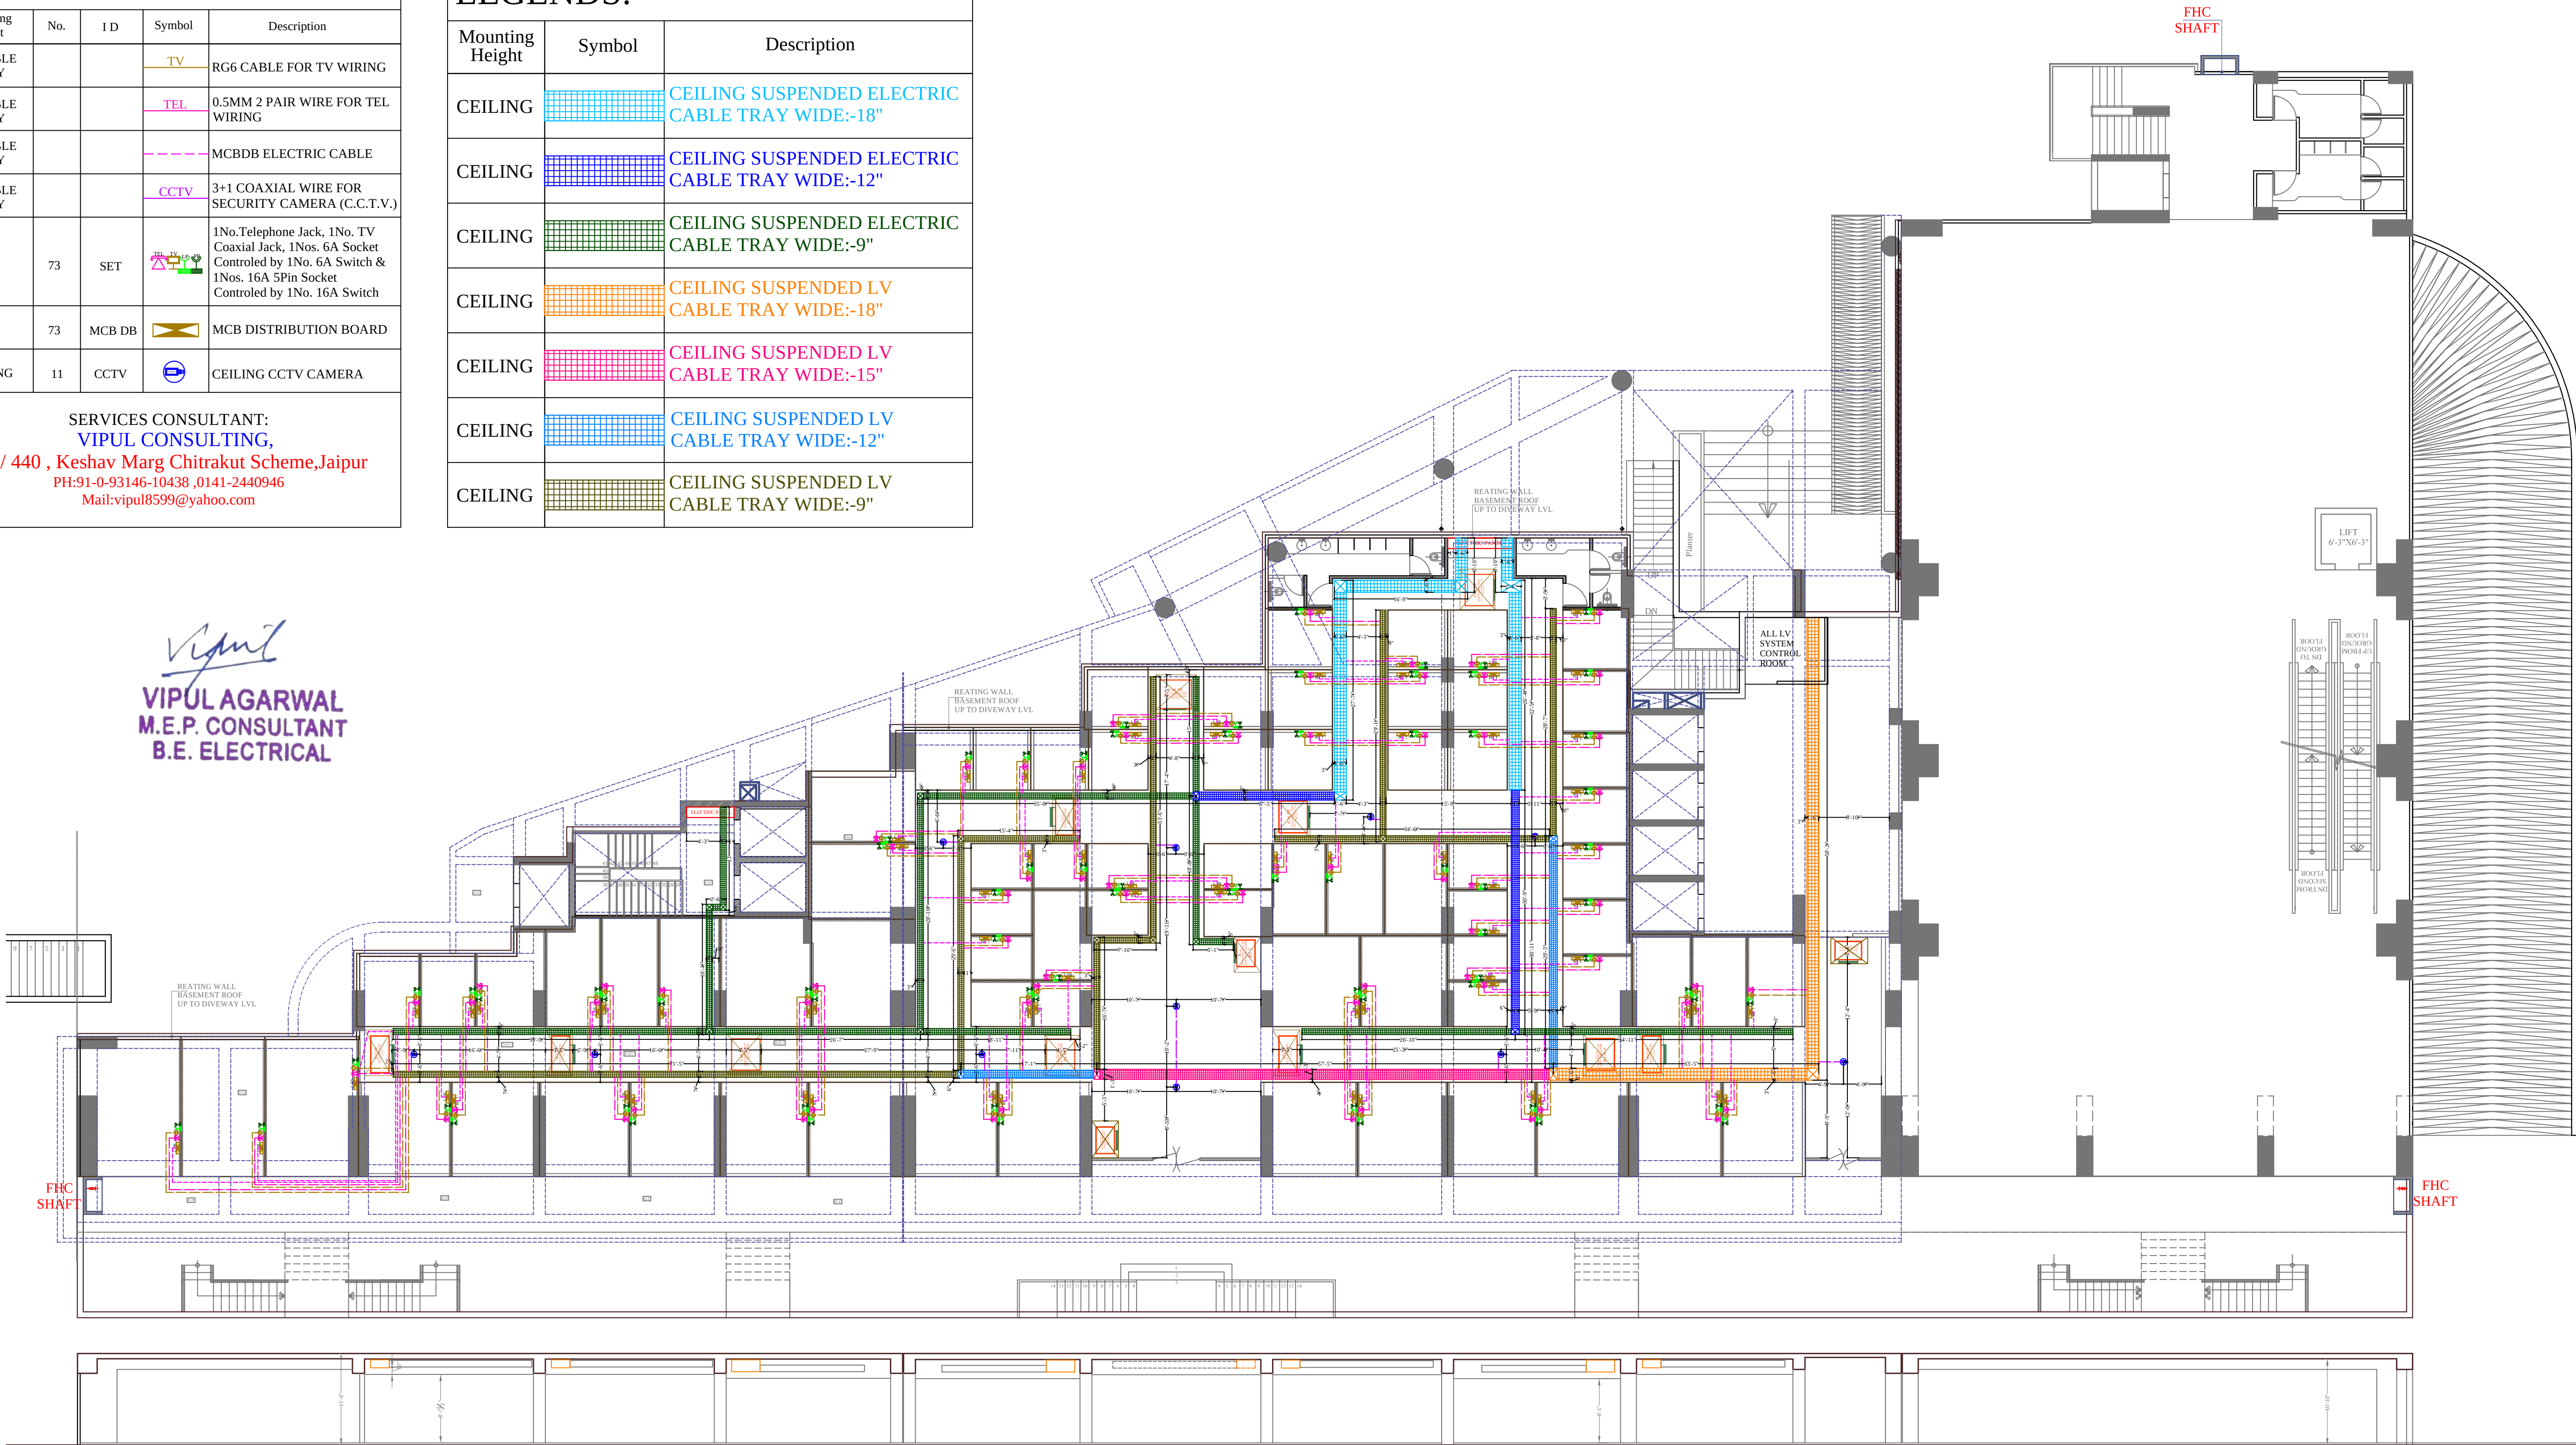

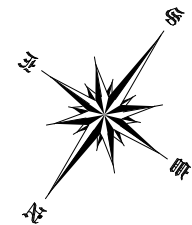CLIENT :	PROJECT:	ARCHITECTS :	NAME OF DRAWING:	DRAWN BY:	PROJECT NO. :	NORTH:
ANUKAMPA AVAS VIKAS LLP	PROPOSED MIX USE BUILDING PLOT NO. S-01, NEAR SHYAM NAGAR, AJMER ROAD JAIPUR	des^{ign}graphite studio GRAPHITE DESIGN STUDIO ARCHITECTS, INTERIOR DESIGNERS, PLANNERS 68, Janak Puri -1st, Imliwala phatak, Opp Jain Mandir, Jaipur CONTACT NO. +91-9928334414, 0141-2593414 email: studiosgraphite@gmail.com Website : www.graphitedesignstudio.com	LOWER GROUND FLOOR CCTV, TV, TELEPHONE, DB CABLE & CABLE TRAY PLAN	PAWAN	302019ANUK00100	
				CKD. BY:	SCALE :	DRAWING NO. :
				SANJAY		
				APPROVED BY:	DATE :	REV.:
				VIPUL AGARWAL	26-11-19	00
						MEP/AS/L.F.G./CT-06

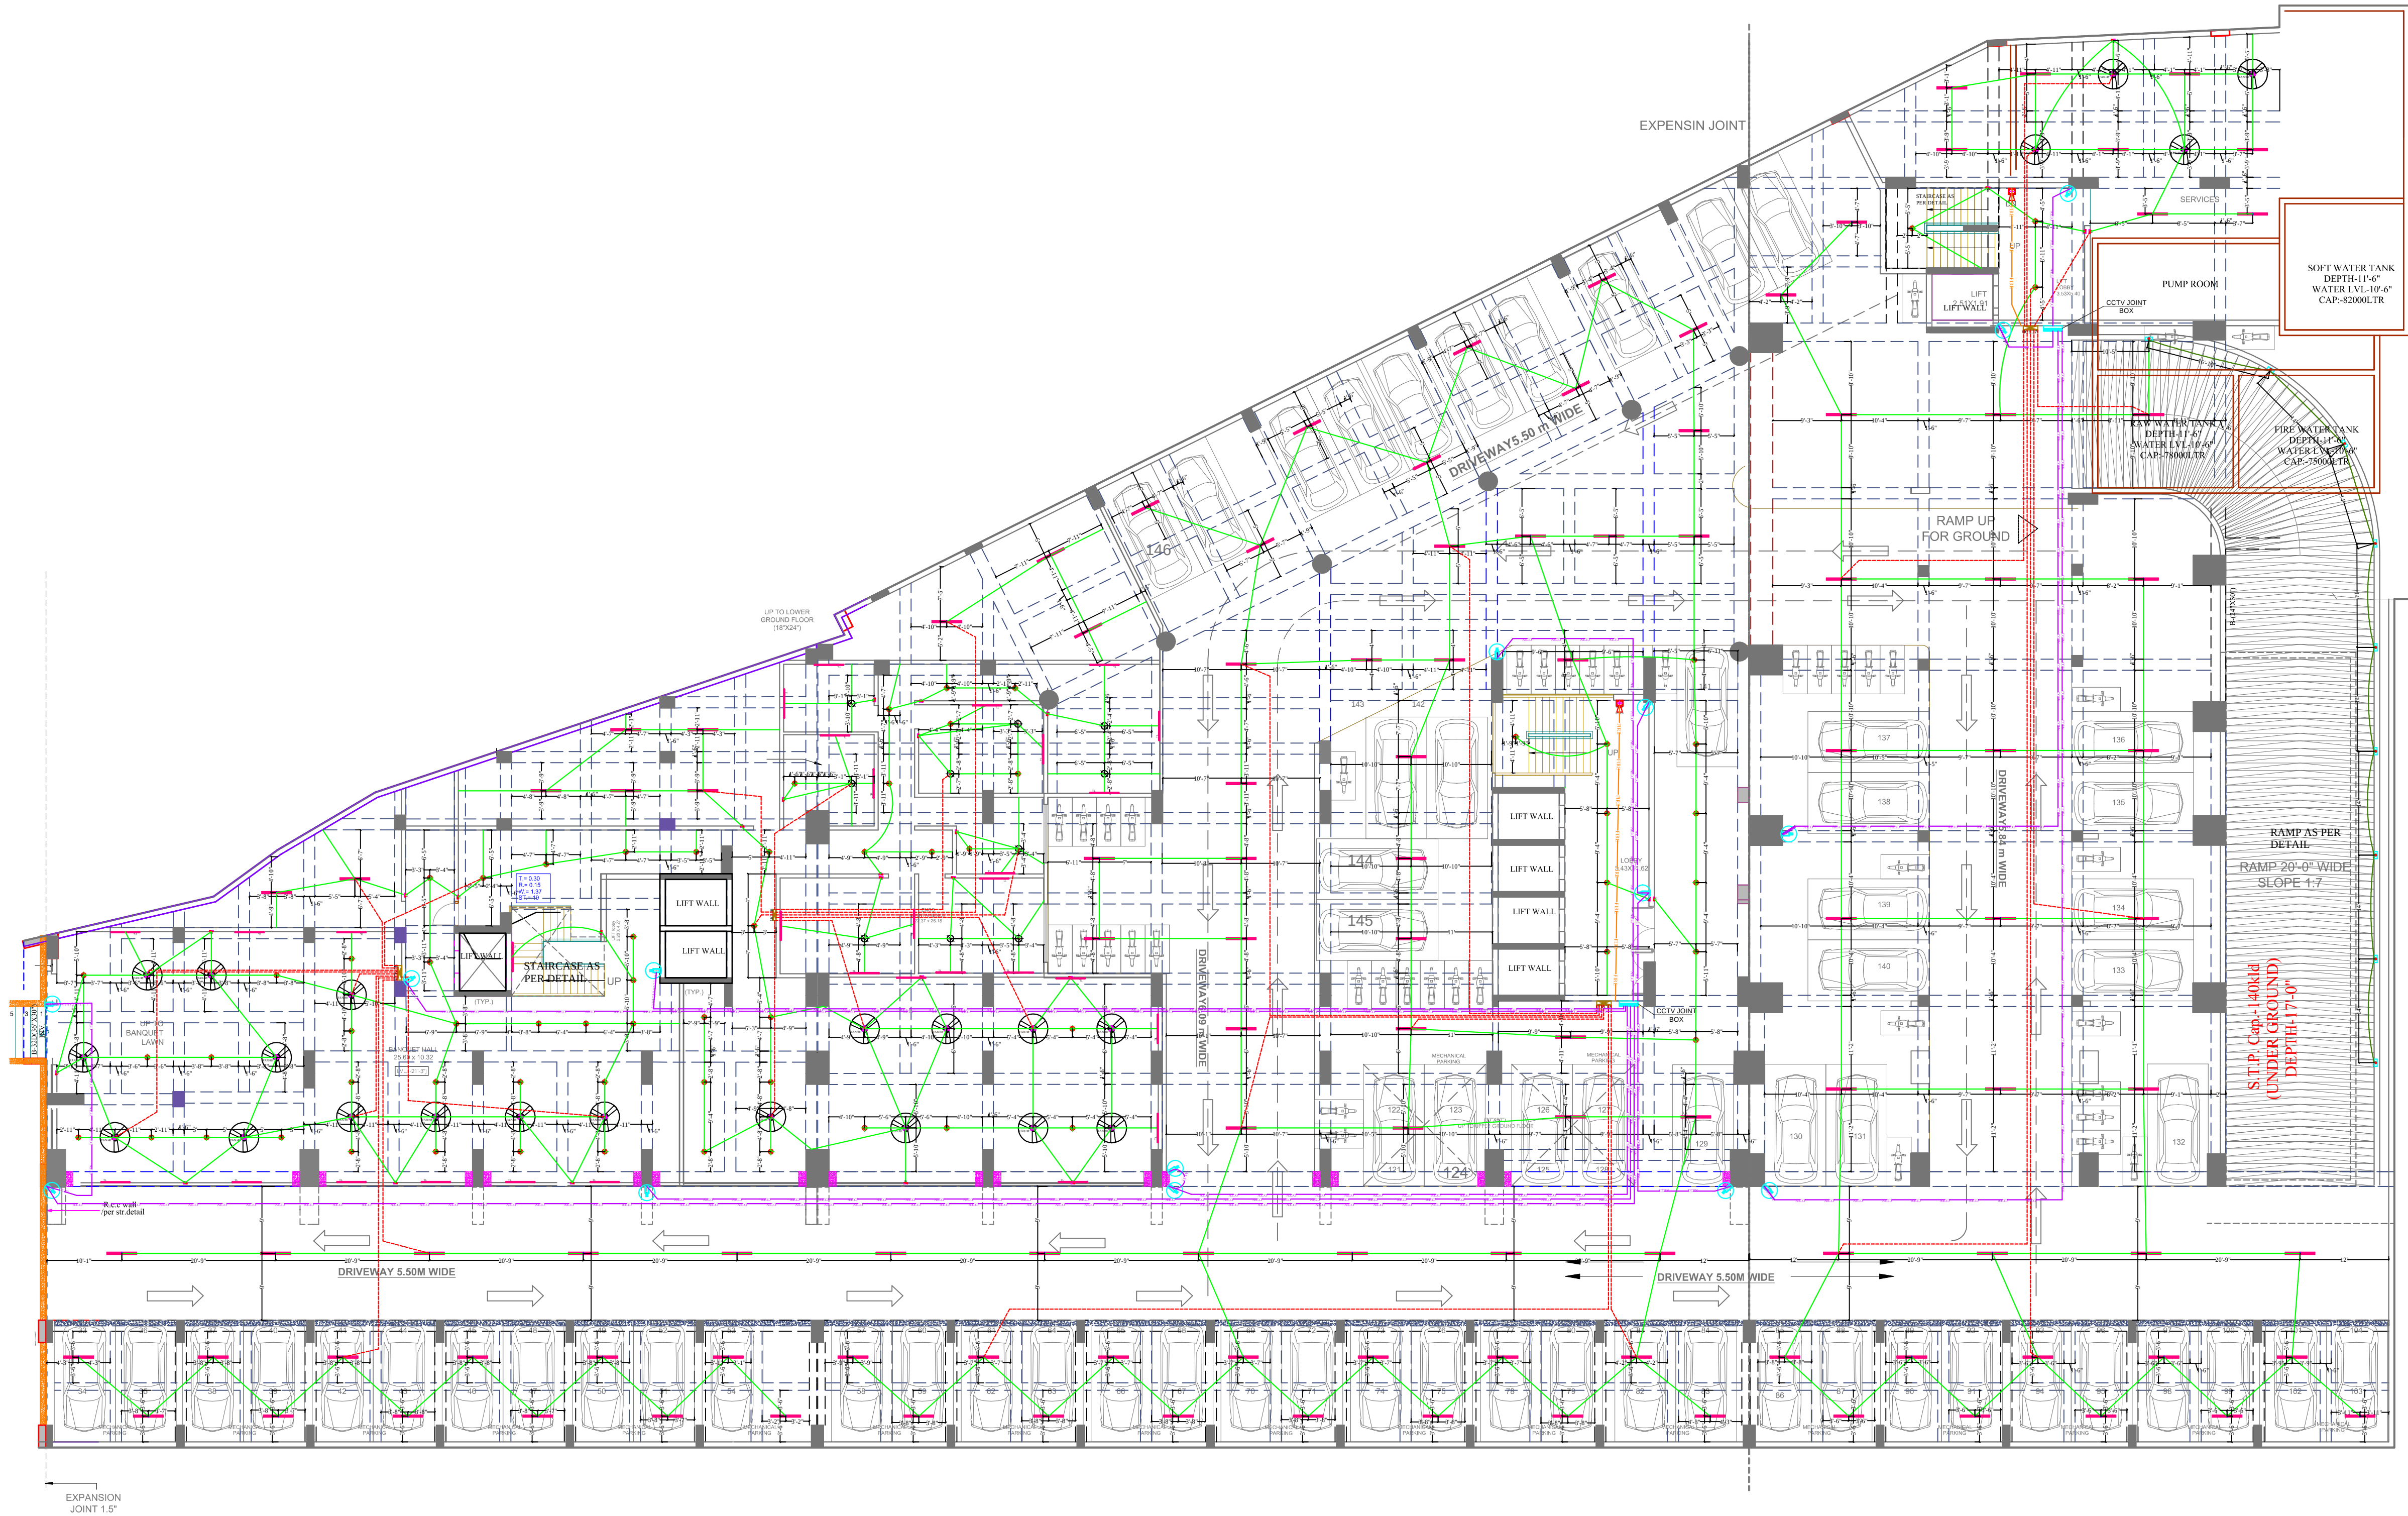


LEGENDS:				
Mounting Height	No.	1 D	Symbol	Description
IN FLOOR		CONDUIT		Rigid PVC 25mm dia. Conduit / 1.5 sqmm Wire For Light Points
IN RCC SLAB		CONDUIT		Rigid PVC 25mm dia. Conduit / 1.5 sqmm Wire For Light Points
IN RCC SLAB		CONDUIT		Rigid PVC 25mm dia. Conduit / 2.5 sqmm Wire For Light Circuits
IN RCC SLAB		CONDUIT		Rigid PVC 25mm dia. Conduit / 4.00 sqmm Wire For Power Circuits
IN RCC SLAB		CONDUIT		Submain Wire to DB From Main Panel on Ground Floor in 1 nos. 32 mm dia Conduits
IN RCC SLAB		CONDUIT		Rigid PVC 25mm dia. Conduit / 3+1 Coaxial Wire For Security Camera (C.C.T.V.).
IN RCC SLAB		CONDUIT		Rigid PVC Conduit 25mm/ 2X1.5 sq. mm Copper Wire for Fire Alarm
CEILING	23	FAN/48"		CEILING FAN 48"
CEILING	10	FB		FAN BOX
CEILING	118	TL/C		LED CEILING TUBE LIGHT MAKE:- SYSKA LED CAT NO.:- SSK-TS-20W
+90"	31	TL/W		Led Wall Tube Light Make:- Syska Led Cat no.- SSK-TS-20W
CEILING	66	DL		Led 6" Down Lighter 20W (Surface Mounted) Make:- Syska Led Cat no.:- SDL-15W GLD 6.5K/4K
+42"	28	SB		SWITCH BOARD
+18"	09	FL		FOOT LIGHT
+60"	04	MCB DB		MCB DISTRIBUTION BOARD
+90"	03	CCTV		WALL MOUNTED CCTV CAMERA

Vipul
VIPUL AGARWAL
M.E.P. CONSULTANT
B.E. ELECTRICAL

CLIENT :		ARCHITECTS :		PROJECT:		NORTH:	
ANUKAMPA AVAS VIKAS LLP		des g n studio GRAPHITE DESIGN STUDIO ARCHITECTS, INTERIOR DESIGNERS, PLANNERS 68, Janak Puri -1st, Imliwala phatak, Opp Jain Mandir, Jaipur CONTACT NO. +91-9928334414, 0141-2593414 email: studiosgraphite@gmail.com Website : www.graphitedesignstudio.com		PROPOSED MIX USE BUILDING PLOT NO. S-01, NEAR SHYAM NAGAR, AJMER ROAD JAIPUR			
PROPOSED MIX USE BUILDING PLOT NO. S-01, NEAR SHYAM NAGAR, AJMER ROAD JAIPUR		SERVICES CONSULTANT: VIPUL CONSULTING, F 9 / 440 , Keshav Marg Chitrakut Scheme,Jaipur PH:91-0-93146-10438 ,0141-2440946 Mail:vipul8599@yahoo.com DATE:-30-04-2019		NAME OF DRAWING: BASEMENT FLOOR RIGHT SIDE PART ELE. & LV CONDUIT PLAN		PROJECT NO. : 302019ANUK00100	DATE : 30-04-2019
				DRAWN BY: RAJENDER	CKD. BY: SANJAY	SCALE :	REV NO./DATE : R-00/
				APPROVED BY: VIPUL AGARWAL		DRAWING NO. : MEP/ANKU/B.F./LSP/ELE./LV-01	

THIS DRAWING IS THE PROPERTY OF GRAPHITE DESIGN STUDIO PVT. LTD. , JAIPUR IT SHALL NOT BE COPIED OR USED WITHOUT THEIR WRITTEN PERMISSION NOR MADE KNOWN TO A THIRD PARTY. THE INFORMATION IS ISSUED ON THE UNDERSTANDING THAT NO PART THEREOF SHALL BE DUPLICATED FOR THE PURPOSE OTHER THAN THE EXPRESSED PURPOSE.

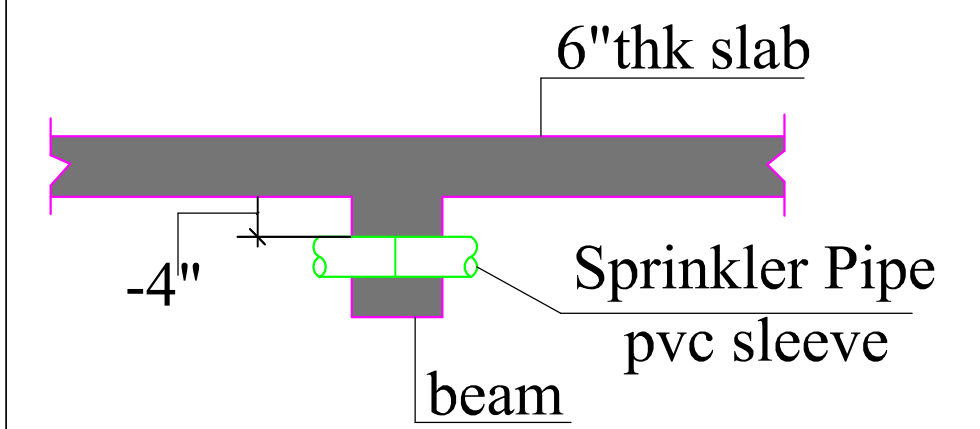


Typical Section of Sleeve
in Beam for Sprinkler Pipe/ Lvl
-4" below roof bottom

LEGENDS:

Qty.	Symbol	Description
53		100 MM DIA. SLEEVE
05		150 MM DIA. SLEEVE

Vipul
VIPUL AGARWAL
M.E.P. CONSULTANT
B.E. ELECTRICAL

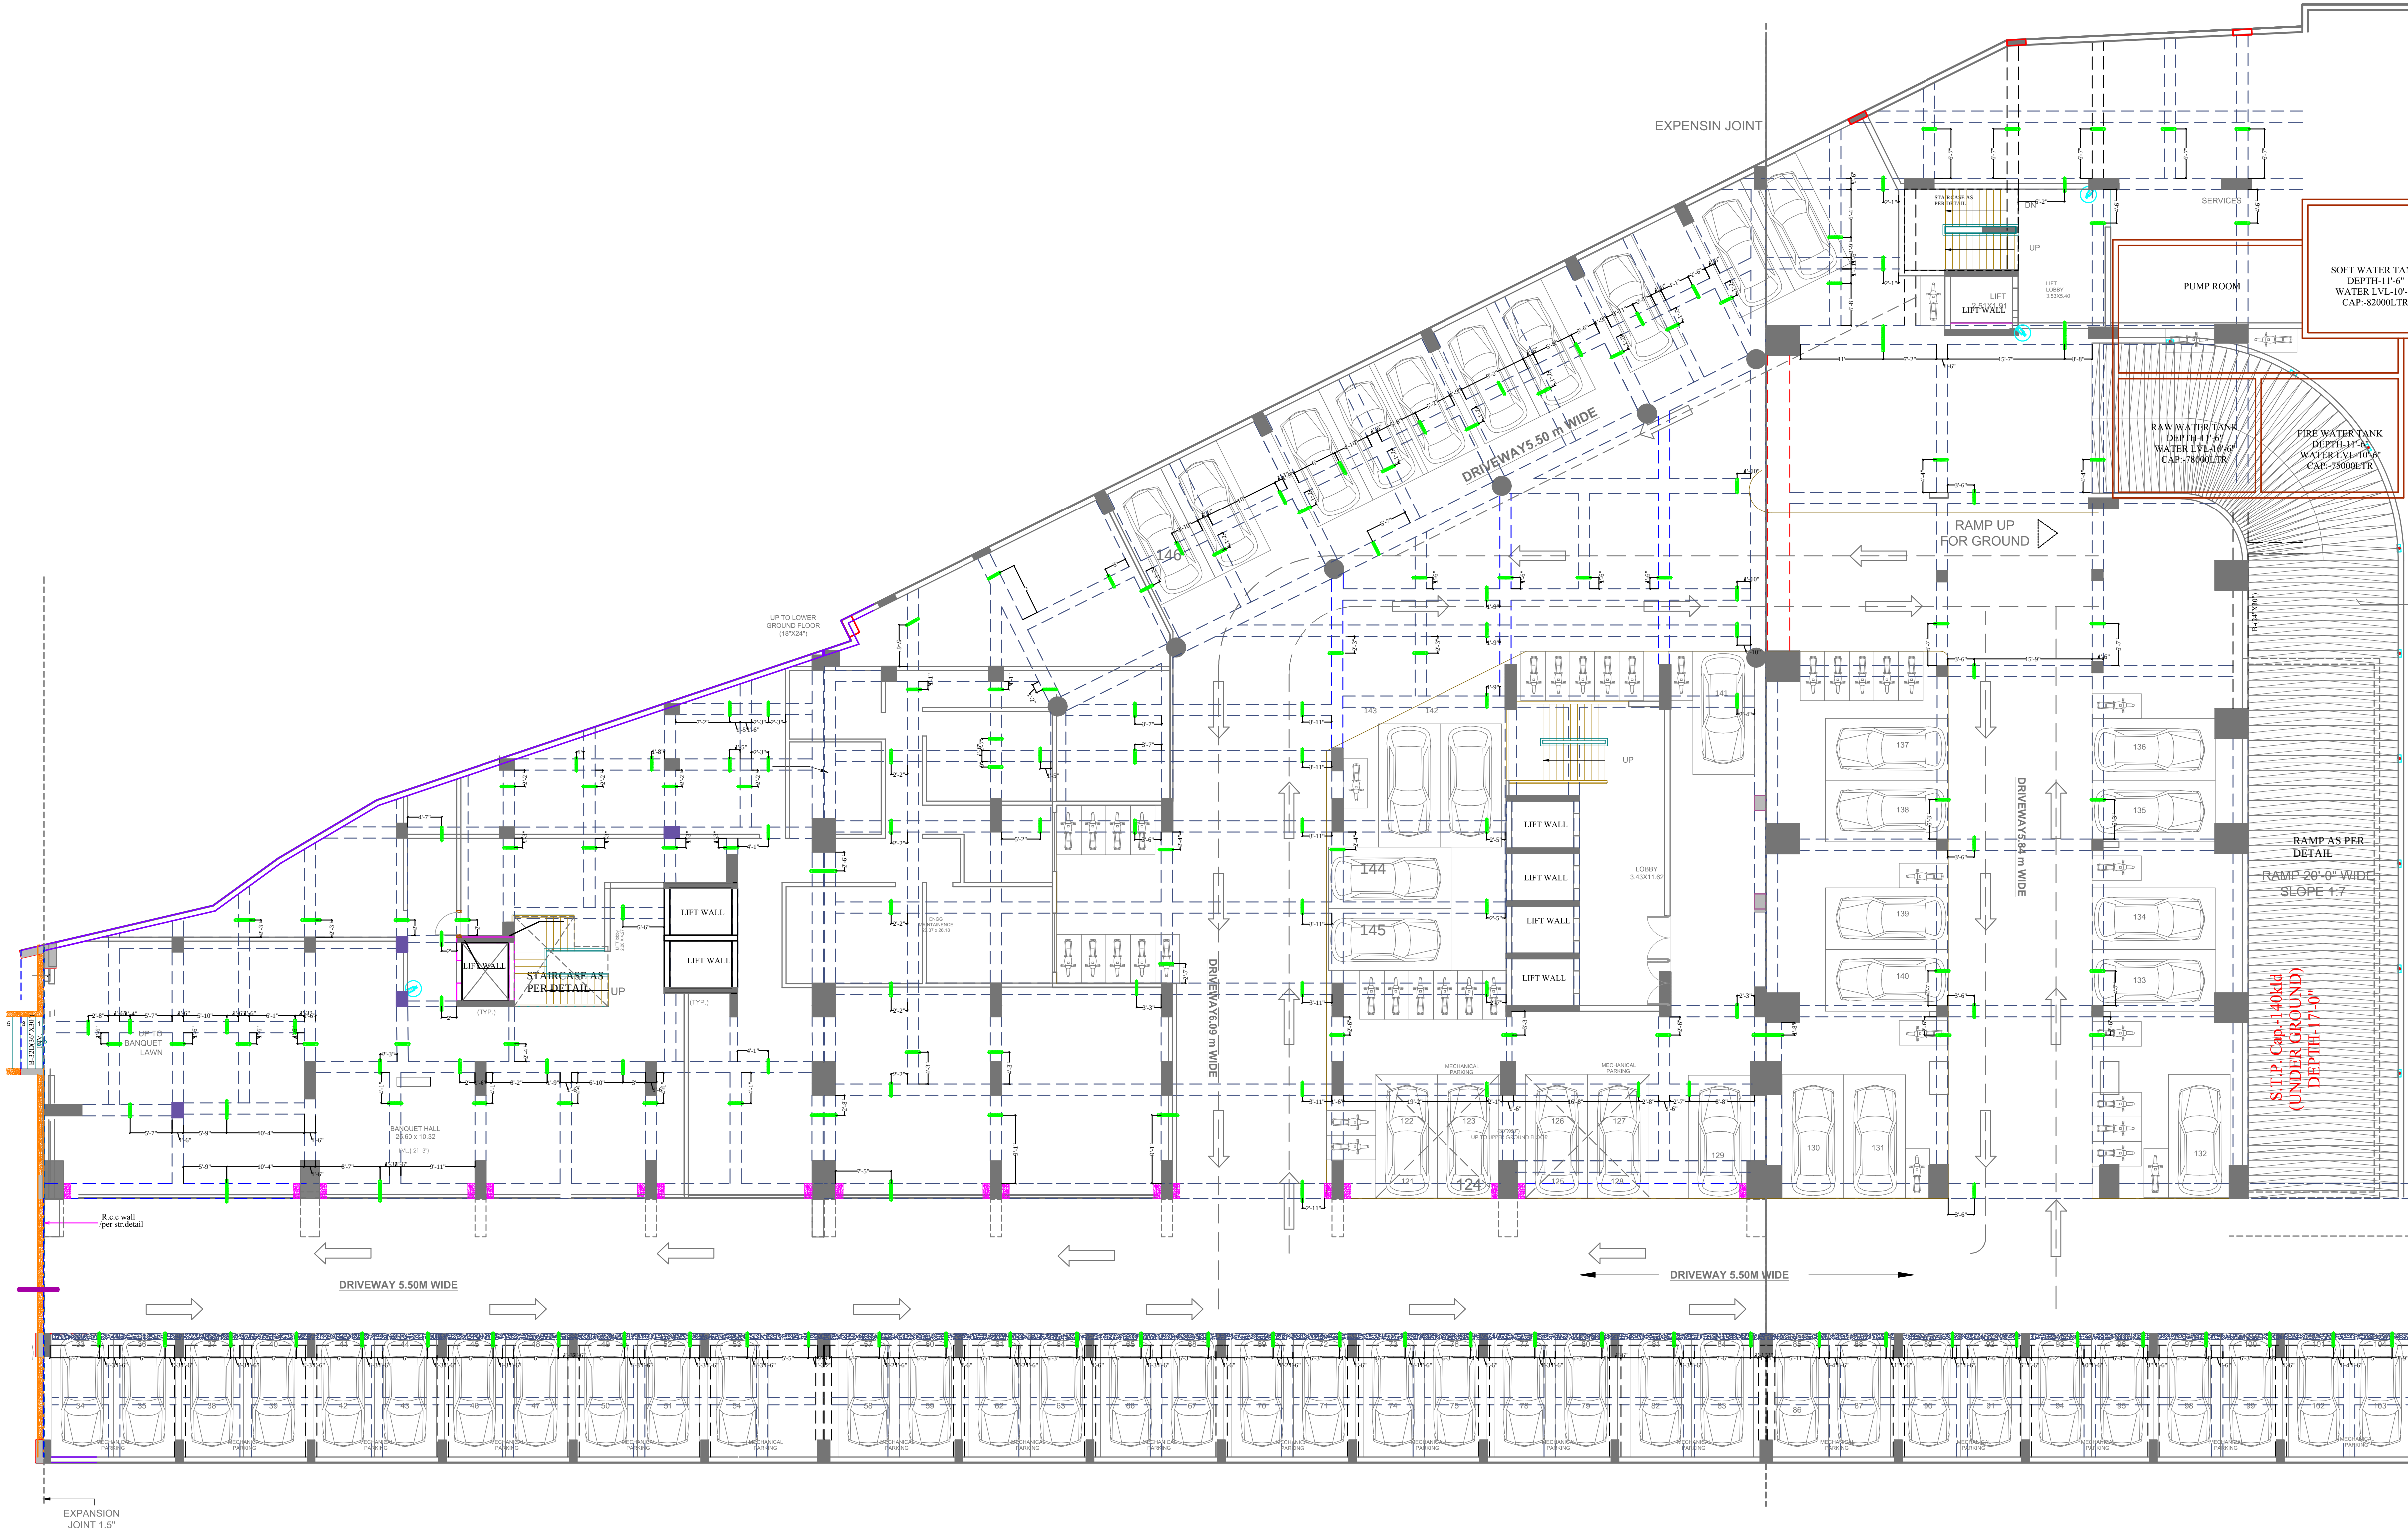

CLIENT :

ANUKAMPA AVAS
VIKAS LLP

PROPOSED MIX USE BUILDING
PLOT NO. S-01, NEAR SHYAM
NAGAR, AJMER
ROAD JAIPUR

ARCHITECTS :

desig
n studio

GRAPHITE DESIGN STUDIO
ARCHITECTS, INTERIOR DESIGNERS, PLANNERS
68, Janak Puri -1st, Imliwala phatak, Opp Jain Mandir, Jaipur
CONTACT NO. +91-9928334414, 0141-2593414
email: studiosgraphite@gmail.com
Website : www.graphitedesignstudio.com

SERVICES CONSULTANT:
VIPUL CONSULTING,

F 9 / 440 , Keshav Marg Chitrakut Scheme,Jaipur
PH:91-0-93146-10438 ,0141-2440946 Mail:vipul8599@yahoo.com
DATE:-30-04-2019

PROJECT: PROPOSED MIX USE BUILDING
PLOT NO. S-01, NEAR SHYAM NAGAR, AJMER
ROAD JAIPUR

NAME OF DRAWING:
BASEMENT FLOOR RIGHT SIDE PART
SPRINKLER SLEEVE PLAN

DRAWN BY:


RAJENDER

CKD. BY:

SANJAY

APPROVED BY:
VIPUL AGARWAL

NORTH:

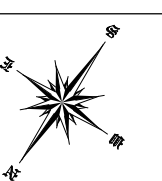

PROJECT NO. :

302019ANUK00100

SCALE :

DATE :

30-04-2019

REV NO./DATE :

R-00/

DRAWING NO. :


MEP/ANKU/B.F./LSP/ELE./LV-01

THIS DRAWING IS THE PROPERTY OF GRAPHITE DESIGN STUDIO PVT. LTD., JAIPUR. IT SHALL NOT BE COPIED OR USED WITHOUT THEIR WRITTEN PERMISSION NOR MADE KNOWN TO A THIRD PARTY. THE INFORMATION IS ISSUED ON THE UNDERSTANDING THAT NO PART THEREOF SHALL BE DUPLICATED FOR THE PURPOSE OTHER THAN THE EXPRESSED PURPOSE.

LEGENDS:

Mounting Height	No.	I D	Symbol	Description
IN RCC SLAB		CONDUIT		Rigid PVC 25mm dia. Conduit /1.5 sqmm Wire For Light Points
IN RCC SLAB		CONDUIT		Rigid PVC 25mm dia. Conduit /2.5 sqmm Wire For Light Circuits
IN RCC SLAB		CONDUIT		Rigid PVC 25mm dia. Conduit / 4.00 sqmm Wire For Power Circuits
IN RCC SLAB		CONDUIT		Submain Wire to DB From Main Panel on Ground Floor in 1 nos. 32 mm dia Conduits
CEILING	84	FAN/48"		CEILING FAN 48"
+90"	73	TL/W		Led Wall Tube Light Make:- Syska Led Cat no.- SSK-T5-20W
+90"	09	GL		WALL BRACKETS AS DESIGN FOR GANESH LIGHT
CEILING	126	DL		Led 6" Down Lighter 20W (Surface Mounted) Make:- Syska Led Cat no:- SDL-15W GLD 6.5K/4K
+18"	09	SET		1Nos. 6A Socket Controlled by 1No. 6A Switch ,1Nos. 16A 5Pin Socket Controlled by 1No. 16A Switch, 1No.Telephone jack & 1No. TV Coaxial Jack
+42"	27	SB		SWITCH BOARD
+60"	09	MCB DB		MCB DISTRIBUTION BOARD

SERVICES CONSULTANT:
VIPUL CONSULTING,
F 9 / 440 , Keshav Marg Chitrakut Scheme,Jaipur
PH:91-0-93146-10438 ,0141-2440946 Mail:vipul8599@yahoo.com

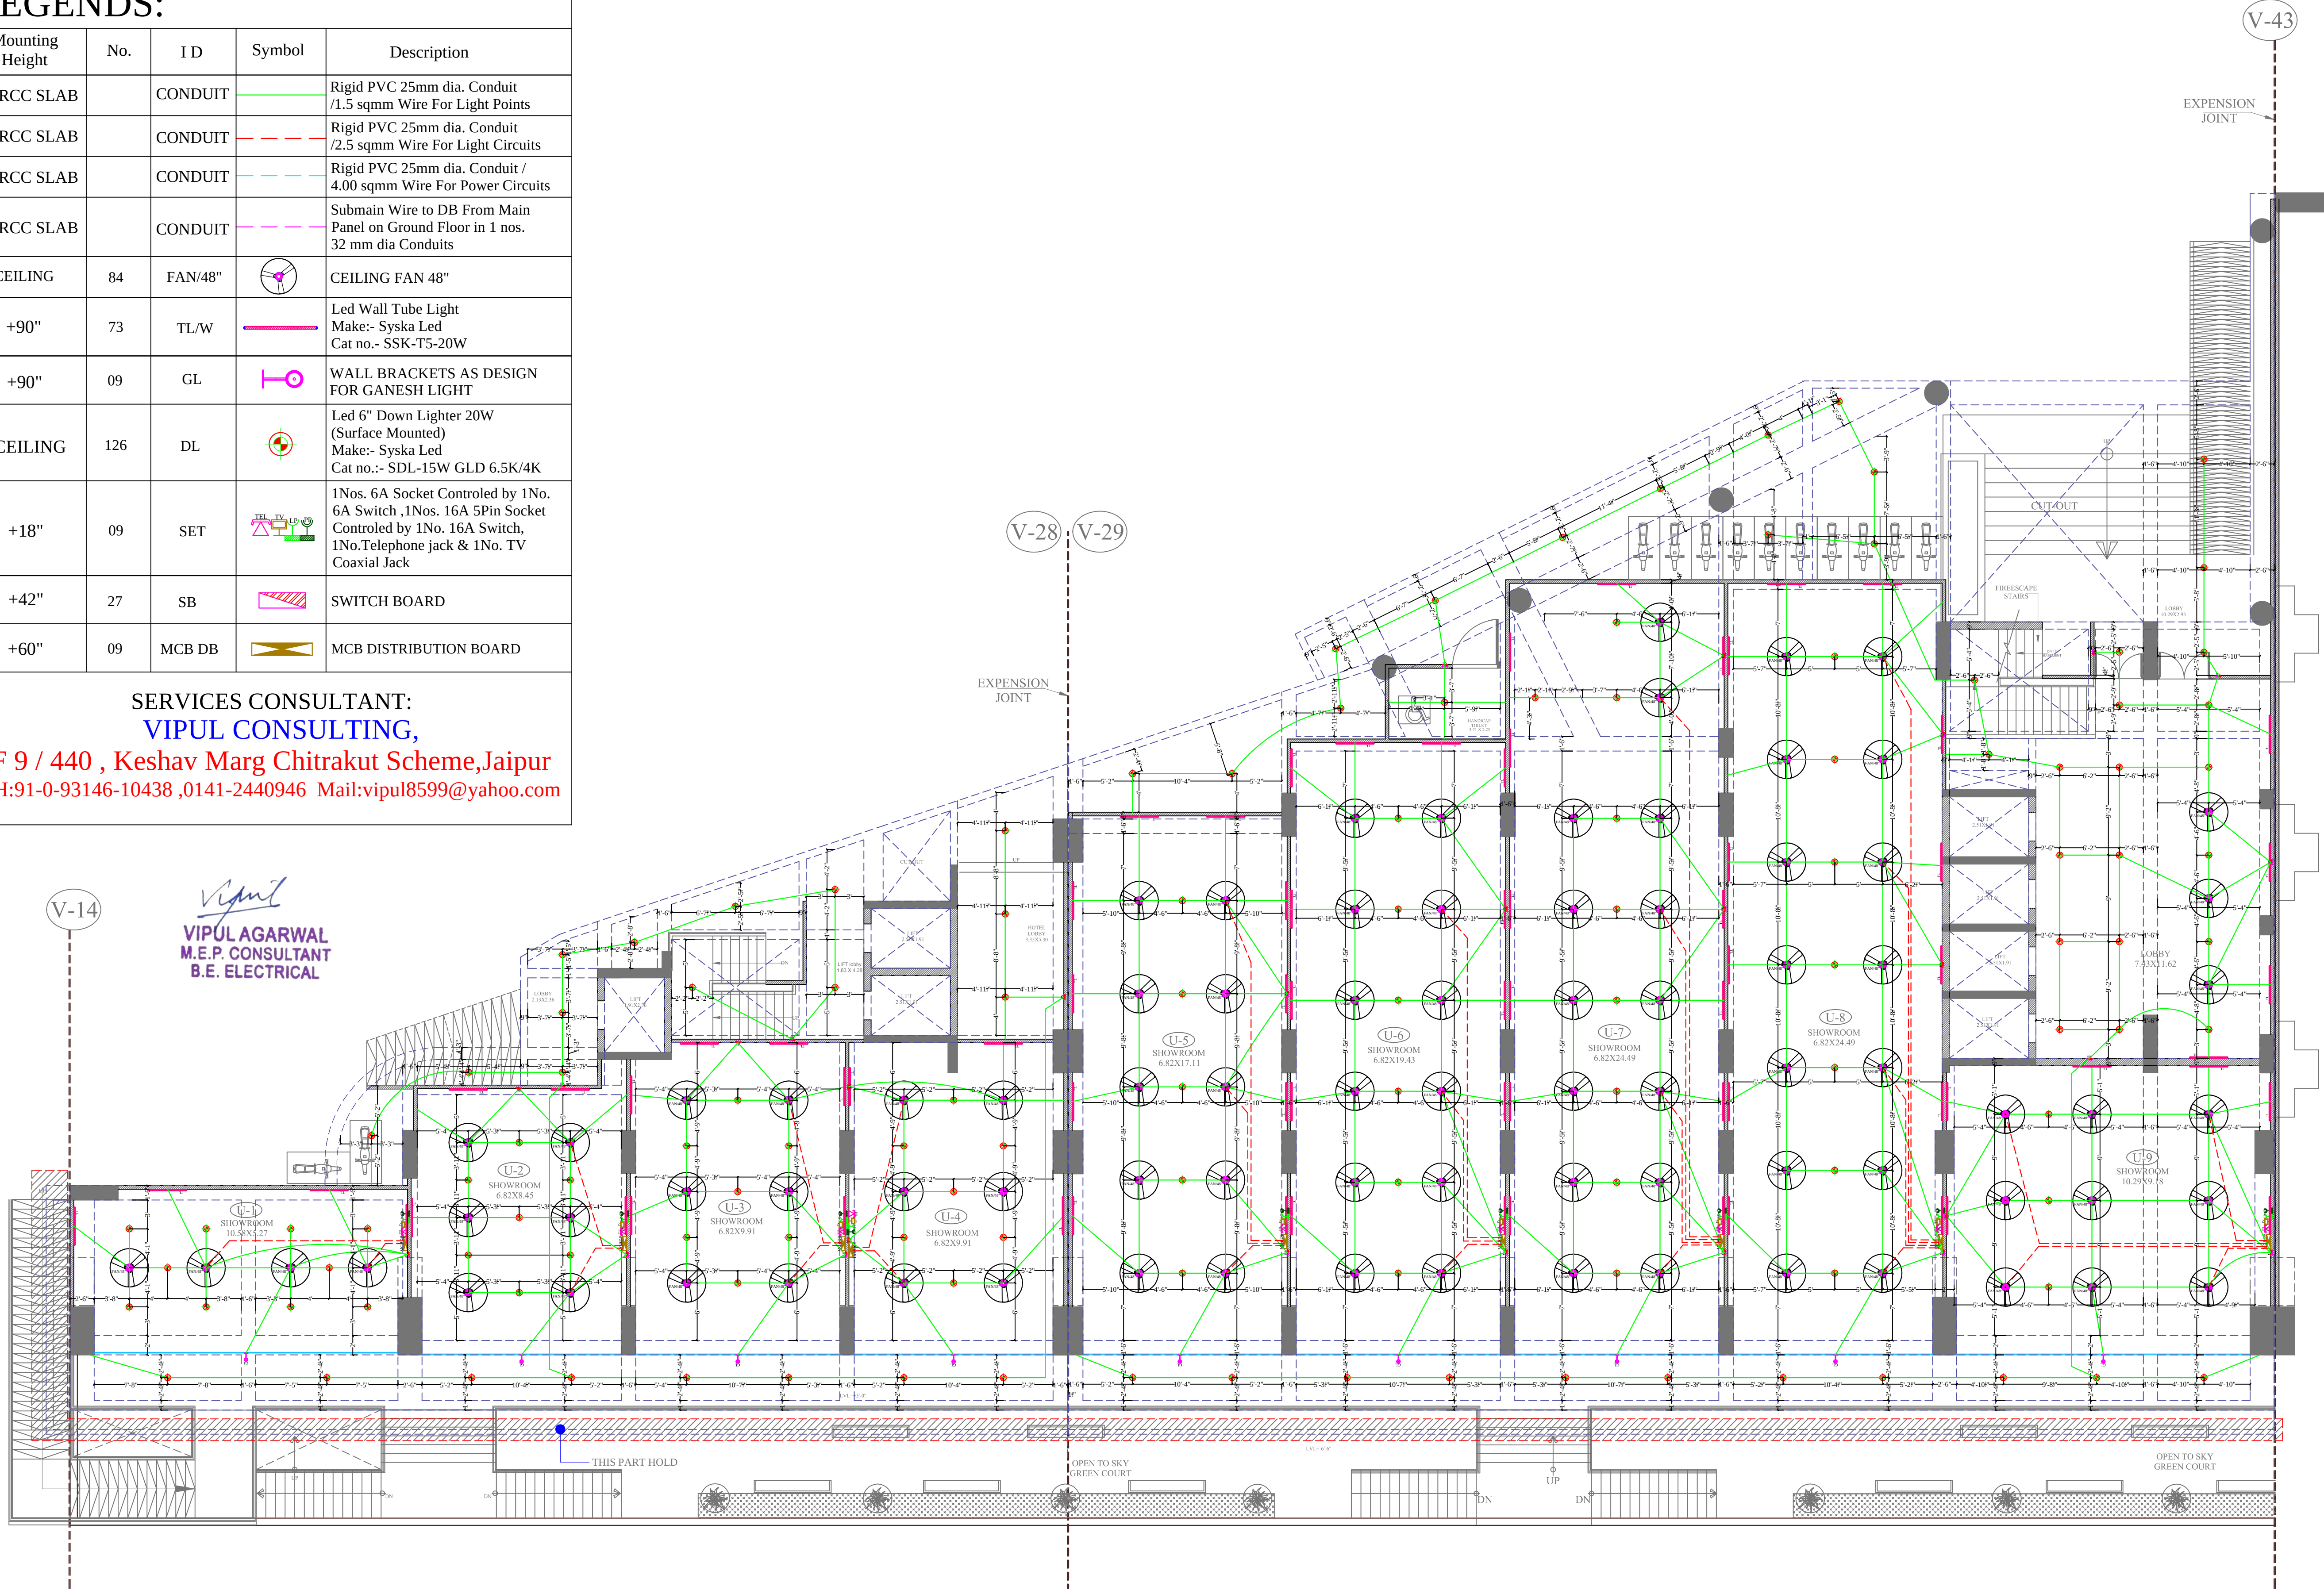

CLIENT :	PROJECT:	ARCHITECTS :	NAME OF DRAWING:	DRAWN BY:	PROJECT NO. :	NORTH:
ANUKAMPA AVAS VIKAS LLP	PROPOSED MIX USE BUILDING PLOT NO. S-01, NEAR SHYAM NAGAR, AJMER ROAD JAIPUR	 GRAPHITE DESIGN STUDIO ARCHITECTS, INTERIOR DESIGNERS, PLANNERS 68, Janak Puri -1st, Imliwala phatak, Opp Jain Mandir, Jaipur CONTACT NO. +91-9928334414, 0141-2593414 email: studiosgraphite@gmail.com Website : www.graphitedesignstudio.com	UPPER GROUND FLOOR (GRID NO:- V-14 TO V44) ELECTRIC CONDUIT PLAN	PAWAN	302019ANUK00100	
				CKD. BY:	SCALE :	DRAWING NO. :
				SANJAY	DATE :	REV.:
				APPROVED BY:	02-07-19	00
				VIPUL AGARWAL		MEP/AS/U.F.G./ELE.-01