

VIPUL CONSULTING

CHITRAKUT SCHEME, JAIPUR

E MAIL: vipu18599@yahoo.com

WONDER WOM

VIVEK CHORDIA PROPRIETER

PROPOSED PRESIDENTIAL DINNER

--	--

MAIN DISTRIBUTION PANEL

SINGLE LINE DIAGRAM



10-02-2023

VICKY YADDA

--	--





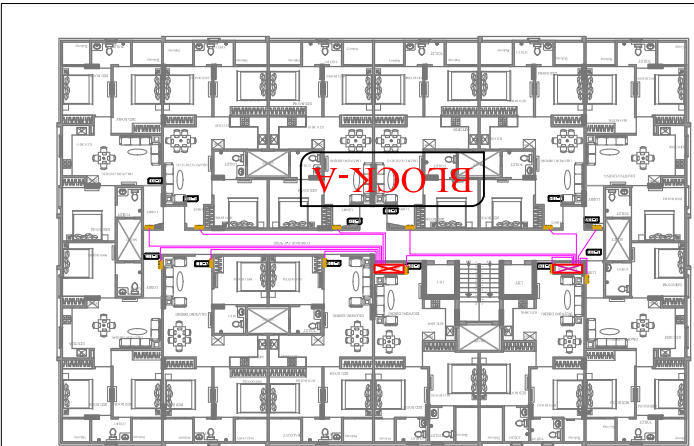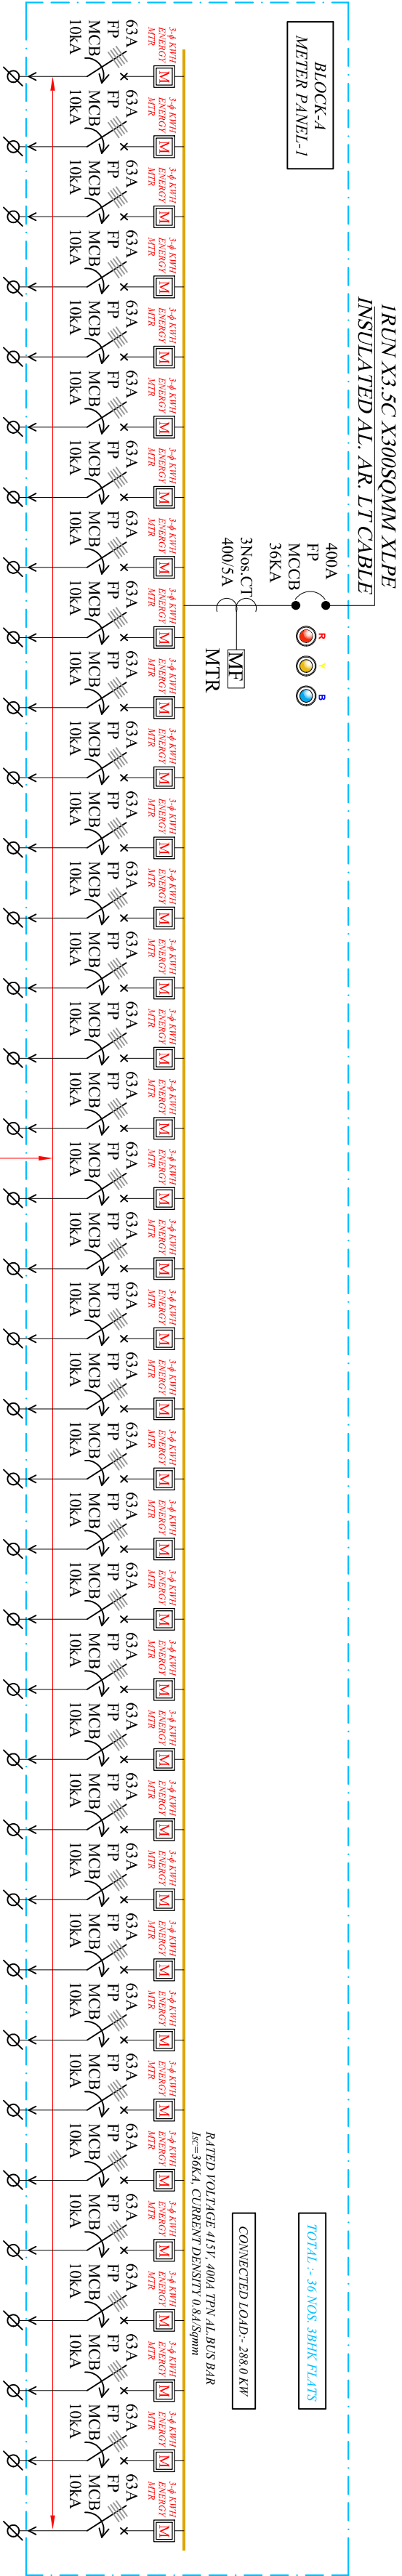

SERVICES CONSULTANT:
VIPUL CONSULTING
F-9-440, KESHAV MARG,
CHITRAKUT SCHEME, JAIPUR
PH:93146-10438, 2440946
E MAIL: vipul8599@yahoo.com

PROJECT: WONDER HOMES

PROMOTER:-
VIVER CHORDIA PROPRIETOR OF
VIVANTA CORPORATION
PROJECT ADDRESS:-
PROPOSED RESIDENTIAL BUILDING
AT R17-265, 266 & 266-A, AMER
ROAD (CHORDIA CITY)
SCHEME - INDRAPRASTH COLONY
AMER ROAD, JAIPUR.

TITLE: BLOCK-A METER PANEL	
DRAWING: SINGLE LINE DIAGRAM	
DATE:- 10-02-2023	REV:- 00
DRAWN BY:- VICKY YADAV	CHECKED BY :- VIPUL AGARWAL

Vipul
VIPUL AGARWAL
M.E.P CONSULTANT
B.E. ELECTRICAL

CHITRAKUT SCHEME, JAIPUR
PH:93146-10438,2440946
E MAIL:vipul8599@yahoo.com

WONDER HOMES

VIVEK CHORDIA PROPRIETER OF
VIVANTA CORPORATION

PROPOSED RESIDENTIAL BUILDING OF
PLOT NO. R17/263, R17/264 (NJI
KHATEDAR) SCHEME :- "INDRAPRASTH
(CHORDIA CITY)" AJMER ROAD, JAIPUR."

MAIN DISTRIBUTION PANELS





DRAWING:


SINGLE LINE DIAGRAM

10-02-2023	00
------------	----

DRAWN BY:-


VIPUL AGARWAL

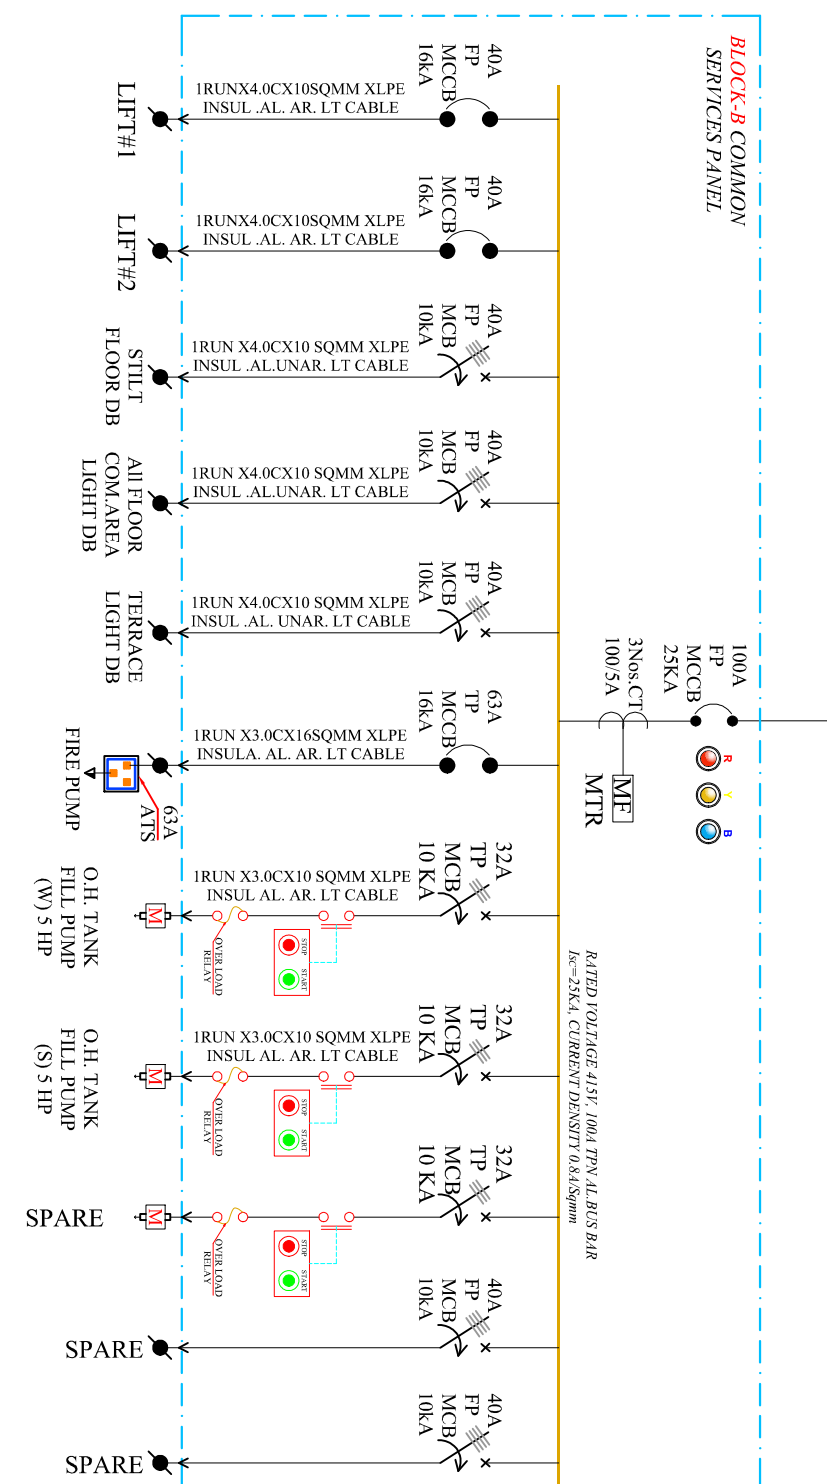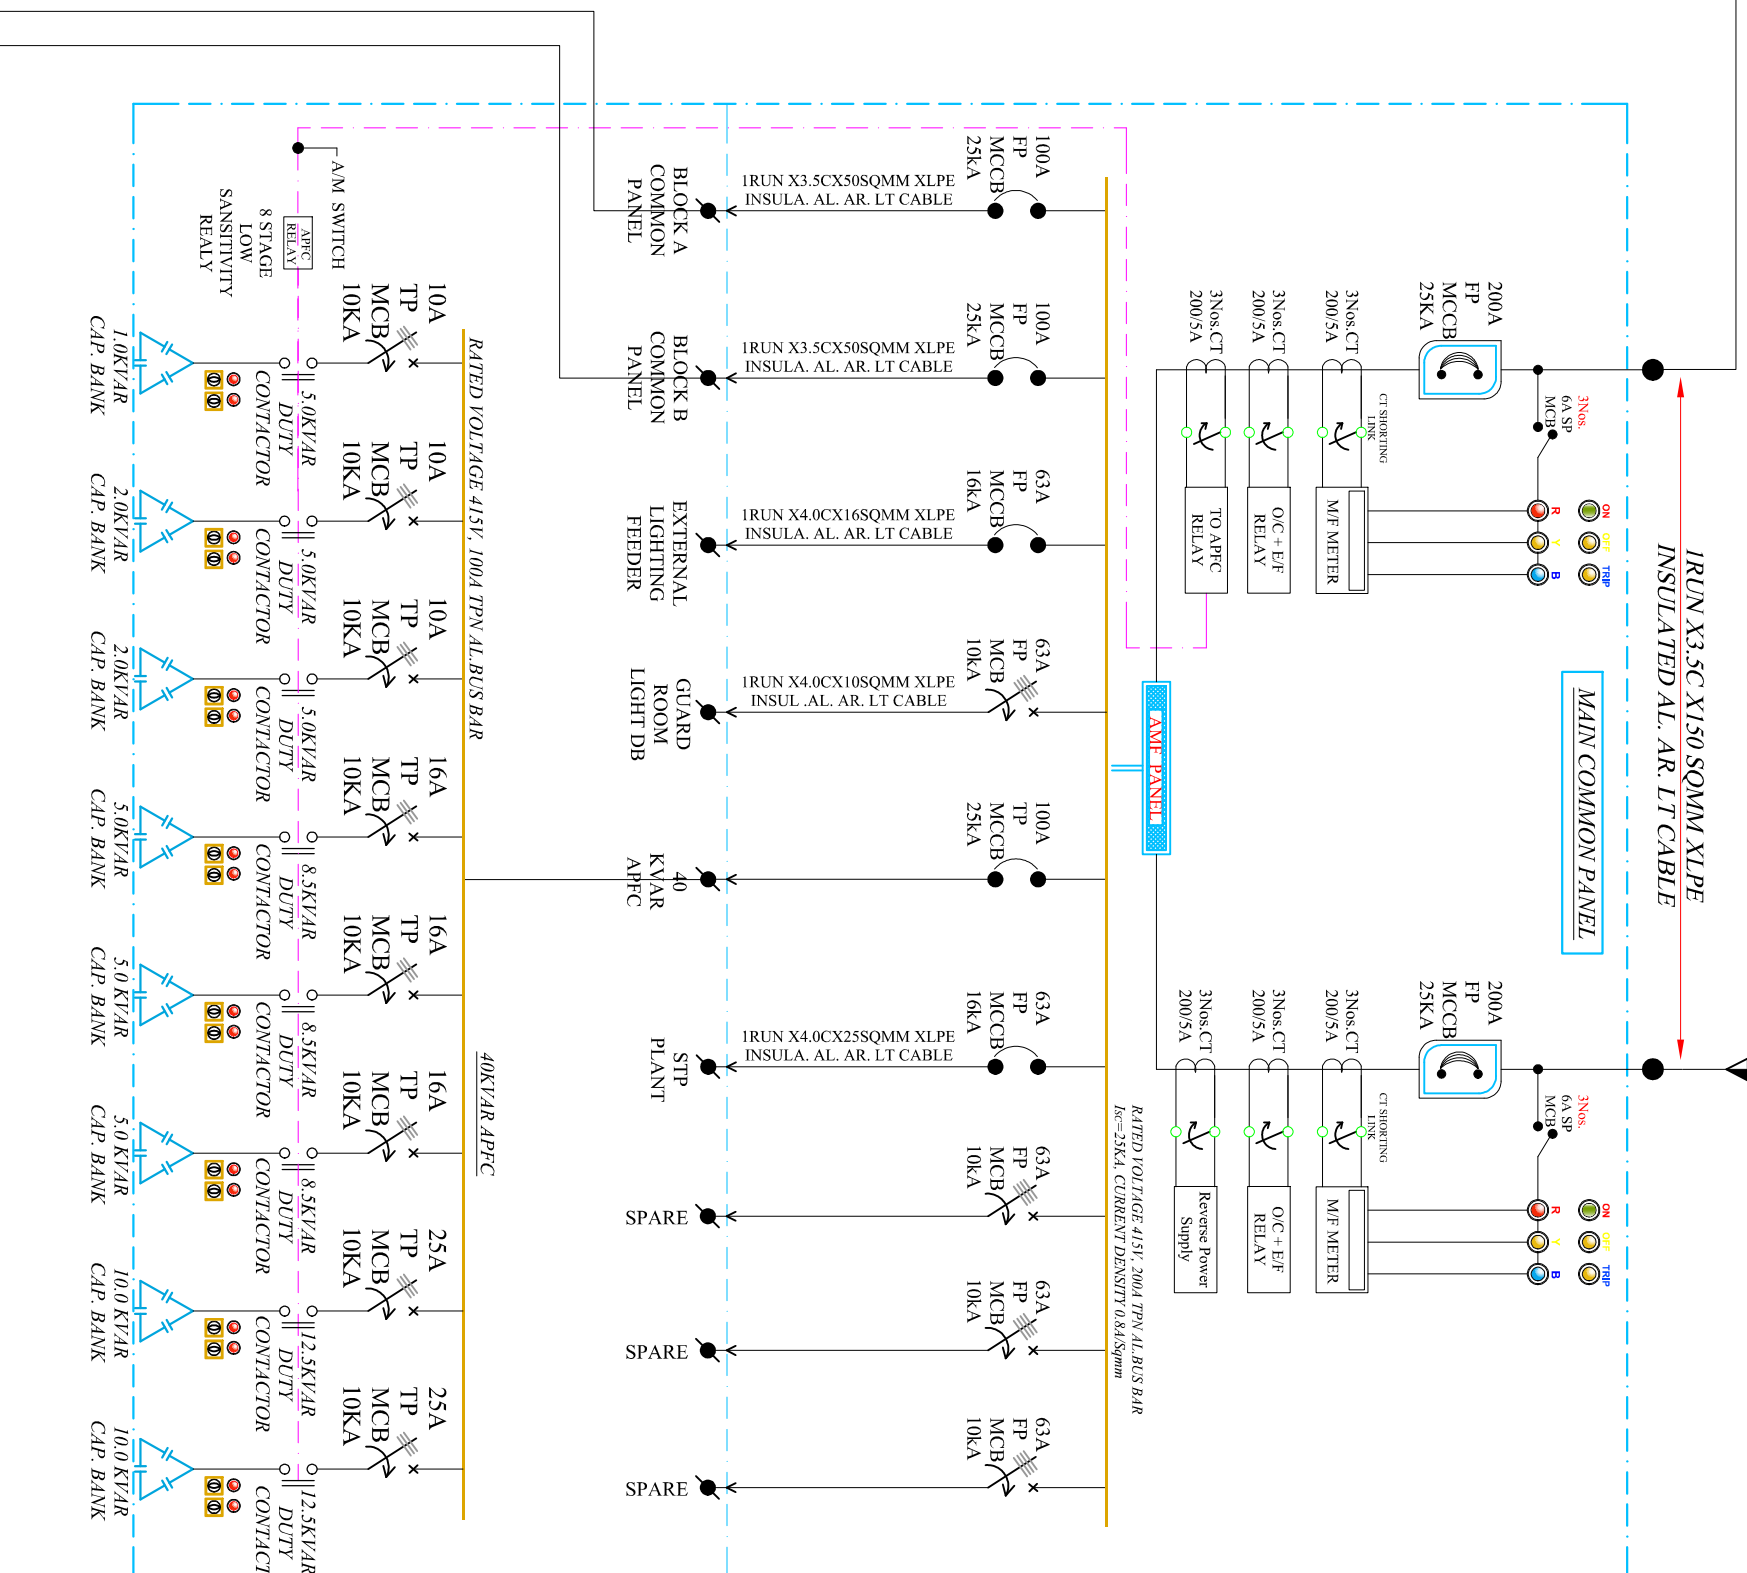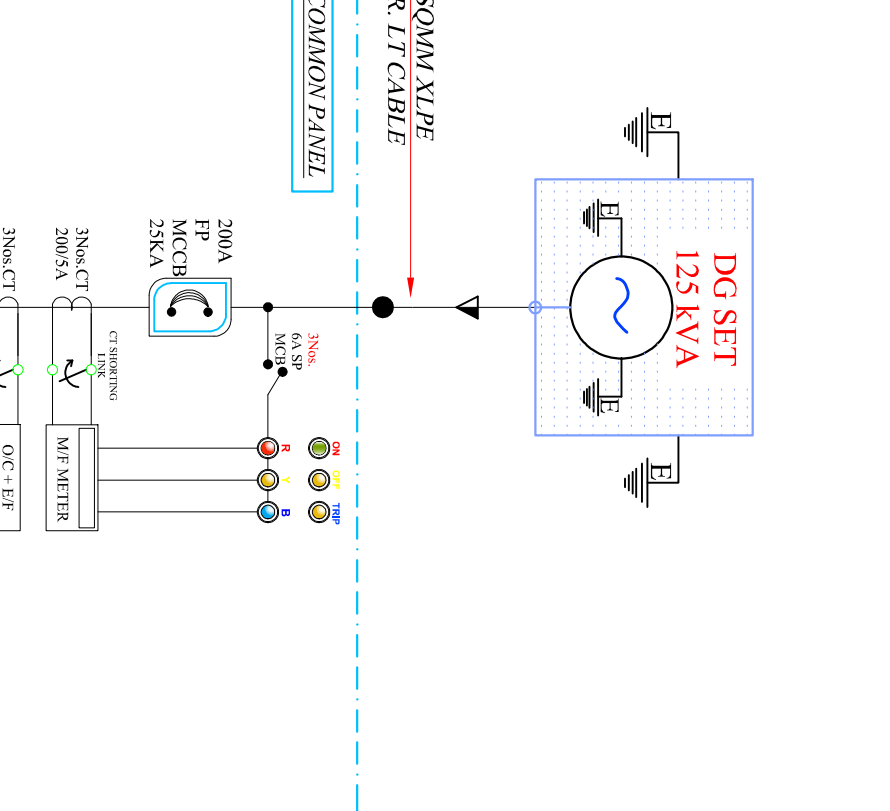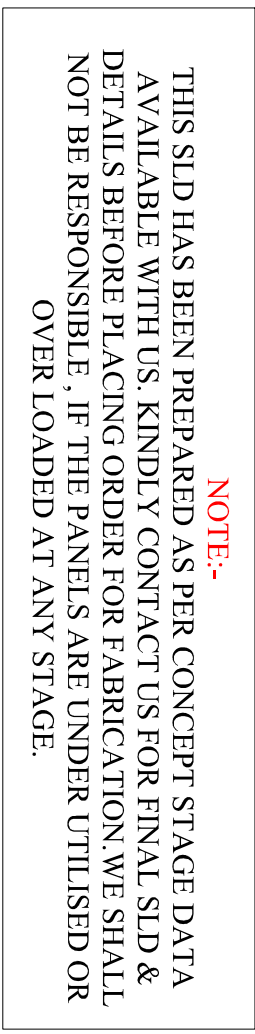

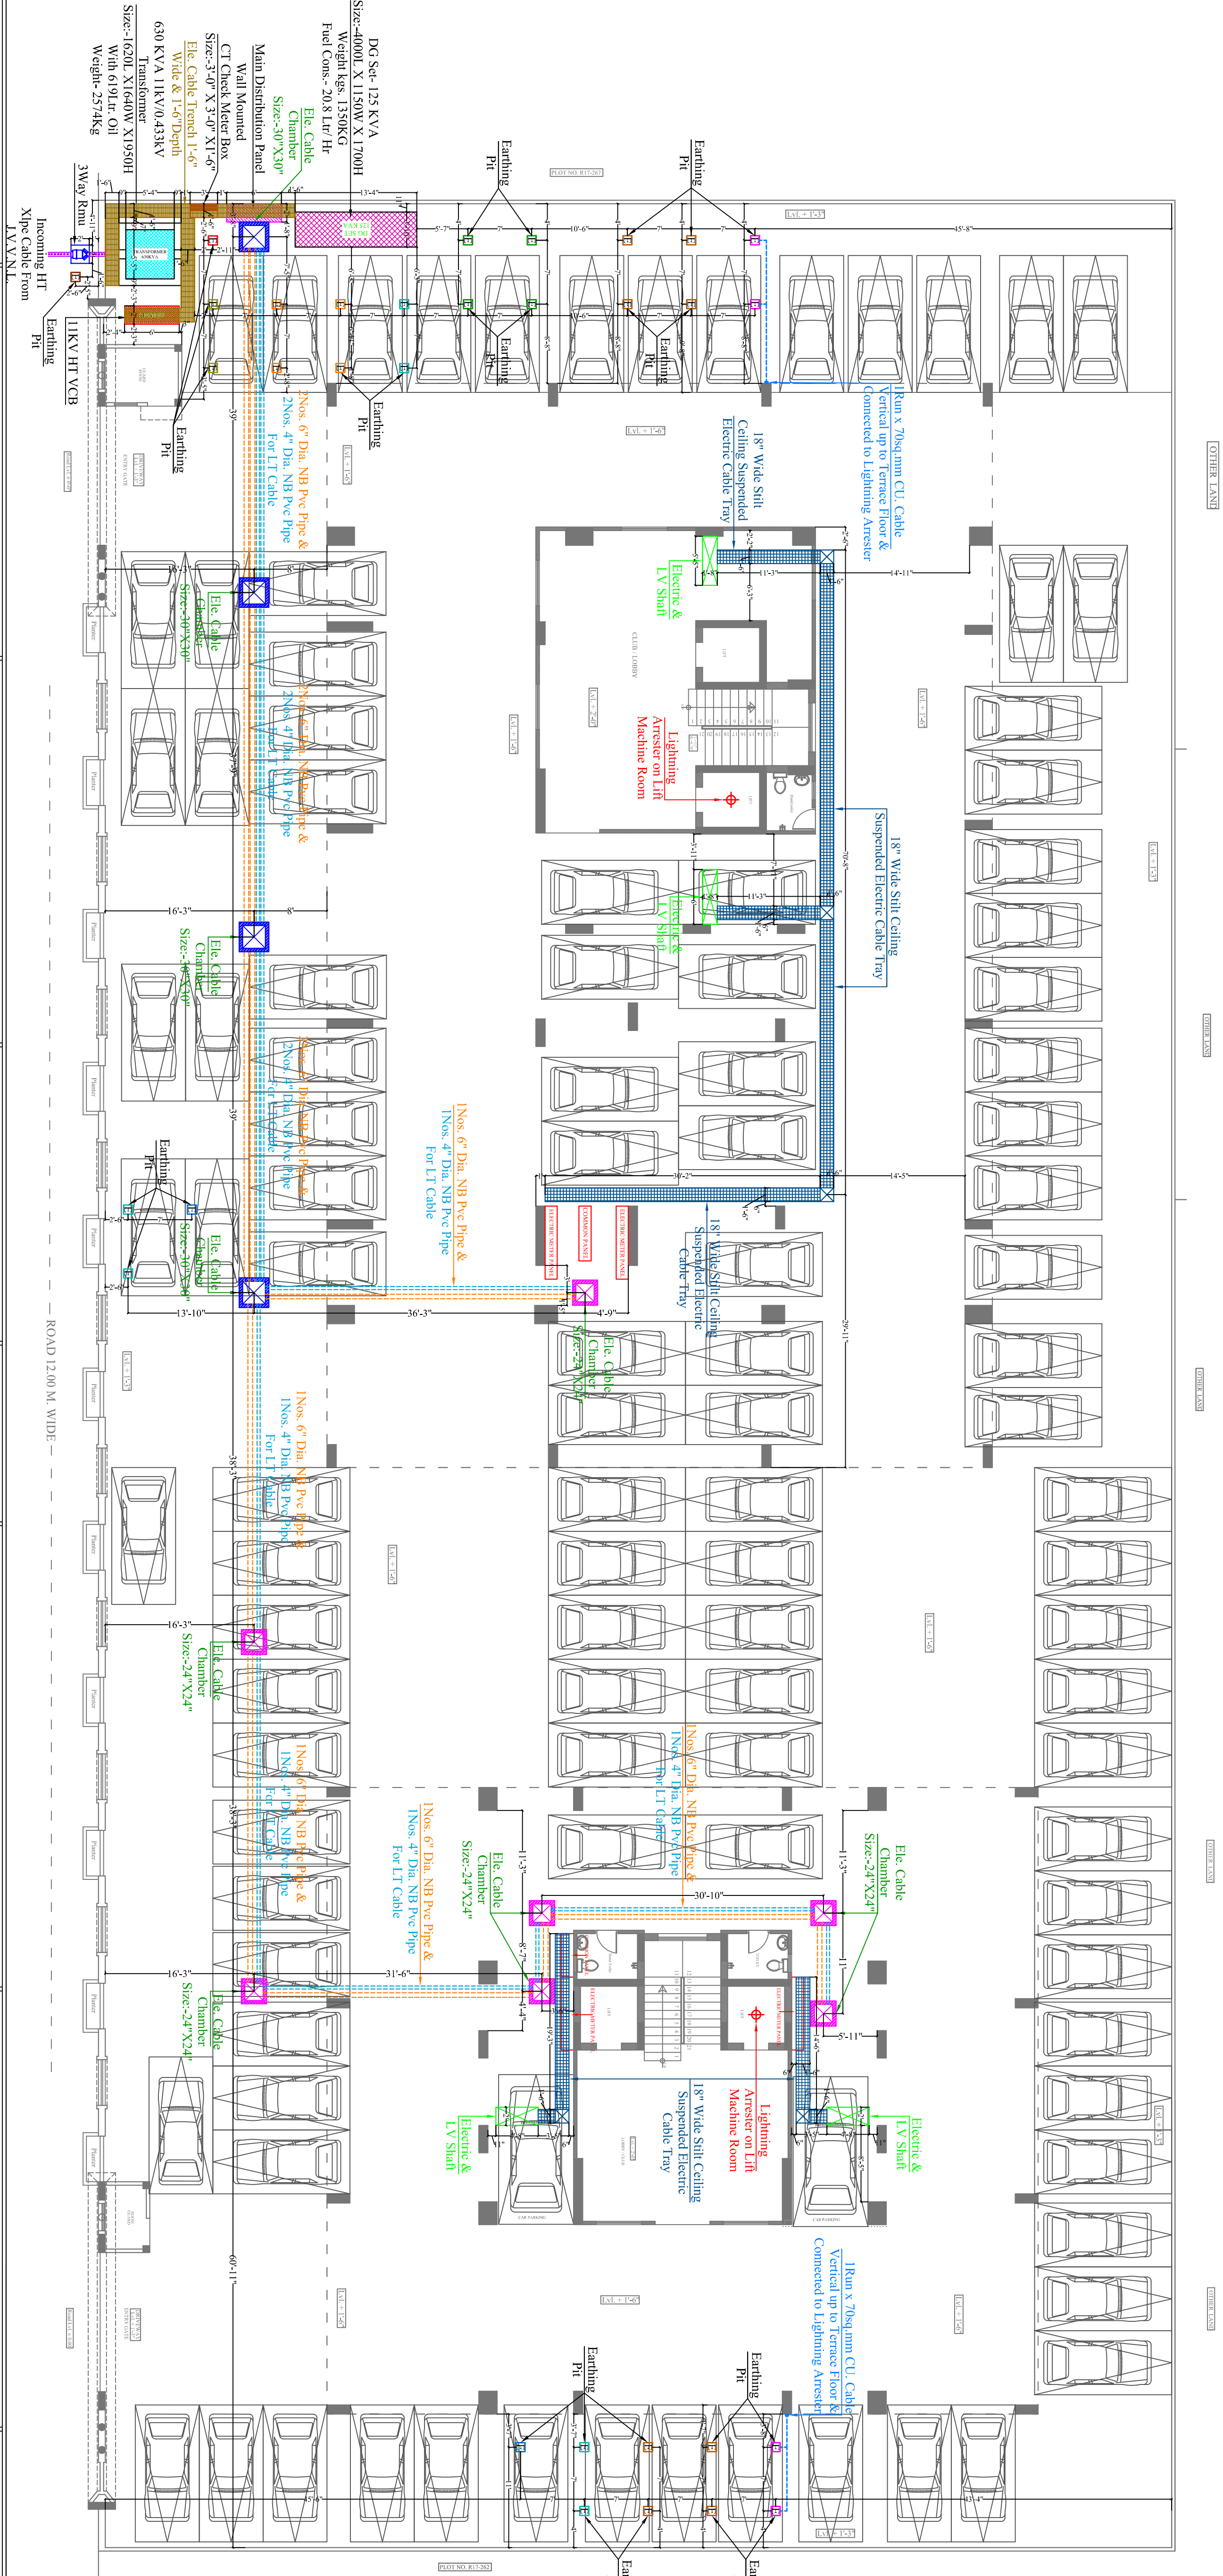

**Lighting
Arrester**

Model: Stormaster –
ESE - 30 (Level
2/Medium Protection)
(Protection radius - 25M,
Mast Height -2 Mtr)

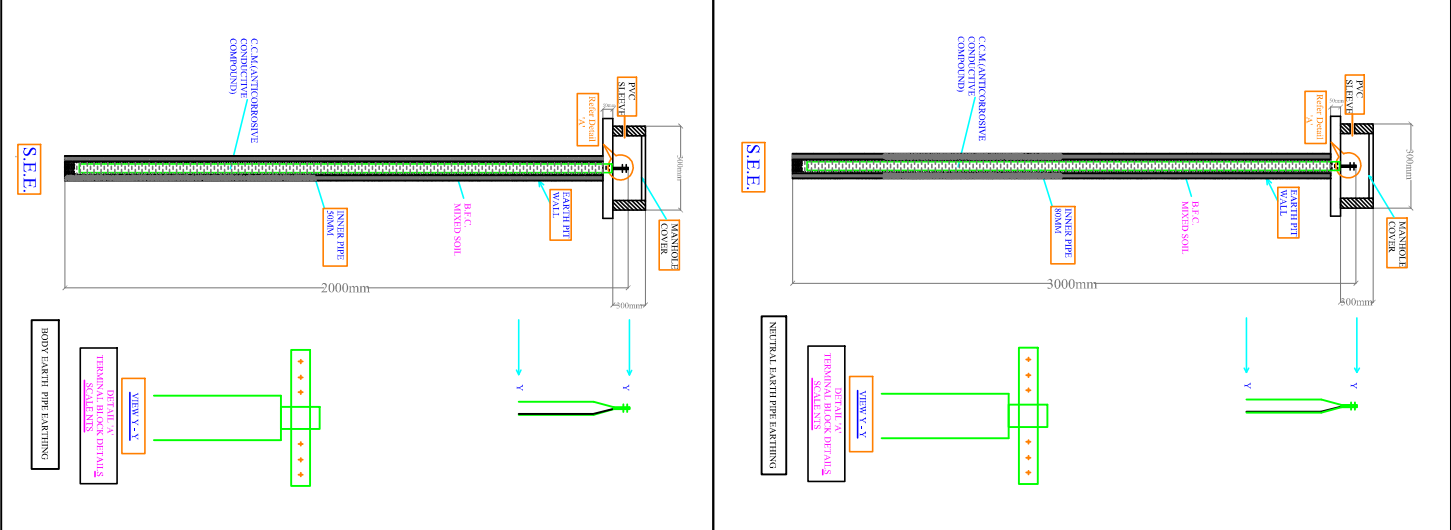

EARTHING DETAILS	
01	SSM PRESENTATION / MAIN RAIL BODY EARTH
02	SSM PRESENTATION / LIGHTNING ARRESTER BODY EARTH
03	SSM PRESENTATION / LIGHTNING ARRESTER BODY EARTH
04	SSM PRESENTATION / LIGHTNING ARRESTER BODY EARTH
100	SSM PRESENTATION / LIGHTNING ARRESTER BODY EARTH

PROJECT NAME:-
WONDER HOMES

PROMOTER:-
VIVEK CHORDIA
PROPRIETOR OF
VIVANTA CORPORATION

PROJECT ADDRESS:-
PROPOSED RESIDENTIAL BUILDING OF
PLOT NO. R17/263, R17/264 NIJI
KHATEDAR SCHEME :- "INDRAPRASTH
(CHORDIA CITY)" AMER ROAD, JAIPUR."

DRAWING:
**BLOCK- B
STILT FLOOR
ELECTRIC SUB STATION,
CABLE ROUTE &
LIGHTNING ARRESTER PLAN**

DRN. BY:-
PAWAN

CKD. BY:-
SANJAY

APPD. BY:-
VIPUL AGARWAL


DATE :-
10-04-2023


REV. :-
00

SCALE:-
N.T.S.

SERVICES CONSULTANT :-
**VIPUL CONSULTING,
F 9 / 440 , Keshav Marg,
Chitrakut Scheme,Jaipur
PH:91-0-93146-10438 0141-2440946
Mail:vipul8599@yahoo.com**

ARCHITECT :-
**SPACE GRID
C-49,VIDYA APARTMENT,PARKS MARG,
BAPU NAGAR,NEAR JANTA STORE
CIRCLE, JAIPUR -302015
PH-09314918766 0141-4005506 (O)
Email:-info.spacegrid@gmail.com**

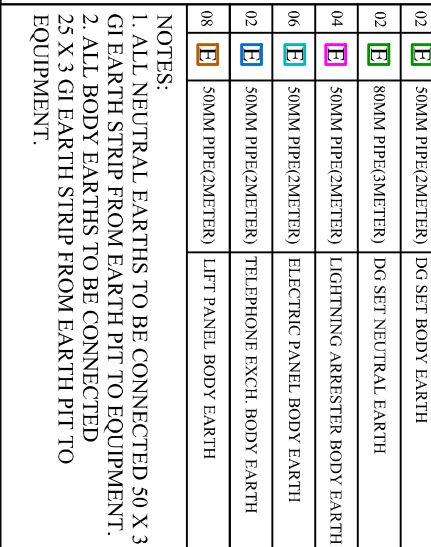

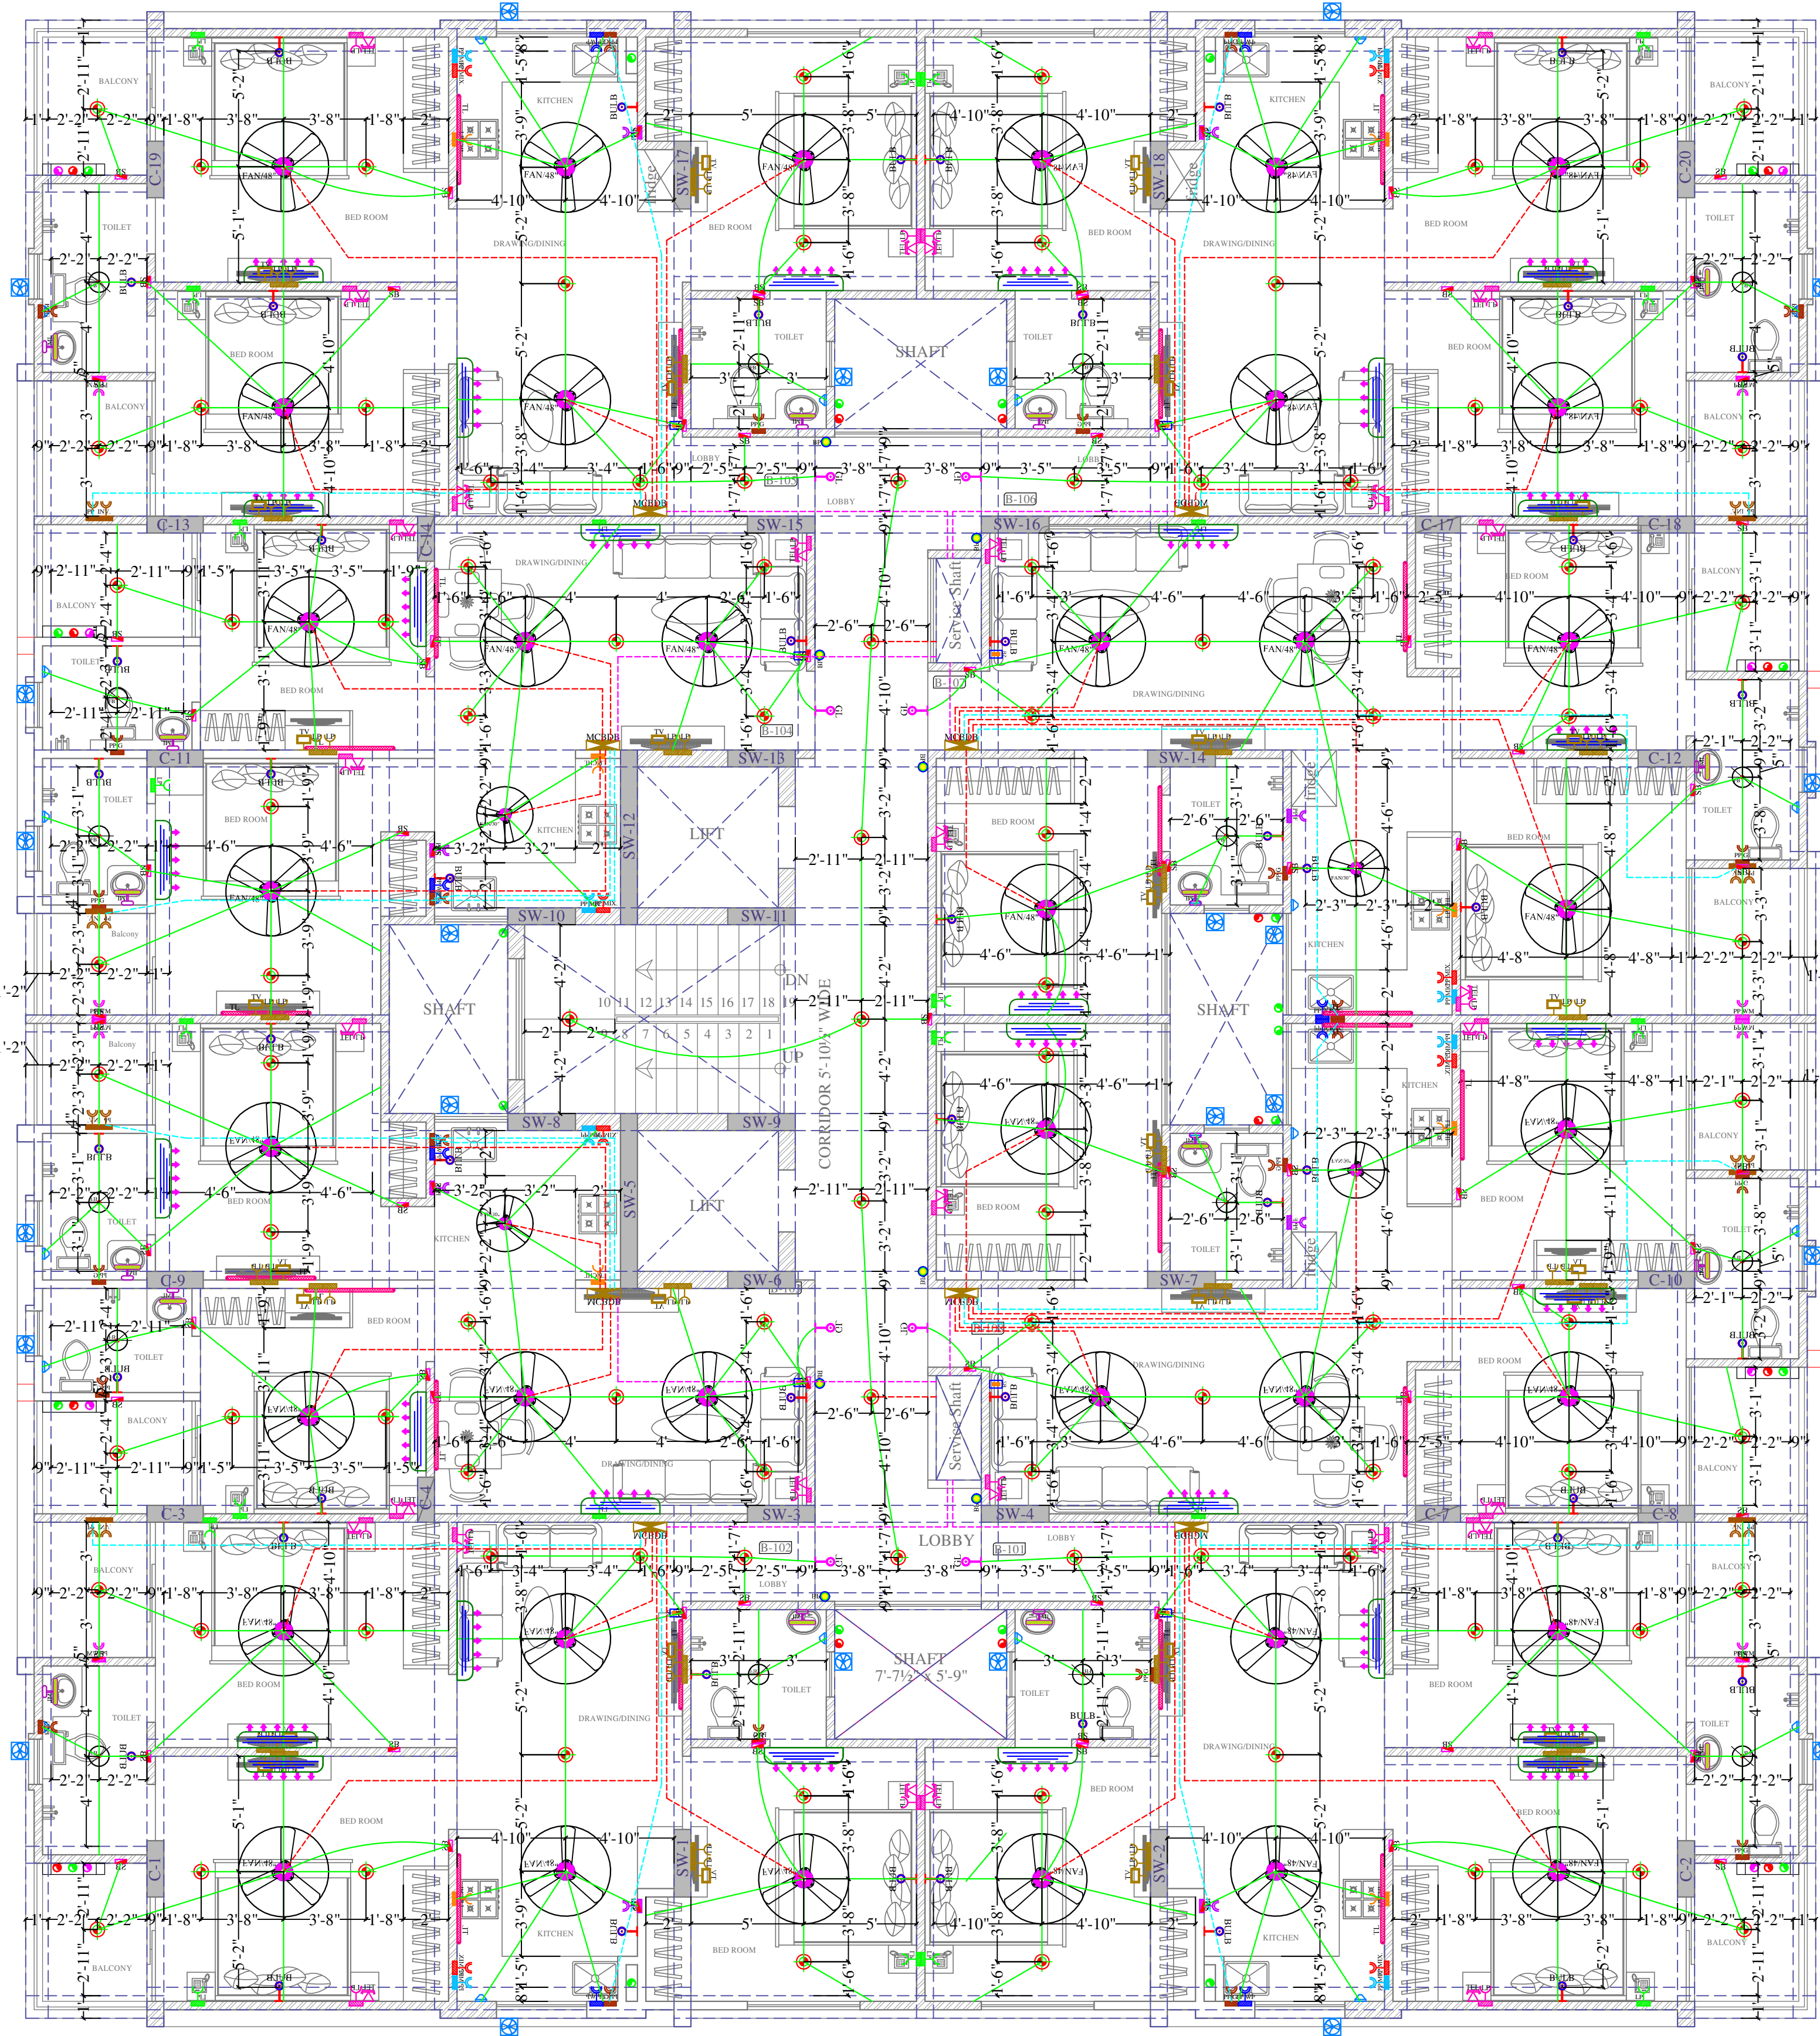

Vipul
VIPUL AGARWAL
M.E.P. CONSULTANT
B.E. ELECTRICAL

LEGENDS:					
Mounting Height	No.	I D	Symbol	Description	
IN RCC SLAB		CONDUIT		Rigid PVC 25mm dia. Conduit /1.5 sqmm Wire For Light Points	
IN RCC SLAB		CONDUIT		Rigid PVC 25mm dia. Conduit /2.5 sqmm Wire For Light Circuits	
IN RCC SLAB		CONDUIT		Rigid PVC 25mm dia. Conduit / 4.00 sqmm Wire For Power Circuits	
IN RCC SLAB		CONDUIT		Submain Wire to DB From Main Panel on Ground Floor in Inos. 32mm dia Conduits	
CEILING	38	FAN/48"		CEILING FAN 48"	
CEILING	04	FAN/30"		CEILING FAN 30"	
CEILING	16	FB		FAN BOX	
CEILING	00	CH1		CHANDELIER	
+90"	21	TL/W		Led Wall Tube Light Make:- Syska Led Cat no.- SSK-TS-20W	
+90"	49	BULB		Led Bulb 20W Make:- Syska Led Cat no. SKC-20W 5.7K/3K	
+90"	08	GL		WALL BRACKETS AS DESIGN FOR GANESH LIGHT	
+78"	16	ML		12x2 Led Mirror Light Make:- Syska Led Cat no:- FPL-12x2	
CEILING	100	DL		Led 6" Down Lighter 20W (Surface Mounted) Make:- Syska Led Cat no:- SDL-15W GLD 6.5K/4K	
VENTILATOR HT.	24	CR		CEILING ROSE	
VENTILATOR HT.	24	EXF		9" DIA FRESH AIR FAN	
+42"	79	SB		SWITCH BOARD	
+24"	30	TEL		TELEPHONE POINT	
+24"	30	LP TEL		6 A PLUG POINT FOR TELEPHONE	
+48"	30	TV		TV COAXIAL POINT	
+48"	60	LP TV		6 A PLUG POINT FOR TV	
+24"	22	LP		6 A PLUG POINT FOR SIDE TABLE	
+72"	08	LP-CH		6 A PLUG POINT FOR CHIMNEY	
+90"	32	SAC		SPLIT AC INDOOR UNIT	
+42"	08	PP-MIX		16 A POWER POINT FOR MIXER	
+42"	08	PP-MIC		16 A POWER POINT FOR MICROWAVE	
+78"	24	PP-G		16 A POWER POINT FOR GEYSER	
+54"	08	PP-F		16 A POWER POINT FOR FRIDGE	
+78"	08	PP-WP		16 A POWER POINT FOR WATER PURIFIER	
+48"	08	PP-WM		16 A POWER POINT FOR WASHING MACHINE	
+12"	16	PP-INV.		16 A POWER POINT FOR INVERTOR	
+60"	08	BP		6 A BELL PUSH	
+90"	08	BZ		BUZZER FOR CALL BELL	
+60"	08	MCB DB		MCB DISTRIBUTION BOARD	

PROJECT NAME:-
WONDER HOMES

PROMOTER:-
VIVEK CHORDIA
PROPRIETER OF
VIVANTA CORPORATION

PROJECT ADDRESS:-
NG OF
PLOT NO. R17/265.266 & 266-A (NIJI
KHATEDARI) SCHEME :-
"INDRAPRASTH (CHORDIA CITY)"
AMER ROAD, JAIPUR."

DRAWING:
**BLOCK-A
GROUND FLOOR
ELECTRIC CONDUIT PLAN**

DRN. BY:-
VINOD KUMAR

CKD. BY:-
SANJAY

APPD. BY:-
VIPUL AGARWAL

DATE :-
13-07-2022


REV. :-
00

SCALE:-
N.T.S.

SERVICES CONSULTANT :-
VIPUL CONSULTING,
F 9 / 440 , Keshav Marg,
Chitrakut Scheme,Jaipur
PH:91-0-93146-10438 ,0141-2440946
Mail:vipul8599@yahoo.com

ARCHITECT :-
SPACE GRID
C-49,VIDYA APARTMENT,PARAS MARG,
BAPU NAGAR,NEAR JANTA STORE
CIRCLE, JAIPUR-302015
PH-09314918766,0141-4005506 (O)
Email:-info.spacegrid@gmail.com


S
E
W
N

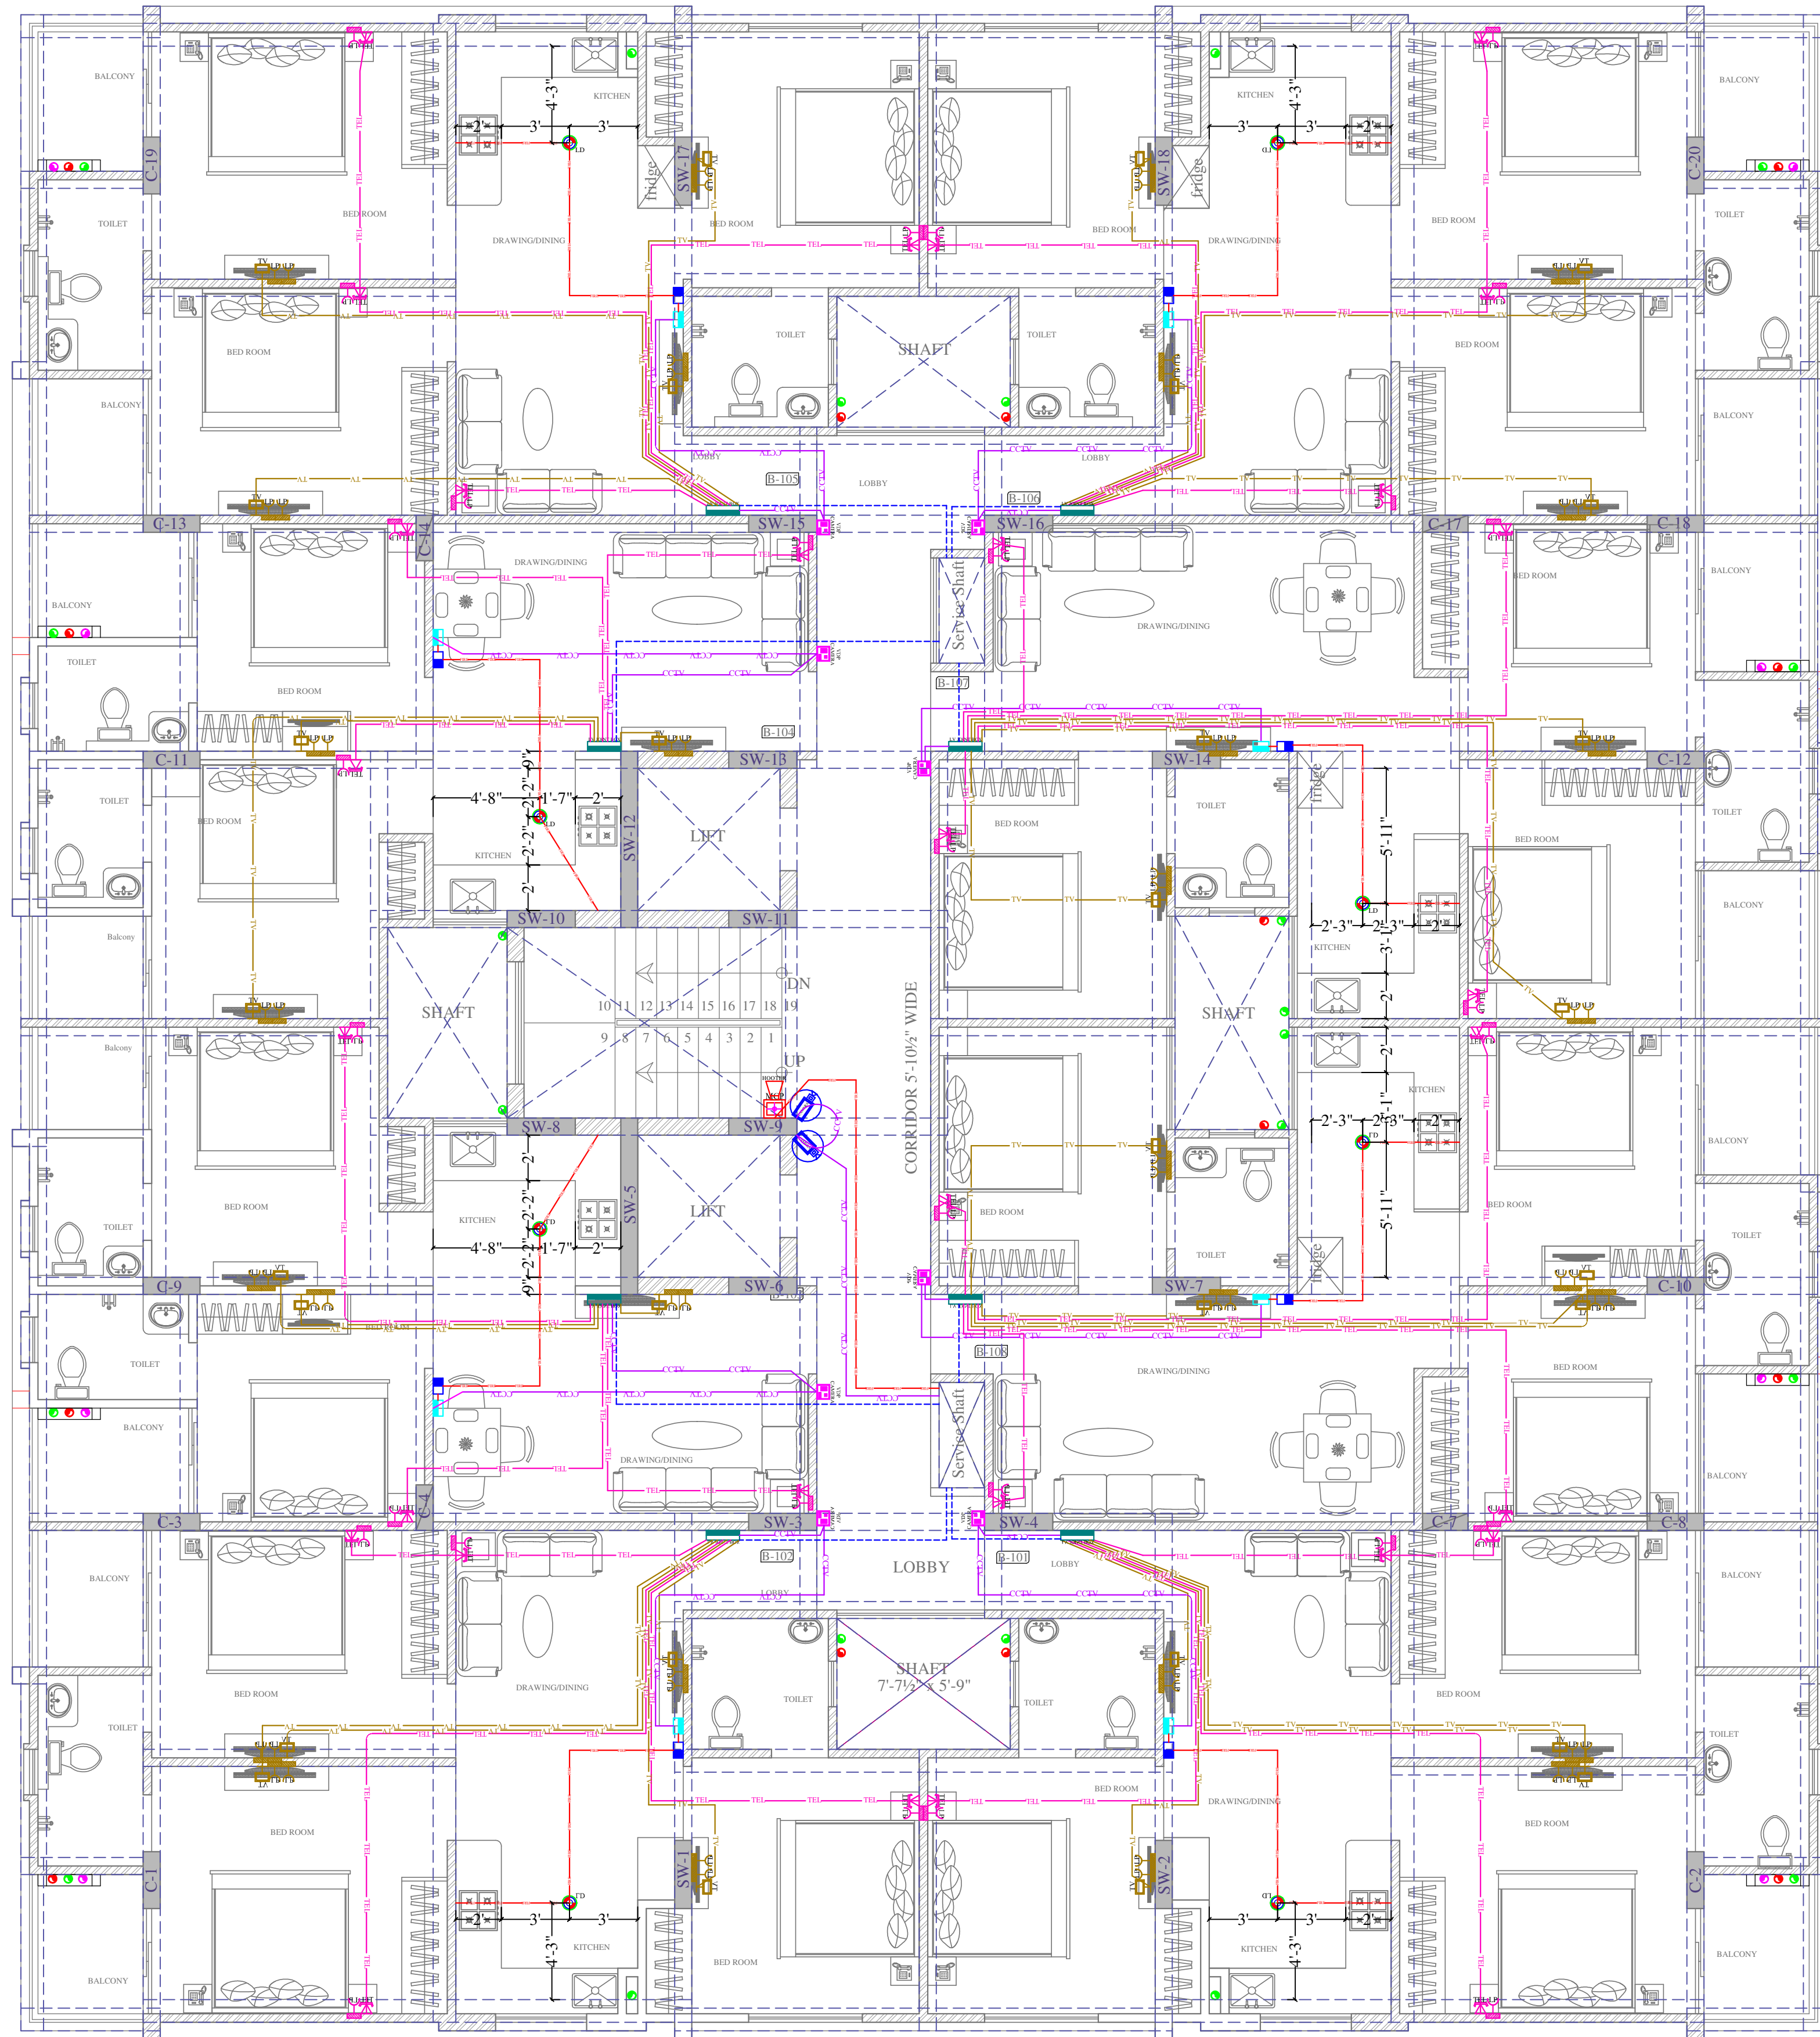

Vipul
VIPUL AGARWAL
M.E.P. CONSULTANT
B.E. ELECTRICAL

LEGENDS:					
Mounting Height	No.	ID	Symbol	Description	
IN FLOOR		CONDUIT	TEL	Rigid PVC 25mm dia. Conduit / 0.5mm 2 Pair Wire For Tel Wiring	
IN FLOOR		CONDUIT	TV	Rigid PVC 25mm dia. Conduit / RG6 Cable For TV Wiring	
IN RCC SLAB		CONDUIT		1 Nos. 32 mm dia Conduits From Flat LV System to Drop LV Shaft	
IN RCC SLAB		CONDUIT	CCTV	Rigid PVC Conduit 25mm/3+1 Coaxial Wire/Cat-6 Cable for Video Door Phone & Security Camera (C.C.T.V.).	
IN RCC SLAB		CONDUIT	FIRE	Rigid PVC 25mm dia. Conduit / 2X1.5 sq. mm Copper Wire For Fire Alarm	
+60"	08	VDP CAMERA		VIDEO DOOR PHONE OUTDOOR UNIT WITH BUILT IN CAMERA	
+48"	08	VDP		VIDEO DOOR PHONE INDOOR UNIT	
+48"	08	PS		PANIC SWITCH	
CELLING	08	LD		LPG DETECTOR	
+24"	30	TEL		TELEPHONE POINT	
+24"	30	LP TEL		6 A PLUG POINT FOR TELEPHONE	
+48"	30	TV		TV COAXIAL POINT	
+48"	60	LP TV		6 A PLUG POINT FOR TV	
+42"	01	MCP		MANUAL CALL POINT	
+90"	01	HO		HOOTER POINT	
+90"	02	CCTV		WALL MOUNTED CCTV CAMERA	
+24"	08	LVS JB		LV SYSTEM JOINT BOX	

PROJECT NAME:- WONDER HOMES	PROJECT ADDRESS:- NG OF PLOT NO. R17/265.266 & 266-A (NIJI KHATEDARI) SCHEME :- "INDRAPRASTH (CHORDIA CITY)" AJMER ROAD, JAIPUR."	DRAWING: BLOCK-A GROUND FLOOR LV CONDUIT PLAN	DRN. BY:- VINOD KUMAR	DATE :- 13-07-2022	SERVICES CONSULTANT :- VIPUL CONSULTING, F 9 / 440 , Keshav Marg, Chitrakut Scheme,Jaipur PH:91-0-93146-10438 ,0141-2440946 Mail:vipul8599@yahoo.com	ARCHITECT :- SPACE GRID C-49,VIDYA APARTMENT,PARAS MARG, BAPU NAGAR,NEAR JANTA STORE CIRCLE, JAIPUR-302015 PH-09314918766,0141-4005506 (O) Email:-info.spacegrid@gmail.com	
PROMOTER:- VIVEK CHORDIA PROPRIETOR OF VIVANTA CORPORATION			CKD. BY:- SANJAY	REV. :- 00			
			APPD. BY:- VIPUL AGARWAL	SCALE:- N.T.S.			

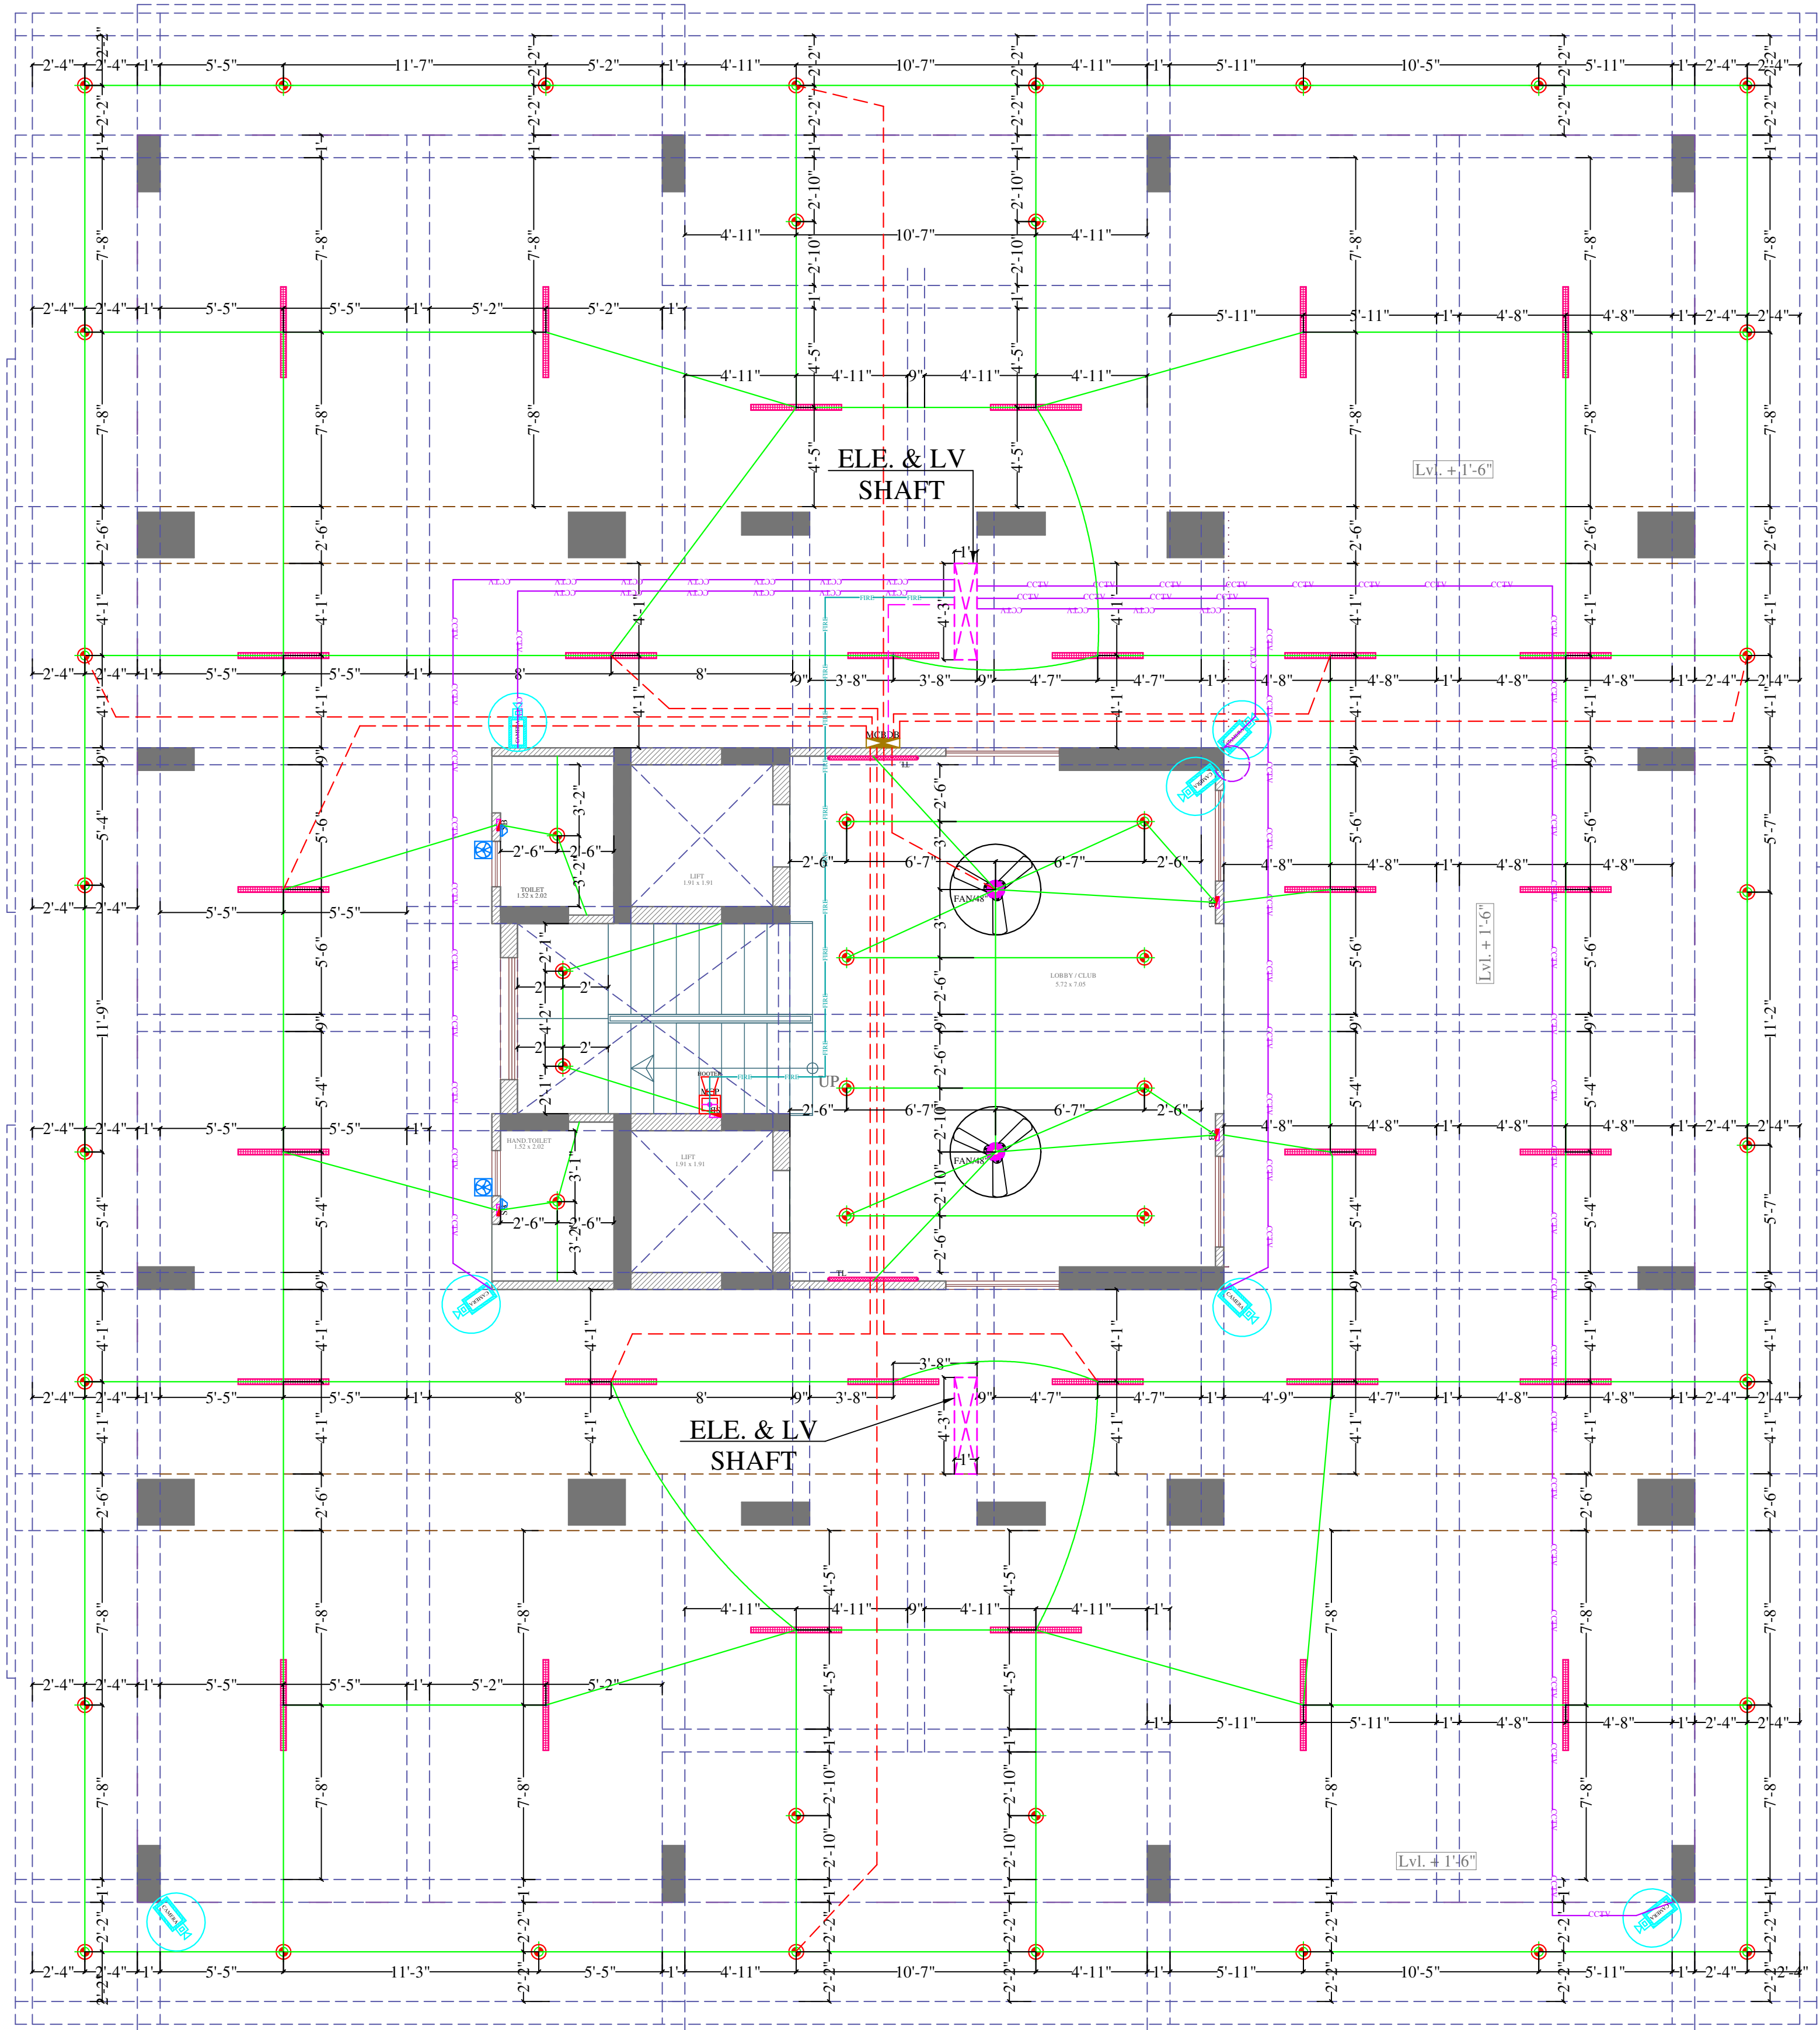

Vipul
VIPUL AGARWAL
M.E.P. CONSULTANT
B.E. ELECTRICAL

LEGENDS:				
Mounting Height	No.	I D	Symbol	Description
IN RCC SLAB		CONDUIT		Rigid PVC 25mm dia. Conduit / 1.5 sqmm Wire For Light Points
IN RCC SLAB		CONDUIT		Rigid PVC 25mm dia. Conduit / 2.5 sqmm Wire For Light Circuits
IN RCC SLAB		CONDUIT		Rigid PVC 25mm dia. Conduit / 4.00 sqmm Wire For Power Circuits
IN RCC SLAB		CONDUIT		Submain Wire to DB From Main Panel on Ground Floor in 1nos. 32mm dia Conduits
IN RCC SLAB		CONDUIT		Rigid PVC 25mm dia. Conduit / 2X1.5 sq. mm Copper Wire For Fire Alarm
IN RCC SLAB		CONDUIT		Rigid PVC 25mm dia. Conduit / 3+1 Coaxial Wire / Cat 6 UTP Cable For Security Camera (C.C.T.V.).
CEILING	02	FAN/48"		CEILING FAN 48"
CEILING	30			LED CEILING TUBE LIGHT MAKE:- SYSKA LED CAT NO.- SSK-TS-20W
+90"	02	TL/W		LED WALL TUBE LIGHT MAKE:- SYSKA LED CAT NO.- SSK-TS-20W
CEILING	44	DL		LED 6" DOWN LIGHTER 20W (SURFACE MOUNTED) MAKE:- SYSKA LED CAT NO.- SDL-15W GLD 6.5K/4K
VENTILATOR HT.	02	CR		CEILING ROSE
VENTILATOR HT.	02	EXF		9" DIA FRESH AIR FAN
+42"	05	SB		SWITCH BOARD
+60"	01	MCB DB		MCB DISTRIBUTION BOARD
+42"	01	MCP		MANUAL CALL POINT
+90"	01	HO		HOOTER POINT
+90"	07	CCTV		WALL MOUNTED CCTV CAMERA

PROJECT NAME:-
WONDER HOMES

PROMOTER:-
VIVEK CHORDIA
PROPRIETER OF
VIVANTA CORPORATION

PROJECT ADDRESS:-
ING OF
PLOT NO. R17/265, 266 & 266-A (NUJI
KHATEDAR) SCHEME :-
"INDRAPRASTH (CHORDIA CITY)" AJMER ROAD, JAIPUR."

DRAWING:
**BLOCK-A
STILT FLOOR
ELECTRIC & LV
CONDUIT PLAN**

DRN. BY:-
RAJENDER

CKD. BY:-
SANJAY

APPD. BY:-
VIPUL AGARWAL


DATE :-
19-05-2022

REV. :-
00

SCALE:-
N.T.S.

SERVICES CONSULTANT :-
VIPUL CONSULTING,
F 9 / 440 , Keshav Marg,
Chitrakut Scheme,Jaipur
PH:91-0-93146-10438 ,0141-2440946
Mail:vipul8599@yahoo.com

ARCHITECT :-
SPACE_GRID
C-49,VIDYA APARTMENT,PARAS MARG,
BAPU NAGAR,NEAR JANTA STORE
CIRCLE, JAIPUR-302015
PH-09314918766,0141-4005506 (O)
Email:-info.spacegrid@gmail.com

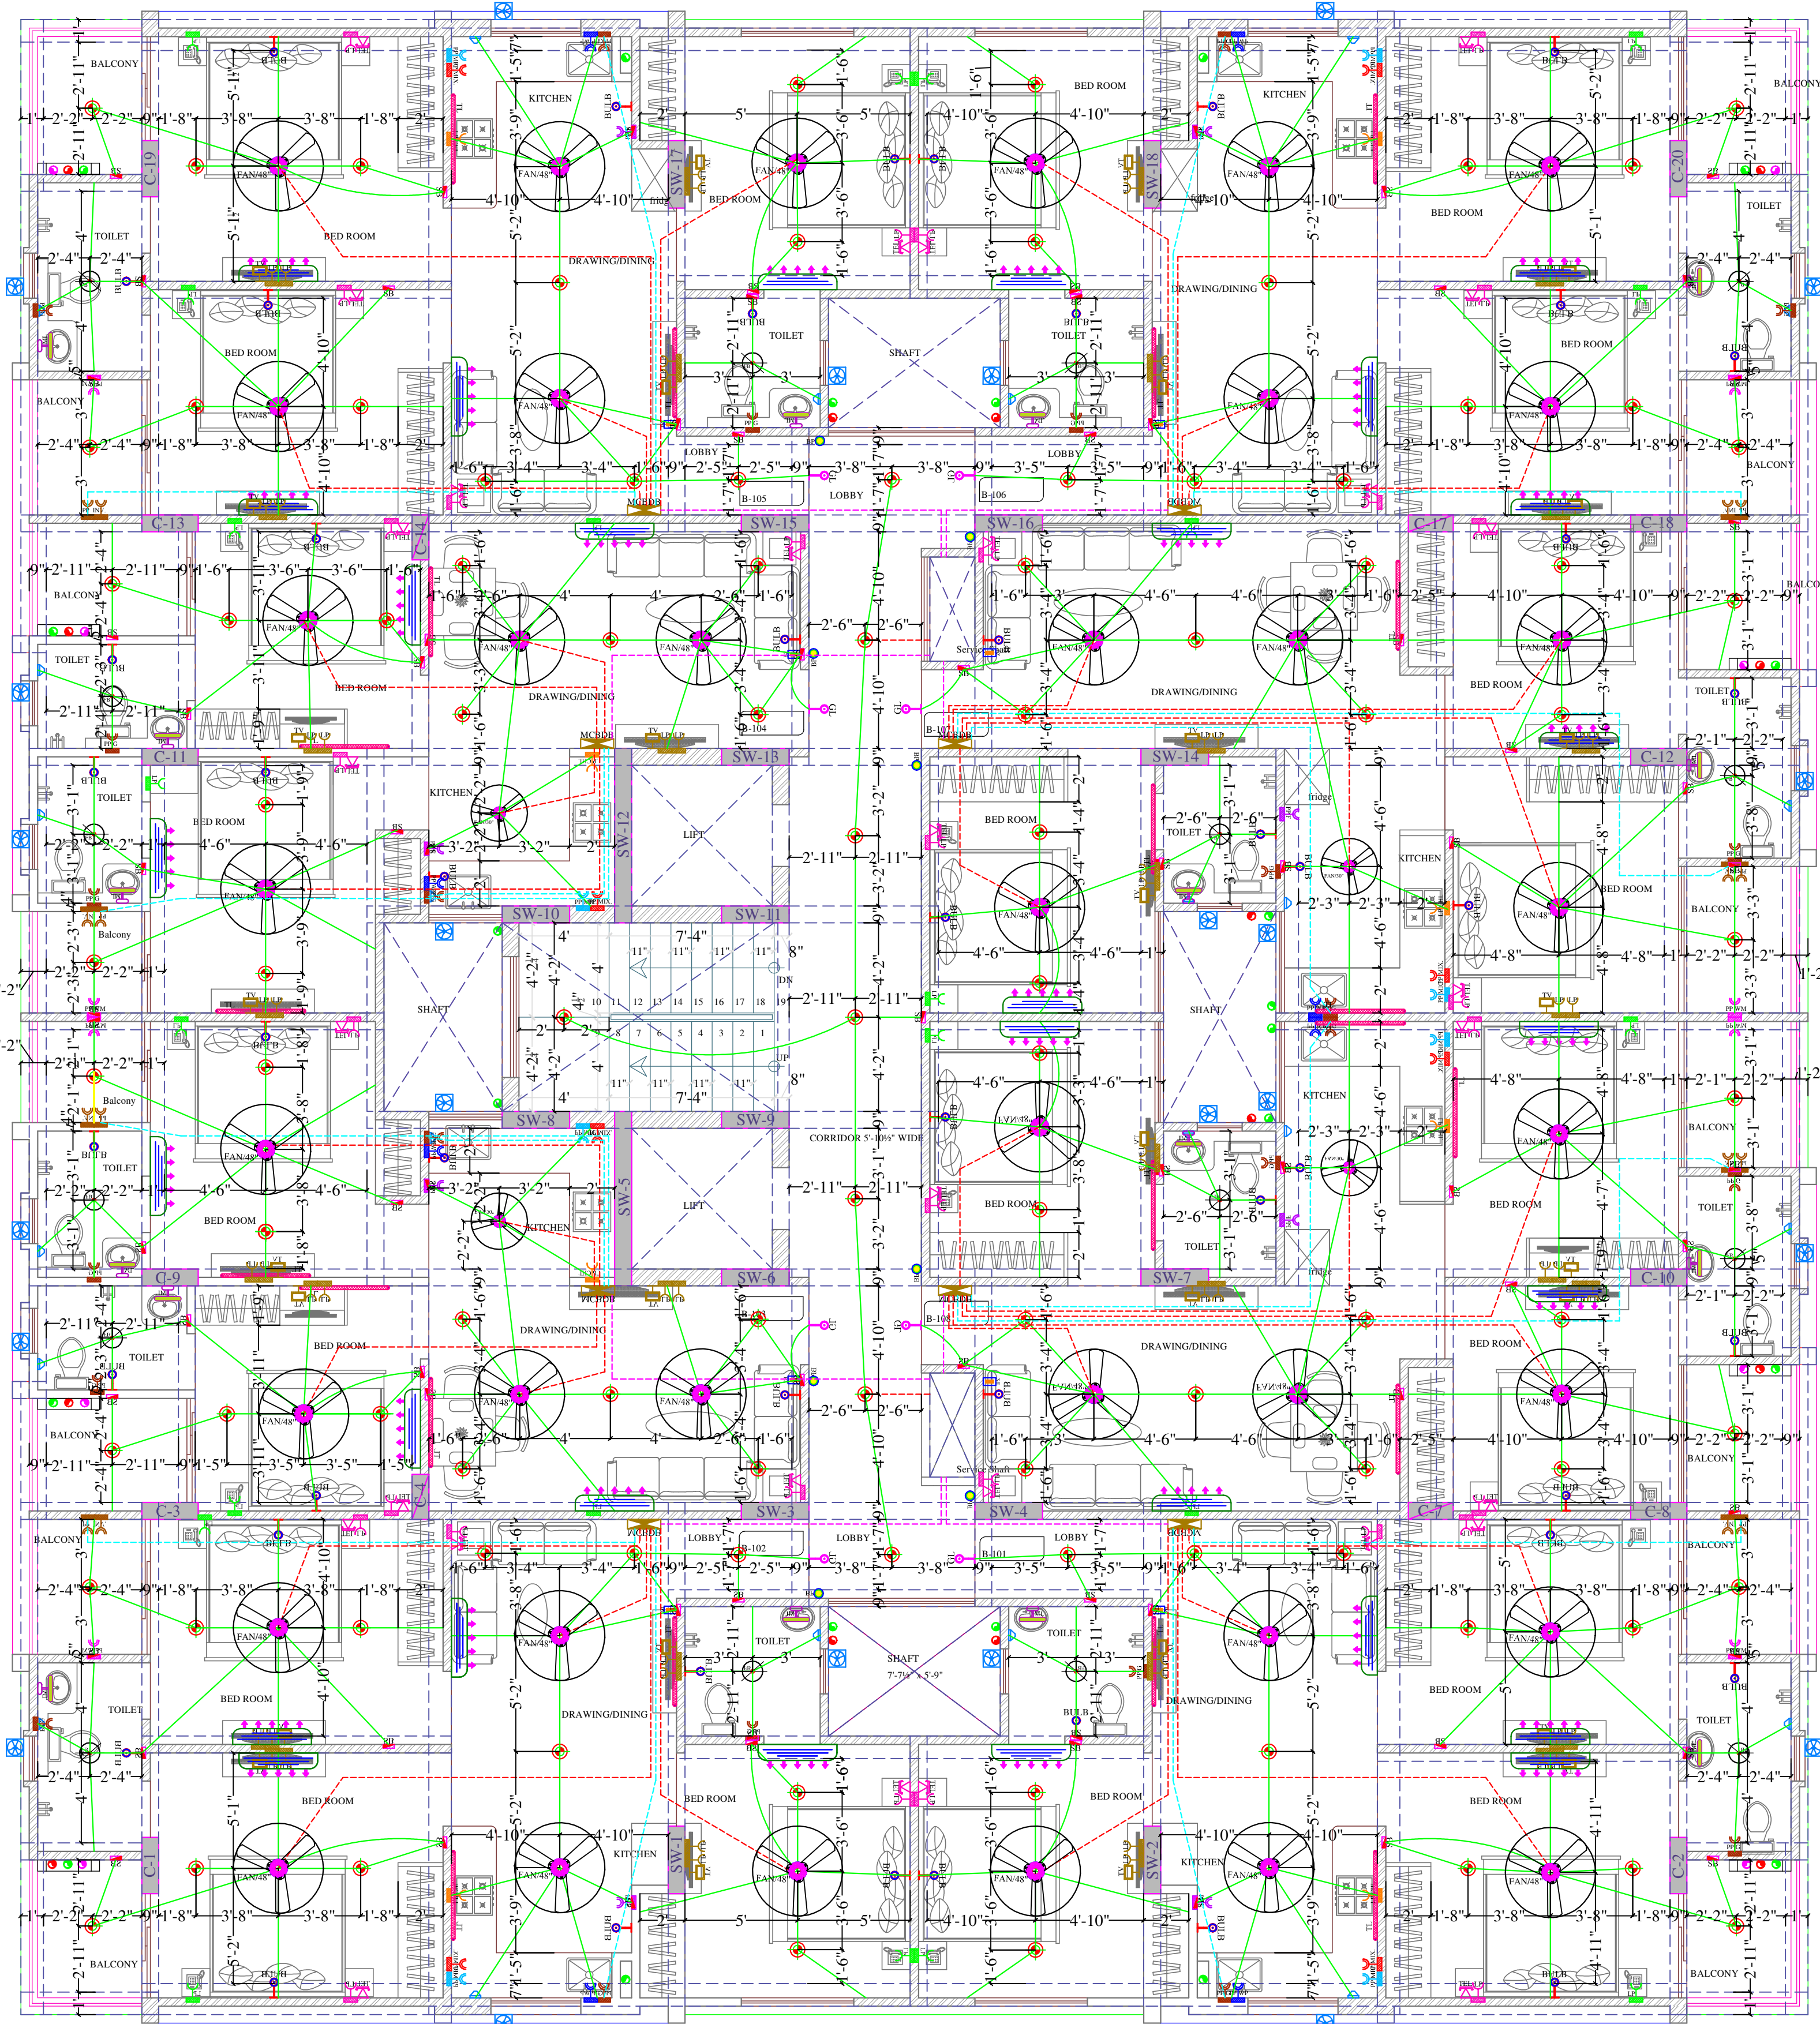

Vipul
VIPUL AGARWAL
M.E.P. CONSULTANT
B.E. ELECTRICAL

LEGENDS:

Mounting Height	No.	1 D	Symbol	Description
IN RCC SLAB		CONDUIT		Rigid PVC 25mm dia. Conduit /1.5 sqmm Wire For Light Points
IN RCC SLAB		CONDUIT		Rigid PVC 25mm dia. Conduit /2.5 sqmm Wire For Light Circuits
IN RCC SLAB		CONDUIT		Rigid PVC 25mm dia. Conduit / 4.00 sqmm Wire For Power Circuits
IN RCC SLAB		CONDUIT		Submain Wire to DB From Main Panel on Ground Floor in Inos. 32mm dia Conduits
CEILING	38	FAN/48"		CEILING FAN 48"
CEILING	04	FAN/30"		CEILING FAN 30"
CEILING	16	FB		FAN BOX
CEILING	00	CH1		CHANDELIER
+90"	21	TL/W		Led Wall Tube Light Make:- Syska Led Cat no:- SSK-TS-20W
+90"	49	BULB		Led Bulb 20W Make:- Syska Led Cat no. SKC-20W 5.7K/3K
+90"	08	GL		WALL BRACKETS AS DESIGN FOR GANESH LIGHT
+78"	16	ML		12x2 Led Mirror Light Make:- Syska Led Cat no:- FPL-12x2
CEILING	100	DL		Led 6" Down Lighter 20W (Surface Mounted) Make:- Syska Led Cat no:- SDL-15W GLD 6.5K/4K
VENTILATOR HT.	24	CR		CEILING ROSE
VENTILATOR HT.	24	EXF		9" DIA FRESH AIR FAN
+42"	79	SB		SWITCH BOARD
+24"	30	TEL		TELEPHONE POINT
+24"	30	LP TEL		6 A PLUG POINT FOR TELEPHONE
+48"	30	TV		TV COAXIAL POINT
+48"	60	LP TV		6 A PLUG POINT FOR TV
+24"	22	LP		6 A PLUG POINT FOR SIDE TABLE
+72"	08	LP-CH		6 A PLUG POINT FOR CHIMNEY
+90"	32	SAC		SPLIT AC INDOOR UNIT
+42"	08	PP-MIX		16 A POWER POINT FOR MIXER
+42"	08	PP-MIC		16 A POWER POINT FOR MICROWAVE
+78"	24	PP-G		16 A POWER POINT FOR GEYSER
+54"	08	PP-F		16 A POWER POINT FOR FRIDGE
+78"	08	PP-WP		16 A POWER POINT FOR WATER PURIFIER
+48"	08	PP-WM		16 A POWER POINT FOR WASHING MACHINE
+12"	16	PP-INV.		16 A POWER POINT FOR INVERTOR
+60"	08	BP		6 A BELL PUSH
+90"	08	BZ		BUZZER FOR CALL BELL
+60"	08	MCB DB		MCB DISTRIBUTION BOARD

PROJECT NAME:-
WONDER HOMES
PROMOTER:-
VIVEK CHORDIA
PROPRIETER OF
VIVANTA CORPORATION

PROJECT ADDRESS:-
ING OF
PLOT NO. R17/265, 266 & 266-A (NIJI
KHATEDARI) SCHEME :-
"INDRAPRASTH (CHORDIA CITY)"
AMER ROAD, JAIPUR."

DRAWING:
BLOCK-A
TYPICAL FLOOR (1st-5th)
ELECTRIC CONDUIT PLAN


DRN. BY:-
VINOD KUMAR
CKD. BY:-
SANJAY
APPD. BY:-
VIPUL AGARWAL

DATE :-
24-09-2022
REV. :-
00
SCALE:-
N.T.S.

SERVICES CONSULTANT :-
VIPUL CONSULTING,
F 9 / 440 , Keshav Marg,
Chitrakut Scheme,Jaipur
PH:91-0-93146-10438, 0141-2440946
Mail:vipul8599@yahoo.com

ARCHITECT :-
SPACE GRID
C-49,VIDYA APARTMENT,PARAS MARG,
BAPU NAGAR,NEAR JANTA STORE
CIRCLE, JAIPUR-302015
PH-09314918766,0141-4005506 (O)
Email:-info.spacegrid@gmail.com




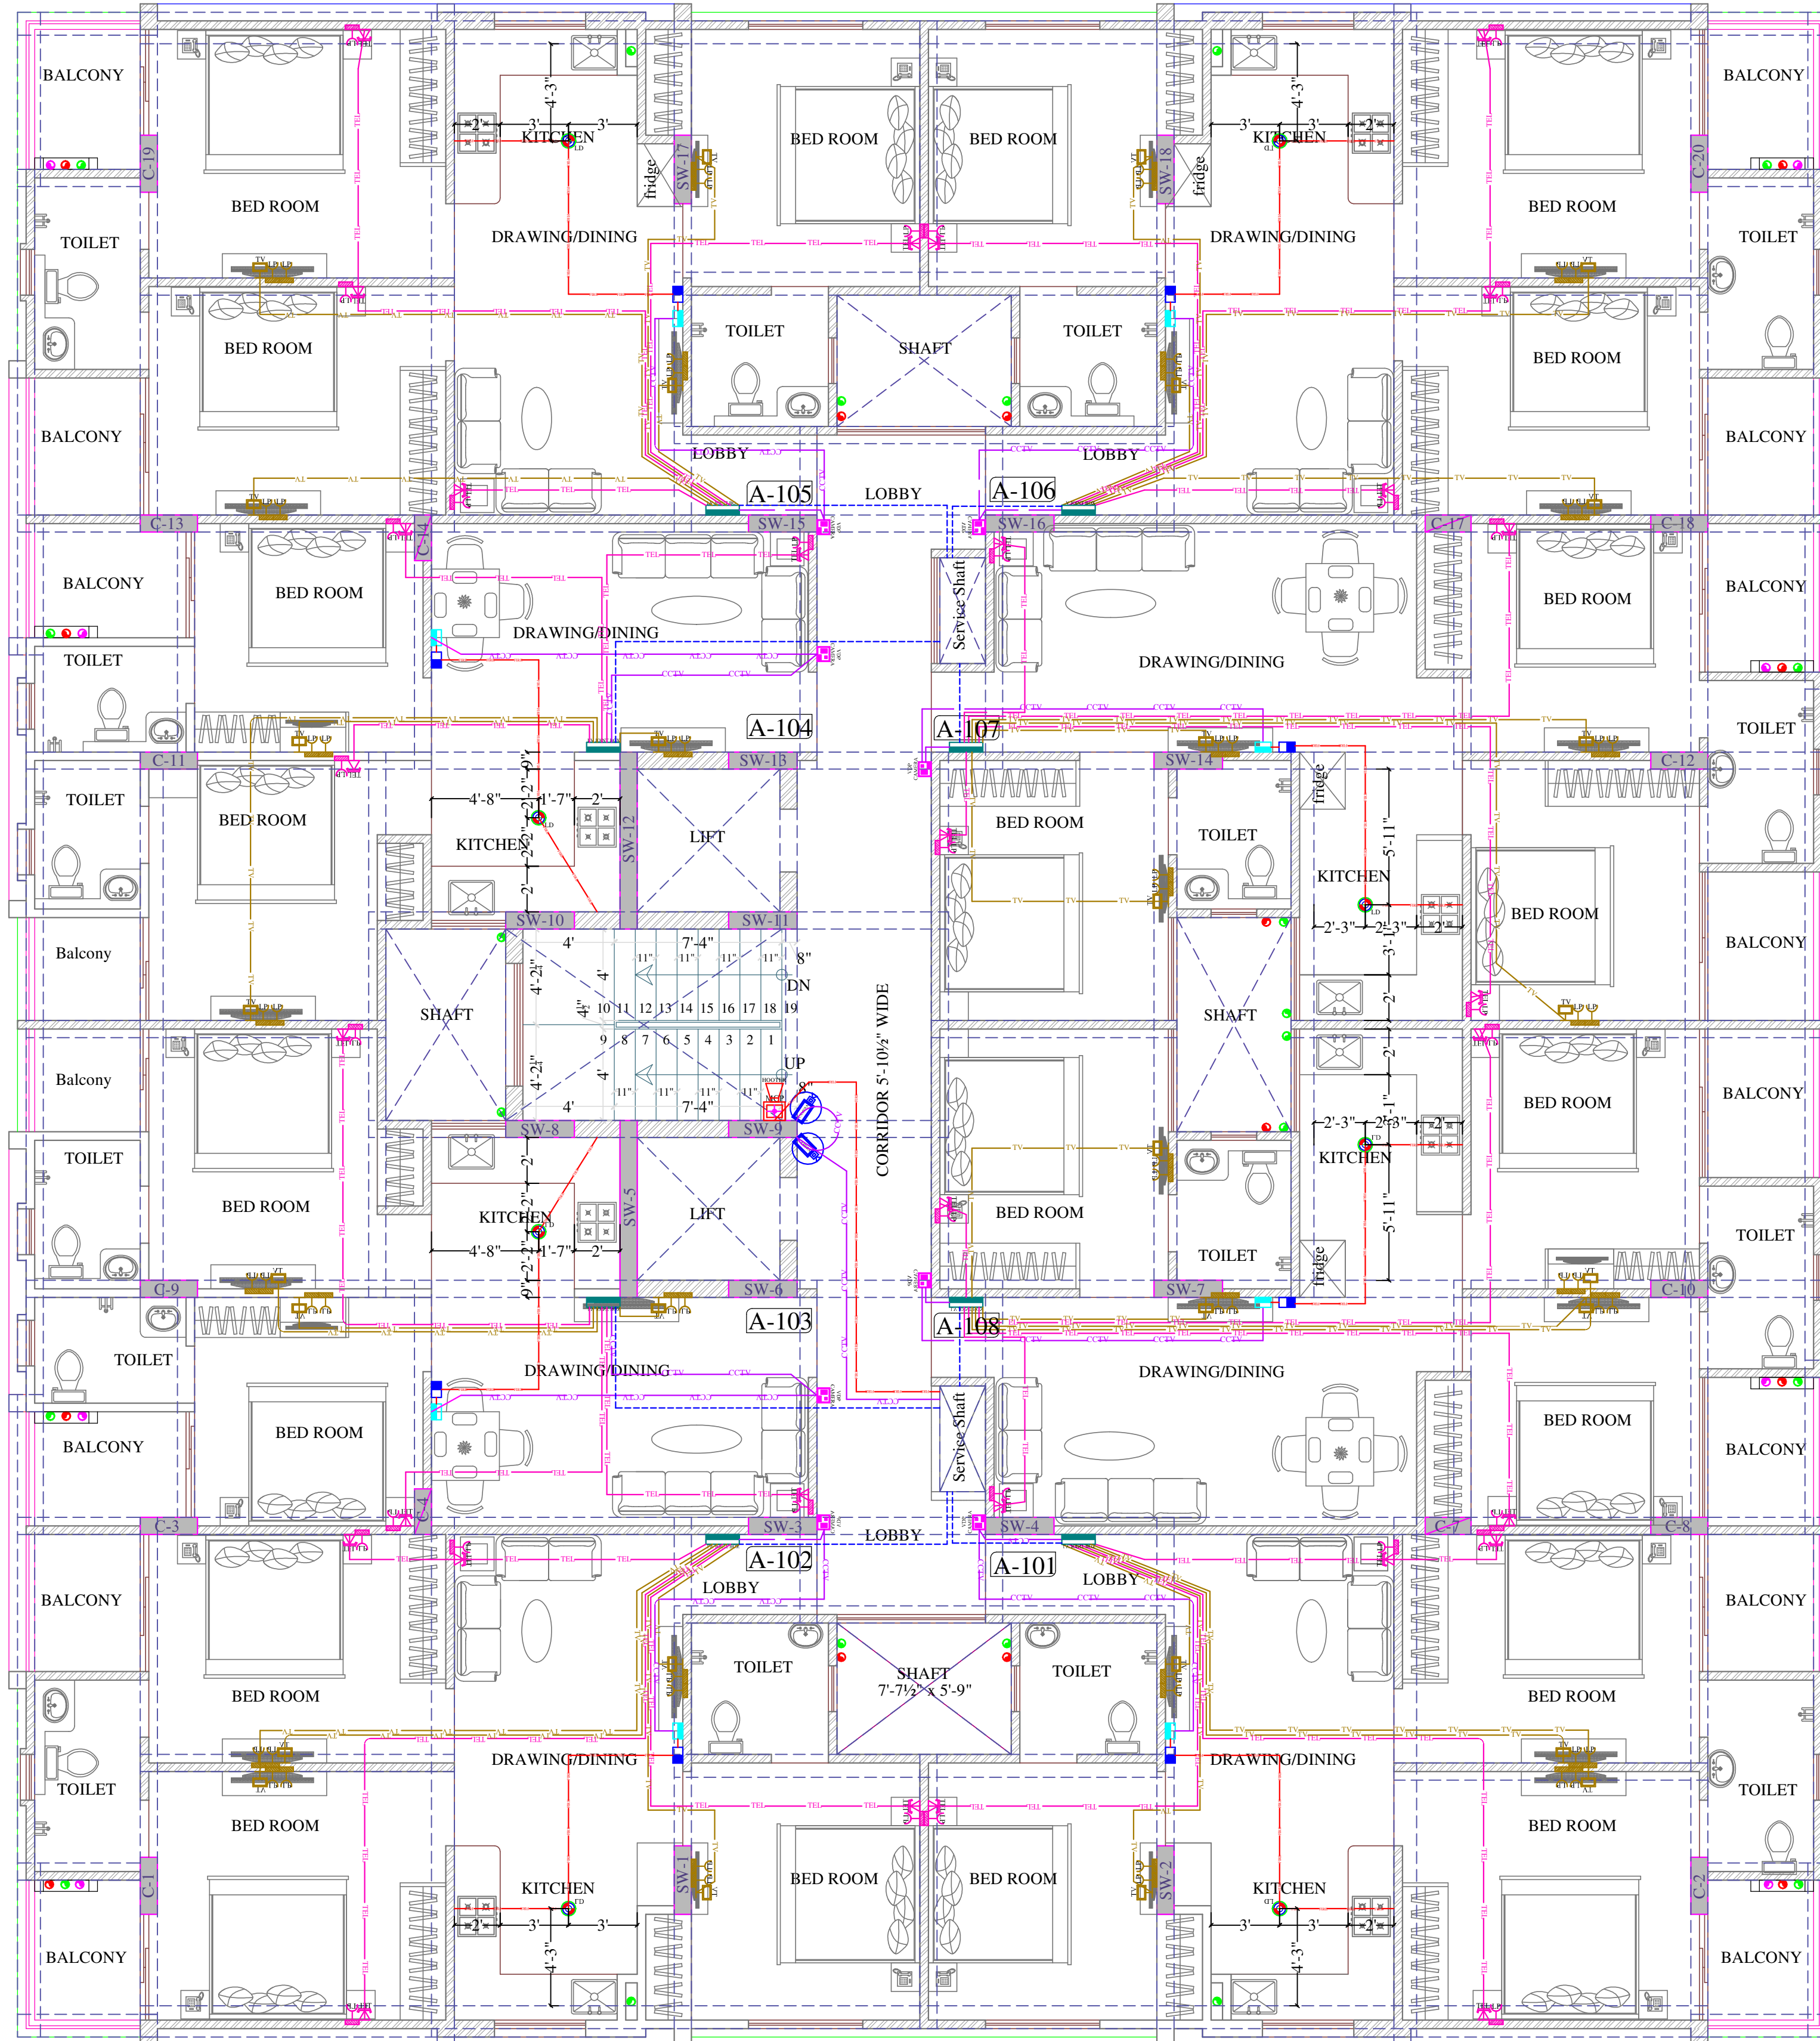

Vipul
VIPUL AGARWAL
M.E.P. CONSULTANT
B.E. ELECTRICAL

LEGENDS:					
Mounting Height	No.	I D	Symbol	Description	
IN FLOOR		CONDUIT	TEL	Rigid PVC 25mm dia. Conduit / 0.5mm 2 Pair Wire For Tel Wiring	
IN FLOOR		CONDUIT	TV	Rigid PVC 25mm dia. Conduit / RG6 Cable For TV Wiring	
IN RCC SLAB		CONDUIT		1Nos. 32 mm dia Conduits From Flat LV System to Drop LV Shaft	
IN RCC SLAB		CONDUIT	CCTV	Rigid PVC Conduit 25mm/3+1 Coaxial Wire/Cat-6 Cable for Video Door Phone & Security Camera (C.C.T.V.).	
IN RCC SLAB		CONDUIT	FIRE	Rigid PVC 25mm dia. Conduit / 2X1.5 sq. mm Copper Wire For Fire Alarm	
+60"	08	VDP CAMERA		VIDEO DOOR PHONE OUTDOOR UNIT WITH BUILT IN CAMERA	
+48"	08	VDP		VIDEO DOOR PHONE INDOOR UNIT	
+48"	08	PS		PANIC SWITCH	
CELLING	08	LD		LPG DETECTOR	
+24"	30	TEL		TELEPHONE POINT	
+24"	30	LP TEL		6 A PLUG POINT FOR TELEPHONE	
+48"	30	TV		TV COAXIAL POINT	
+48"	60	LP TV		6 A PLUG POINT FOR TV	
+42"	01	MCP		MANUAL CALL POINT	
+90"	01	HO		HOOTER POINT	
+90"	02	CCTV		WALL MOUNTED CCTV CAMERA	
+24"	08	LVS JB		LV SYSTEM JOINT BOX	

PROJECT NAME:- WONDER HOMES	PROJECT ADDRESS:- PROPOSED RESIDENTIAL BUILDING OF PLOT NO. R17/265, 266 , 266-A (NIJI KHATEDARI) SCHEME :- "INDRAPRASTH (CHORDIA CITY)" AJMER ROAD, JAIPUR."	DRAWING: BLOCK-A TYPICAL FLOOR (1st-5th) LV CONDUIT PLAN	DRN. BY:- VINOD KUMAR	DATE :- 24-09-2022	SERVICES CONSULTANT :- VIPUL CONSULTING, F 9 / 440 , Keshav Marg, Chitrakut Scheme,Jaipur PH:91-0-93146-10438 ,0141-2440946 Mail:vipul8599@yahoo.com	ARCHITECT :- SPACE GRID C-49,VIDYA APARTMENT,PARAS MARG, BAPU NAGAR,NEAR JANTA STORE CIRCLE, JAIPUR-302015 PH-09314918766,0141-4005506 (O) Email:-info.spacegrid@gmail.com	
PROMOTER:- VIVEK CHORDIA PROPRIETOR OF VIVANTA CORPORATION			CKD. BY:- SANJAY	REV. :- 00			
			APPD. BY:- VIPUL AGARWAL	SCALE:- N.T.S.			

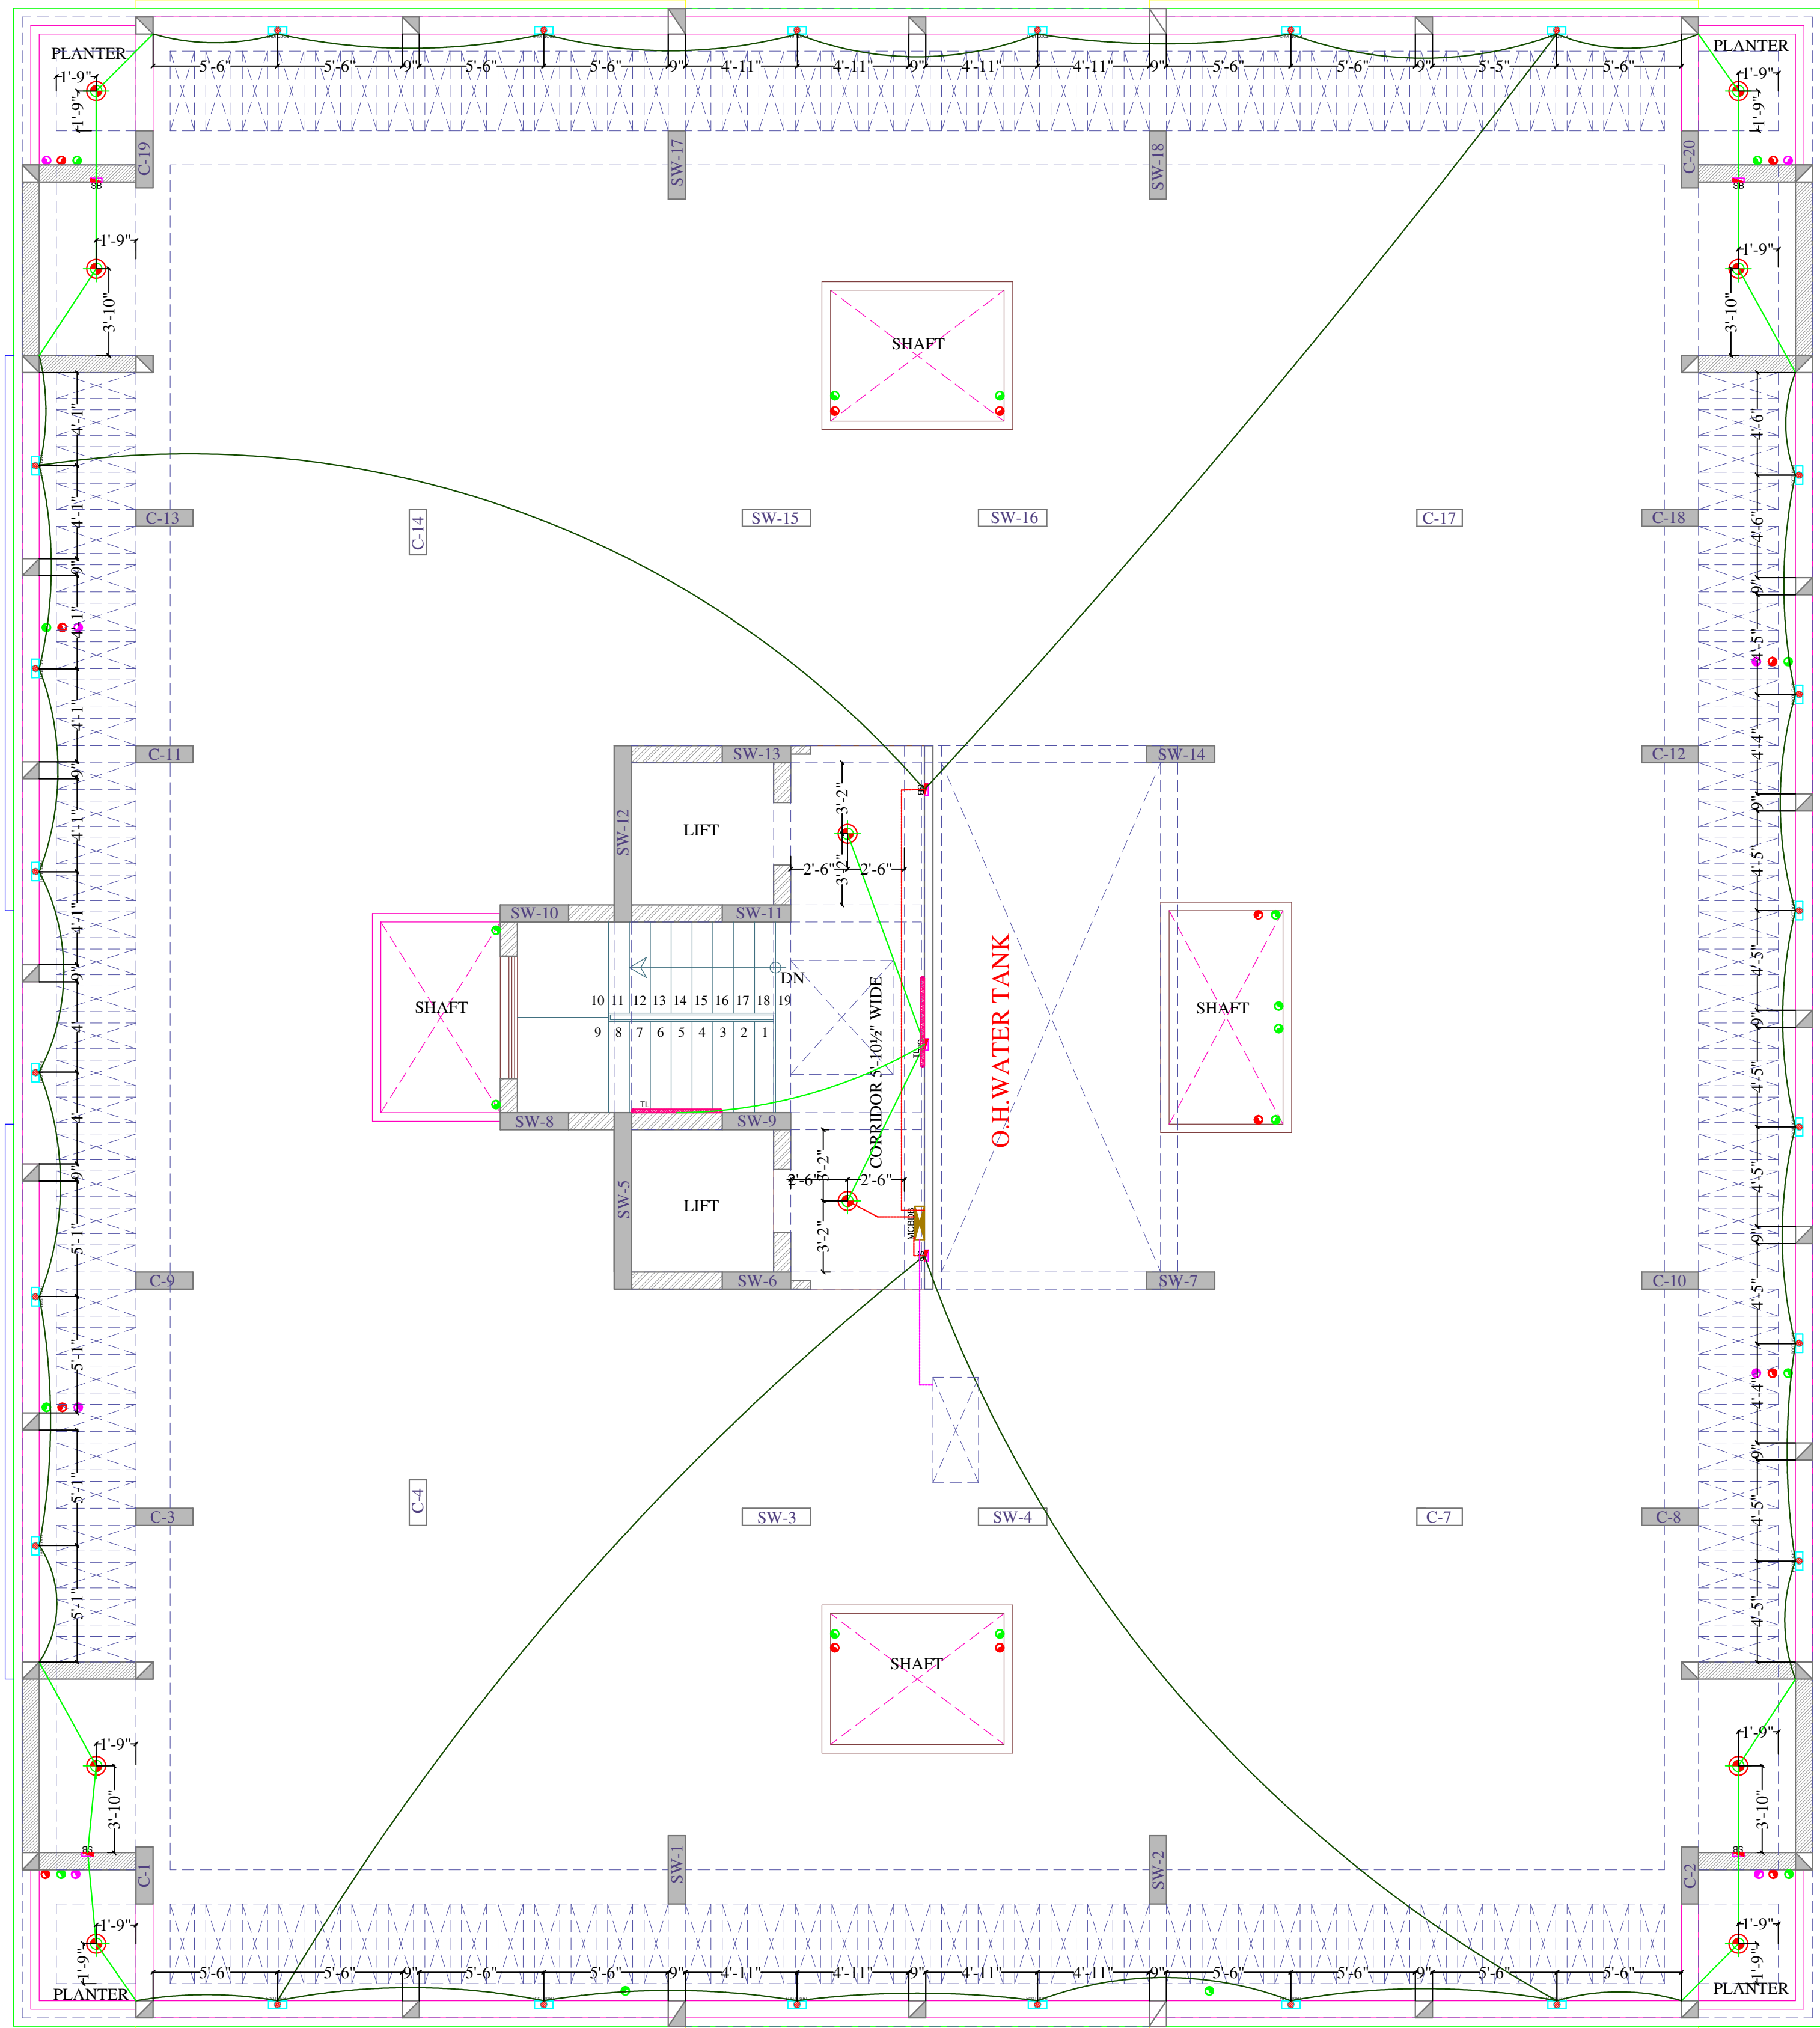

Vipul
VIPUL AGARWAL
M.E.P. CONSULTANT
B.E. ELECTRICAL

LEGENDS:

Mounting Height	QTY.	ID	SYMBOL	DESCRIPTION
IN FLOOR		CONDUIT		submain wire to db from ele. meater to db p ground floor in 1 nos, 32 mm dia conduits
IN RCC SLAB		CONDUIT		Rigid PVC Conduit 25mm/1.5 sqmm wire for Light points
IN FLOOR		CONDUIT		Rigid PVC Conduit 25mm/1.5 sqmm wire for Light points
IN RCC SLAB		CONDUIT		Rigid PVC Conduit 25mm/2.5 sqmm wire for Light Circuits
+90"	02	TL/W		Led Wall Tube Light Make:- Syska Led Cat no.- SSK-T5-20W
CEILING	10	DL		LED 6" DOWNLIGHTER 15W (SURFACE MOUNTED) MAKE SYSKA LED CAT NO.SDL-15W GLD 6.5K/4K
+42"	07	SB		SWITCH BOARD
+18"	24	FL		FOOOT LIGHT
+60"	01	DB		MCB DISTRIBUTION BOARD

PROJECT NAME:-

WONDER HOMES

PROMOTER:-

VIVEK CHORDIA
PROPRIETER OF
VIVANTA CORPORATION

PROJECT ADDRESS:-

PROPOSED RESIDENTIAL BUILDING OF
PLOT NO. R17/265, 266 & 266-A (NIJI
KHATEDARI) SCHEME :- "INDRAPRASTH
(CHORDIA CITY)" AJMER ROAD,
JAIPUR."

DRAWING:

BLOCK-A
TERRACE FLOOR
ELECTRIC CONDUIT PLAN

DRN. BY:-
ARUN

CKD. BY:-
SANJAY

APPD. BY:-
VIPUL AGARWAL

DATE : -
01-02-2023

REV. : -
00

SCALE:-
N.T.S.


SERVICES CONSULTANT :-

VIPUL CONSULTING,
F 9 / 440 , Keshav Marg,
Chitrakut Scheme,Jaipur
PH:91-0-93146-10438 ,0141-2440946
Mail:vipul8599@yahoo.com

ARCHITECT :-

SPACE GRID
C-49,VIDYA APARTMENT,PARAS MARG,
BAPU NAGAR,NEAR JANTA STORE
CIRCLE, JAIPUR-302015
PH-09314918766,0141-4005506 (O)
Email:-info.spacegrid@gmail.com




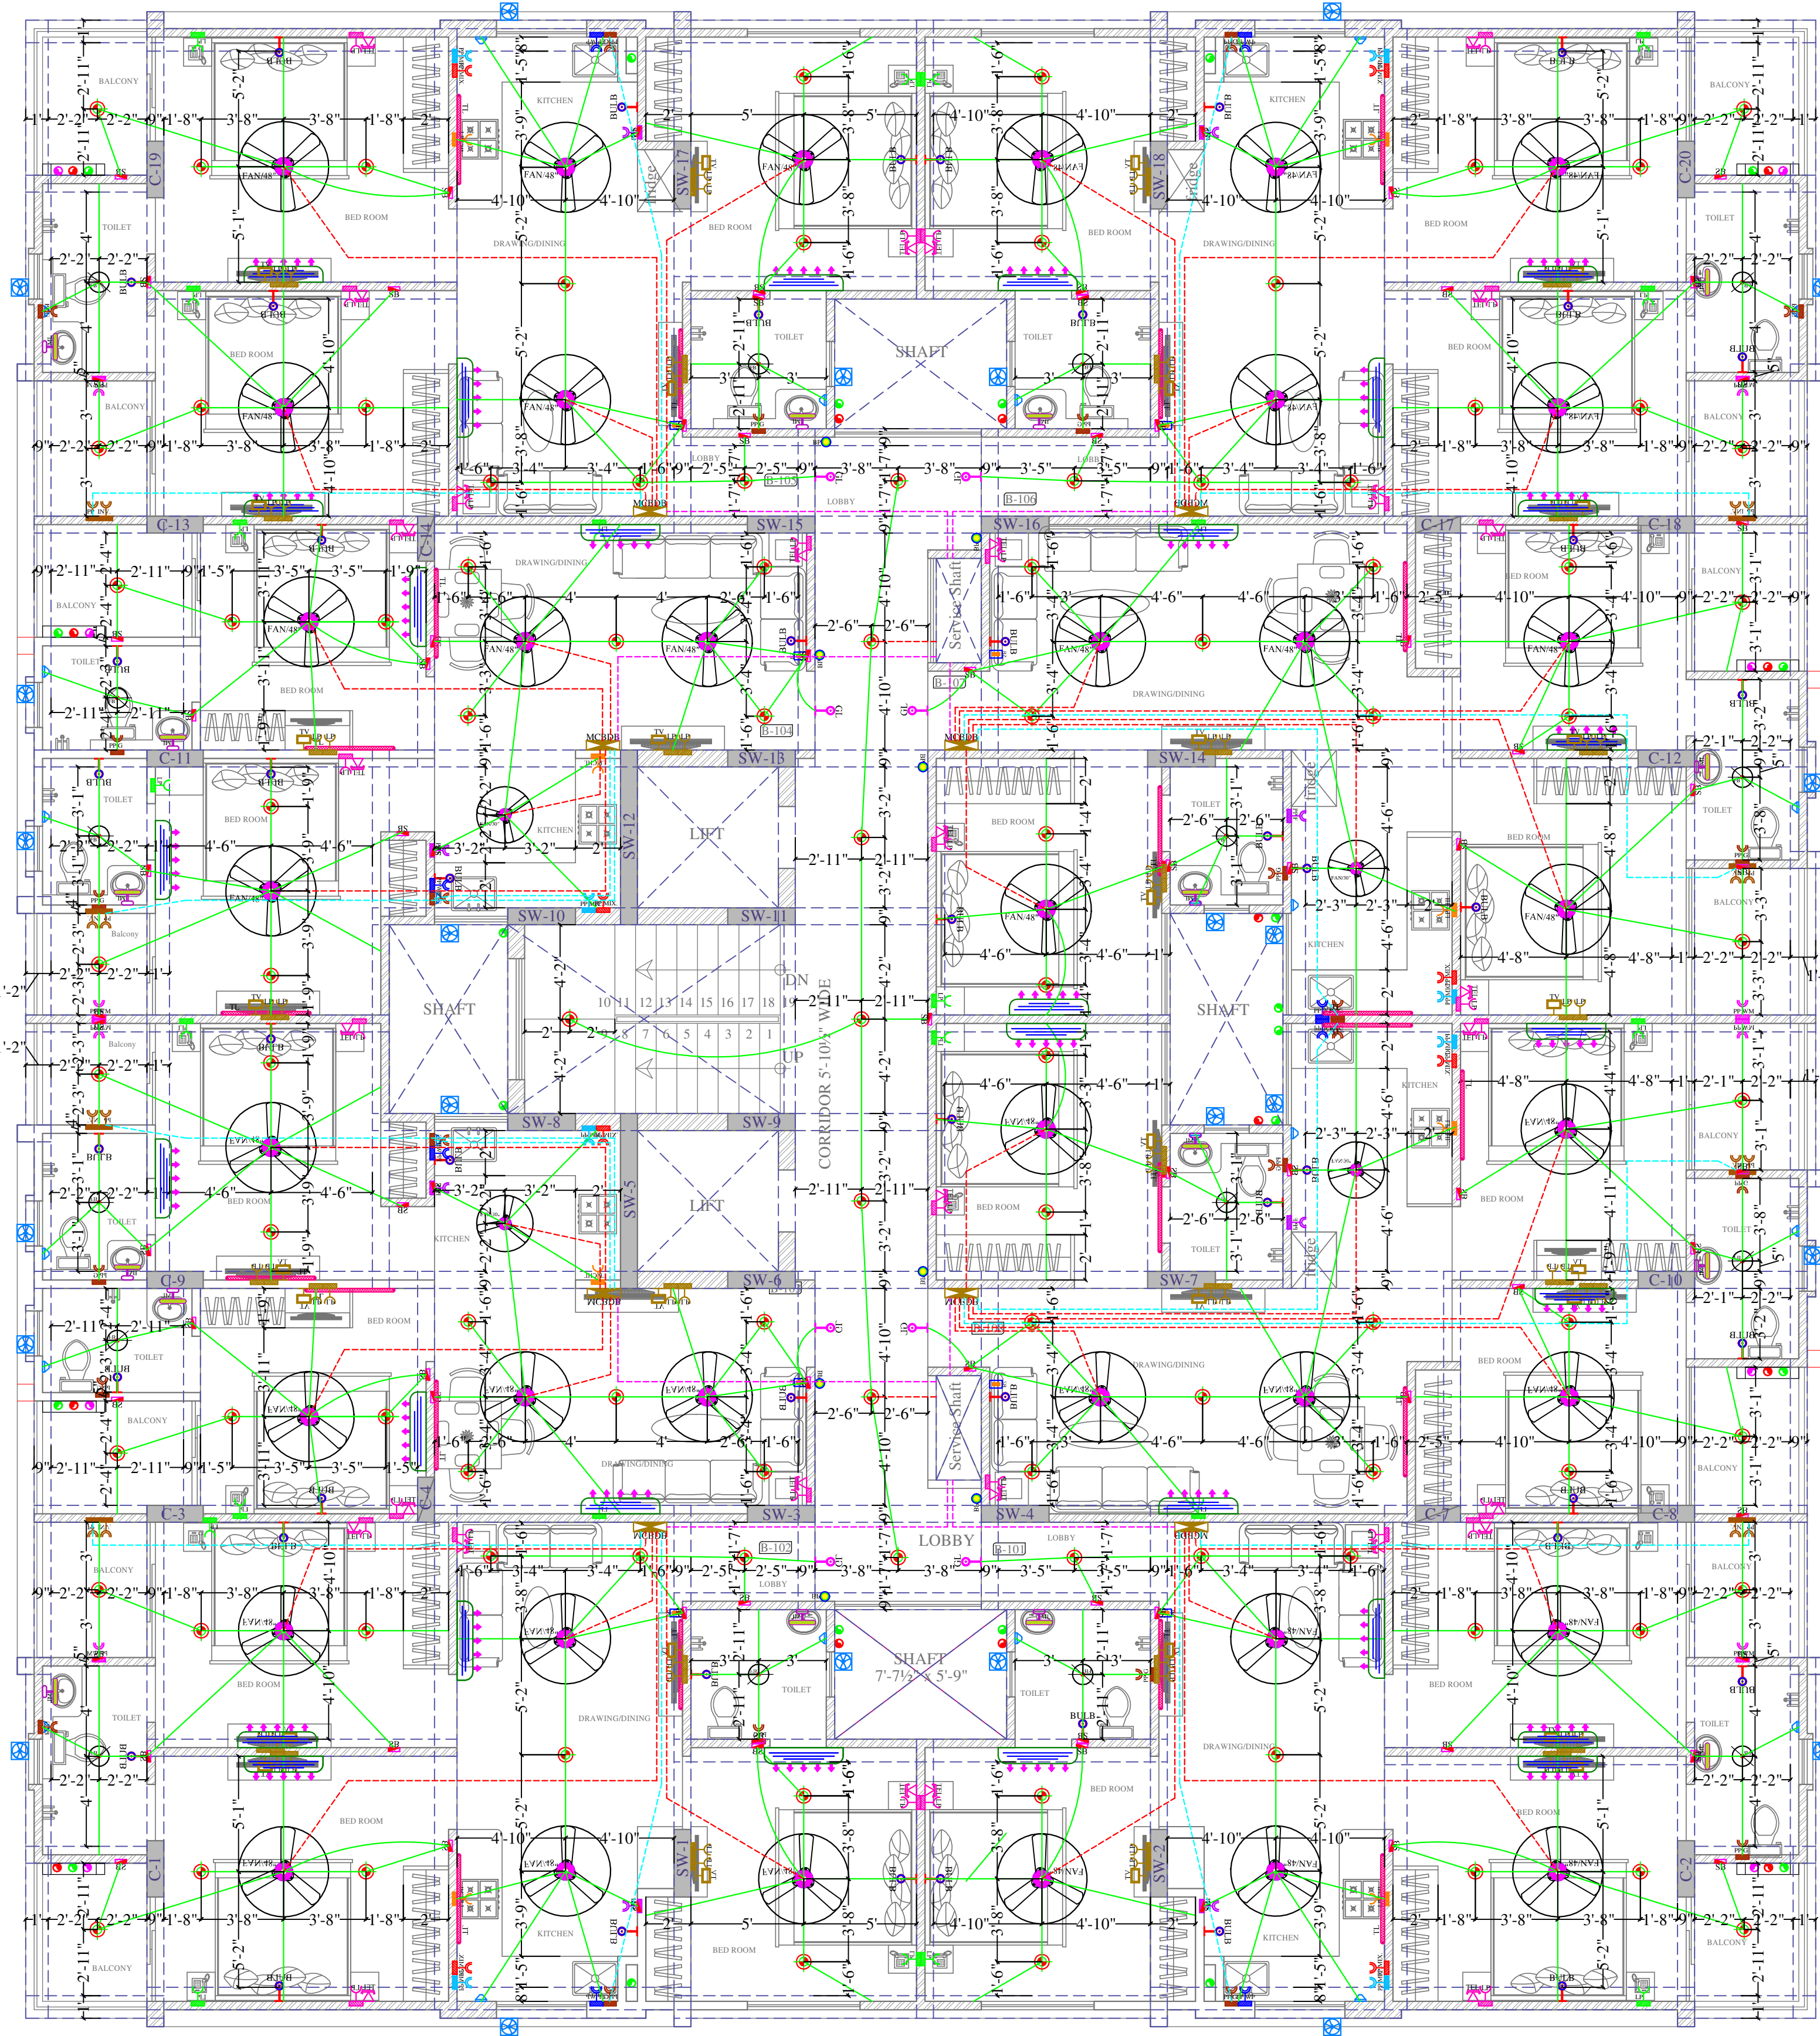

Vipul
VIPUL AGARWAL
M.E.P. CONSULTANT
B.E. ELECTRICAL


LEGENDS:					
Mounting Height	No.	I D	Symbol	Description	
IN RCC SLAB		CONDUIT		Rigid PVC 25mm dia. Conduit /1.5 sqmm Wire For Light Points	
IN RCC SLAB		CONDUIT		Rigid PVC 25mm dia. Conduit /2.5 sqmm Wire For Light Circuits	
IN RCC SLAB		CONDUIT		Rigid PVC 25mm dia. Conduit / 4.00 sqmm Wire For Power Circuits	
IN RCC SLAB		CONDUIT		Submain Wire to DB From Main Panel on Ground Floor in Inos. 32mm dia Conduits	
CEILING	38	FAN/48"		CEILING FAN 48"	
CEILING	04	FAN/30"		CEILING FAN 30"	
CEILING	16	FB		FAN BOX	
CEILING	00	CH1		CHANDELIER	
+90"	21	TL/W		Led Wall Tube Light Make:- Syska Led Cat no.- SSK-TS-20W	
+90"	49	BULB		Led Bulb 20W Make:- Syska Led Cat no. SKC-20W 5.7K/3K	
+90"	08	GL		WALL BRACKETS AS DESIGN FOR GANESH LIGHT	
+78"	16	ML		12x2 Led Mirror Light Make:- Syska Led Cat no:- FPL-12x2	
CEILING	100	DL		Led 6" Down Lighter 20W (Surface Mounted) Make:- Syska Led Cat no:- SDL-15W GLD 6.5K/4K	
VENTILATOR HT.	24	CR		CEILING ROSE	
VENTILATOR HT.	24	EXF		9" DIA FRESH AIR FAN	
+42"	79	SB		SWITCH BOARD	
+24"	30	TEL		TELEPHONE POINT	
+24"	30	LP TEL		6 A PLUG POINT FOR TELEPHONE	
+48"	30	TV		TV COAXIAL POINT	
+48"	60	LP TV		6 A PLUG POINT FOR TV	
+24"	22	LP		6 A PLUG POINT FOR SIDE TABLE	
+72"	08	LP-CH		6 A PLUG POINT FOR CHIMNEY	
+90"	32	SAC		SPLIT AC INDOOR UNIT	
+42"	08	PP-MIX		16 A POWER POINT FOR MIXER	
+42"	08	PP-MIC		16 A POWER POINT FOR MICROWAVE	
+78"	24	PP-G		16 A POWER POINT FOR GEYSER	
+54"	08	PP-F		16 A POWER POINT FOR FRIDGE	
+78"	08	PP-WP		16 A POWER POINT FOR WATER PURIFIER	
+48"	08	PP-WM		16 A POWER POINT FOR WASHING MACHINE	
+12"	16	PP-INV.		16 A POWER POINT FOR INVERTOR	
+60"	08	BP		6 A BELL PUSH	
+90"	08	BZ		BUZZER FOR CALL BELL	
+60"	08	MCB DB		MCB DISTRIBUTION BOARD	


PROJECT NAME:- WONDER HOMES PROMOTER:- VIVEK CHORDIA PROPRIETOR OF VIVANTA CORPORATION	PROJECT ADDRESS:- PROPOSED RESIDENTIAL BUILDING OF PLOT NO. R17/263, R17/264(NIJI KHATEDARI) SCHEME :- "INDRAPRASTH (CHORDIA CITY)" AJMER ROAD, JAIPUR."	DRAWING: BLOCK-B GROUND FLOOR ELECTRIC CONDUIT PLAN	DRN. BY:- VINOD KUMAR CKD. BY:- SANJAY APPD. BY:- VIPUL AGARWAL	DATE :- 13-07-2022 REV. :- 00 SCALE:- N.T.S.	SERVICES CONSULTANT :- VIPUL CONSULTING, F 9 / 440 , Keshav Marg, Chitrakut Scheme,Jaipur PH:91-0-93146-10438 ,0141-2440946 Mail:vipul8599@yahoo.com	ARCHITECT :- SPACE GRID C-49,VIDYA APARTMENT,PARAS MARG, BAPU NAGAR,NEAR JANTA STORE CIRCLE, JAIPUR-302015 PH-09314918766,0141-4005506 (O) Email:-info.spacegrid@gmail.com	
--	--	---	--	---	--	---	--

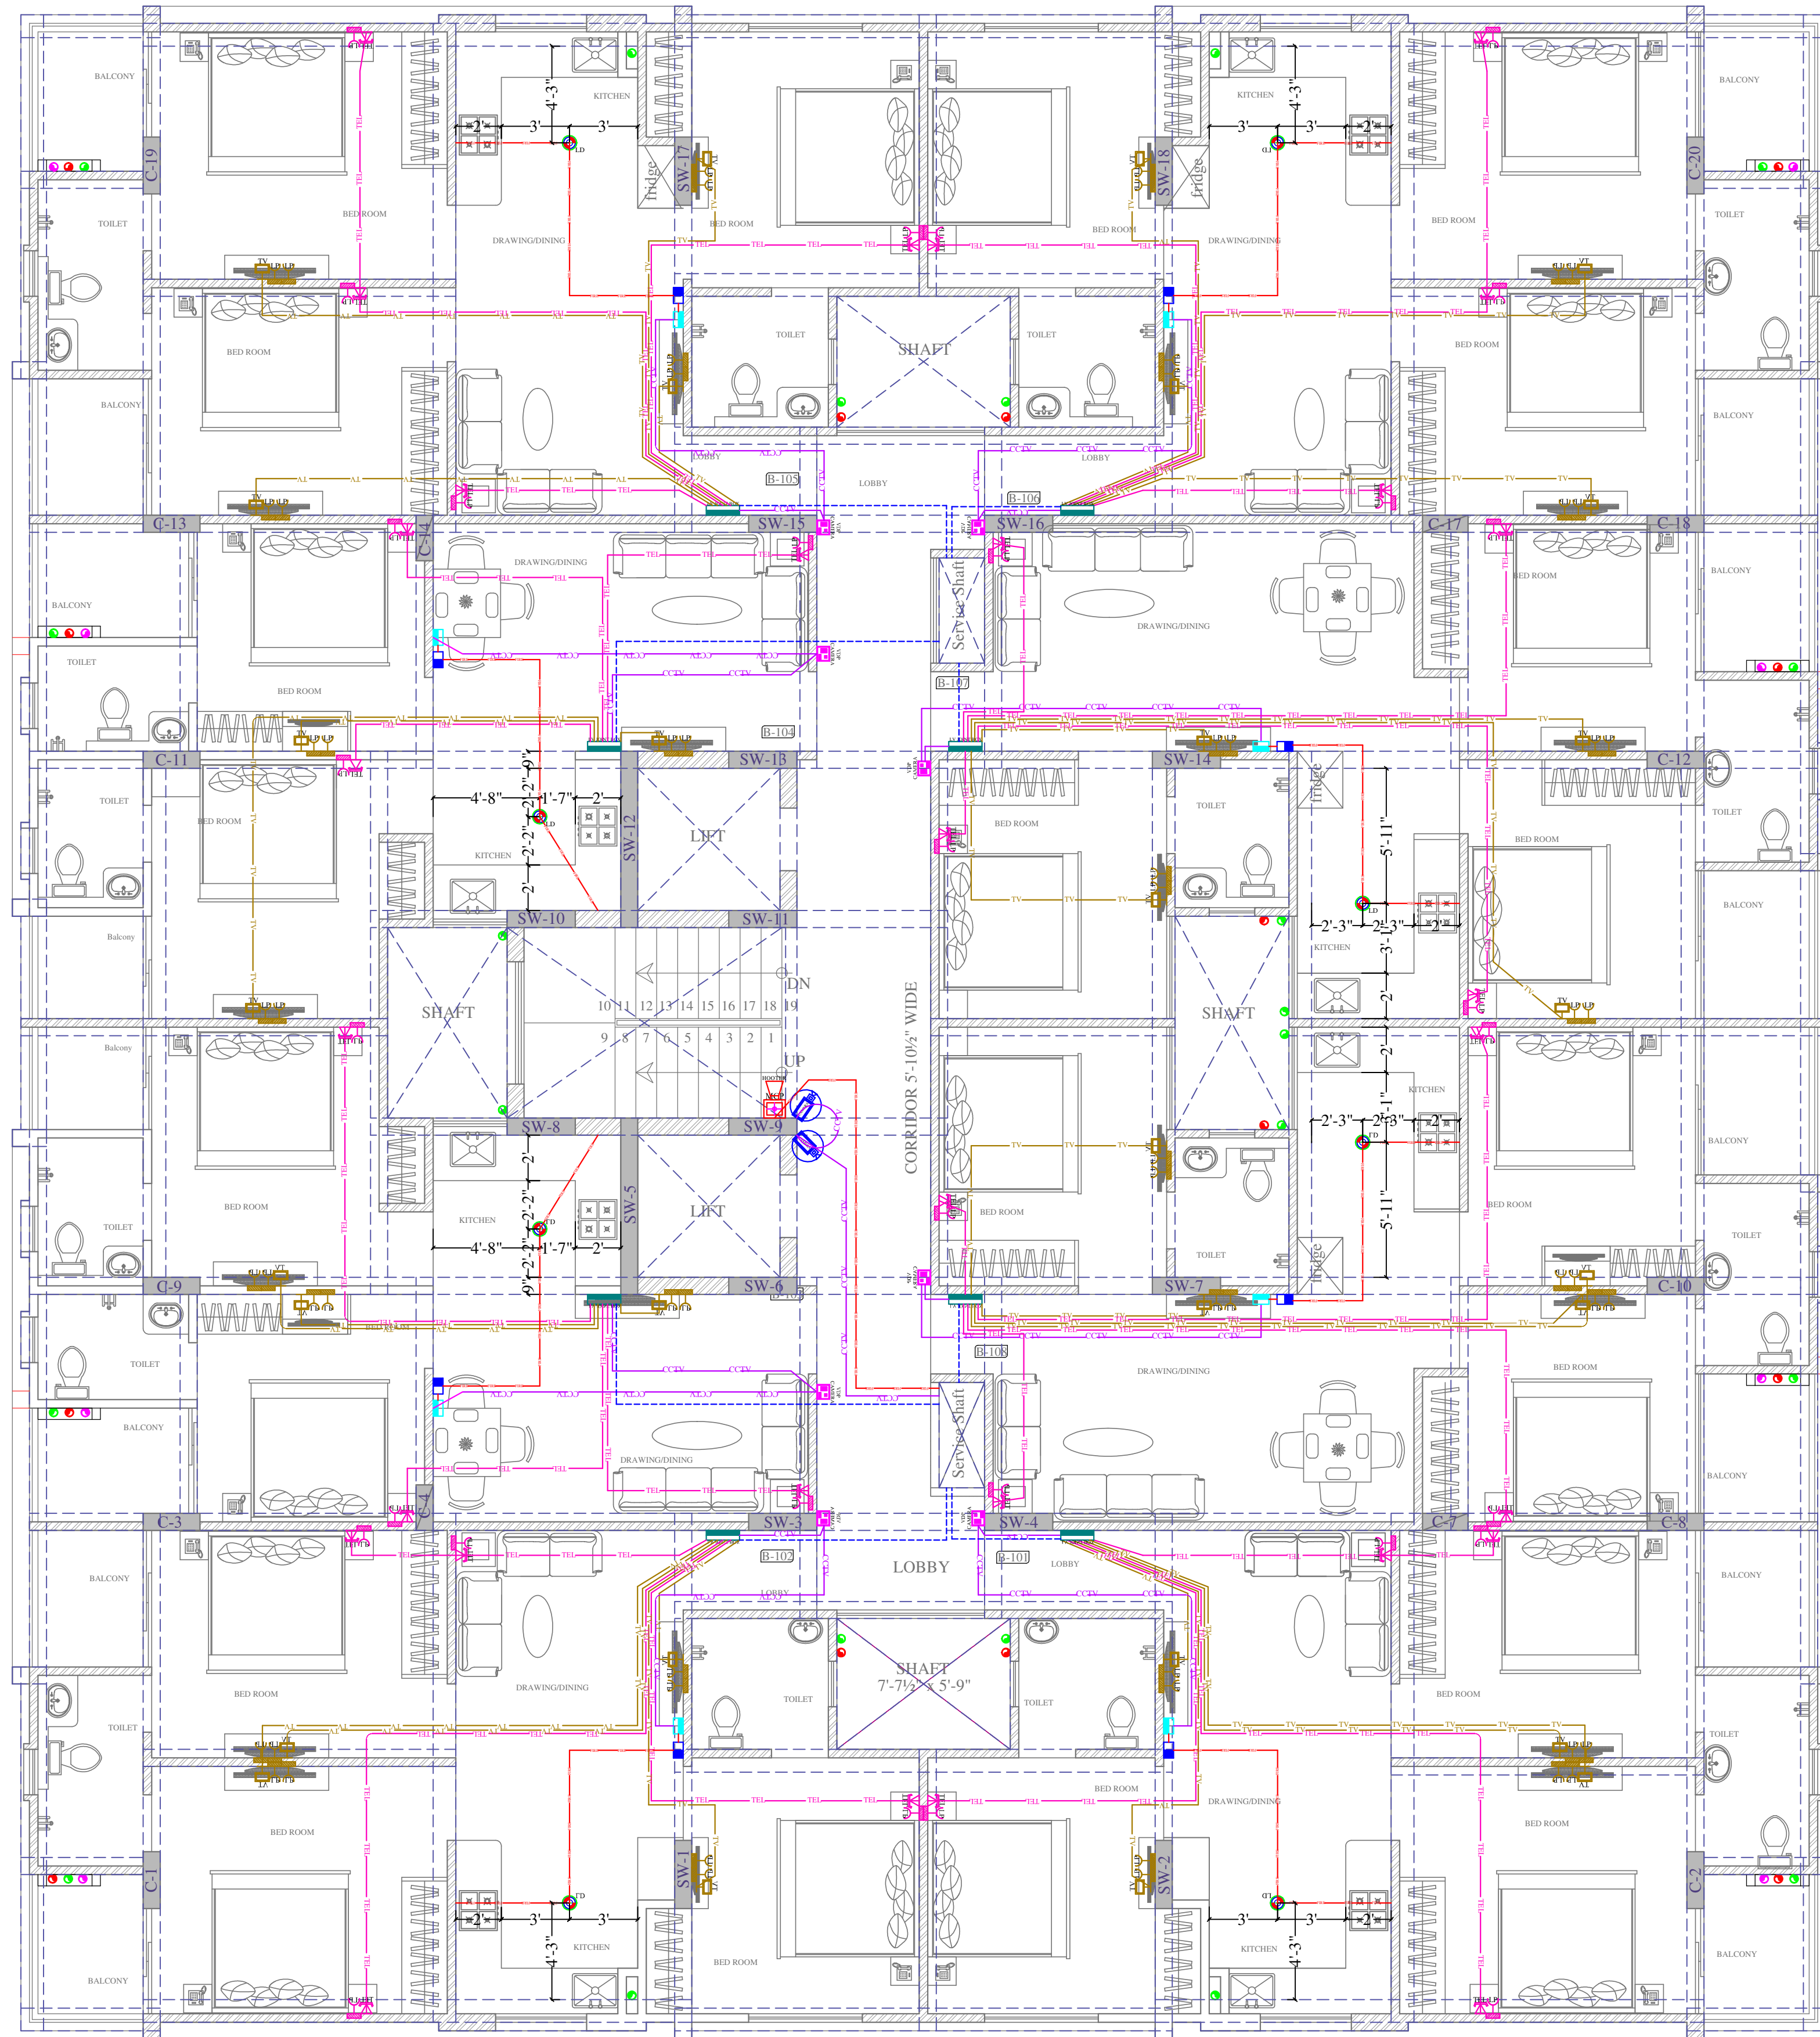

Vipul
VIPUL AGARWAL
M.E.P. CONSULTANT
B.E. ELECTRICAL

LEGENDS:					
Mounting Height	No.	ID	Symbol	Description	
IN FLOOR		CONDUIT		Rigid PVC 25mm dia. Conduit / 0.5mm 2 Pair Wire For Tel Wiring	
IN FLOOR		CONDUIT		Rigid PVC 25mm dia. Conduit / RG6 Cable For TV Wiring	
IN RCC SLAB		CONDUIT		1 Nos. 32 mm dia Conduits From Flat LV System to Drop LV Shaft	
IN RCC SLAB		CONDUIT		Rigid PVC Conduit 25mm/3+1 Coaxial Wire/Cat-6 Cable for Video Door Phone & Security Camera (C.C.T.V.).	
IN RCC SLAB		CONDUIT		Rigid PVC 25mm dia. Conduit / 2X1.5 sq. mm Copper Wire For Fire Alarm	
+60"	08	VDP CAMERA		VIDEO DOOR PHONE OUTDOOR UNIT WITH BUILT IN CAMERA	
+48"	08	VDP		VIDEO DOOR PHONE INDOOR UNIT	
+48"	08	PS		PANIC SWITCH	
CELLING	08	LD		LPG DETECTOR	
+24"	30	TEL		TELEPHONE POINT	
+24"	30	LP TEL		6 A PLUG POINT FOR TELEPHONE	
+48"	30	TV		TV COAXIAL POINT	
+48"	60	LP TV		6 A PLUG POINT FOR TV	
+42"	01	MCP		MANUAL CALL POINT	
+90"	01	HO		HOOTER POINT	
+90"	02	CCTV		WALL MOUNTED CCTV CAMERA	
+24"	08	LVS JB		LV SYSTEM JOINT BOX	

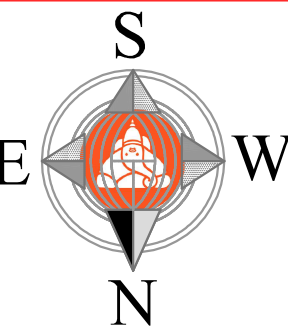
PROJECT NAME:- WONDER HOMES		PROJECT ADDRESS:- PROPOSED RESIDENTIAL BUILDING OF PLOT NO. R17/263, R17/264 (NIJI KHATEDARI) SCHEME :- "INDRAPRASTH (CHORDIA CITY)" AJMER ROAD, JAIPUR."	DRAWING: BLOCK-B GROUND FLOOR LV CONDUIT PLAN	DRN. BY:- VINOD KUMAR	DATE :- 13-07-2022	SERVICES CONSULTANT :- VIPUL CONSULTING, F 9 / 440 , Keshav Marg, Chitrakut Scheme,Jaipur PH:91-0-93146-10438 ,0141-2440946 Mail:vipul8599@yahoo.com	ARCHITECT :- SPACE GRID C-49,VIDYA APARTMENT,PARAS MARG, BAPU NAGAR,NEAR JANTA STORE CIRCLE, JAIPUR-302015 PH-09314918766,0141-4005506 (O) Email:-info.spacegrid@gmail.com	
PROMOTER:- VIVEK CHORDIA PROPRIETOR OF VIVANTA CORPORATION				CKD. BY:- SANJAY	REV. :- 00			
				APPD. BY:- VIPUL AGARWAL	SCALE:- N.T.S.			

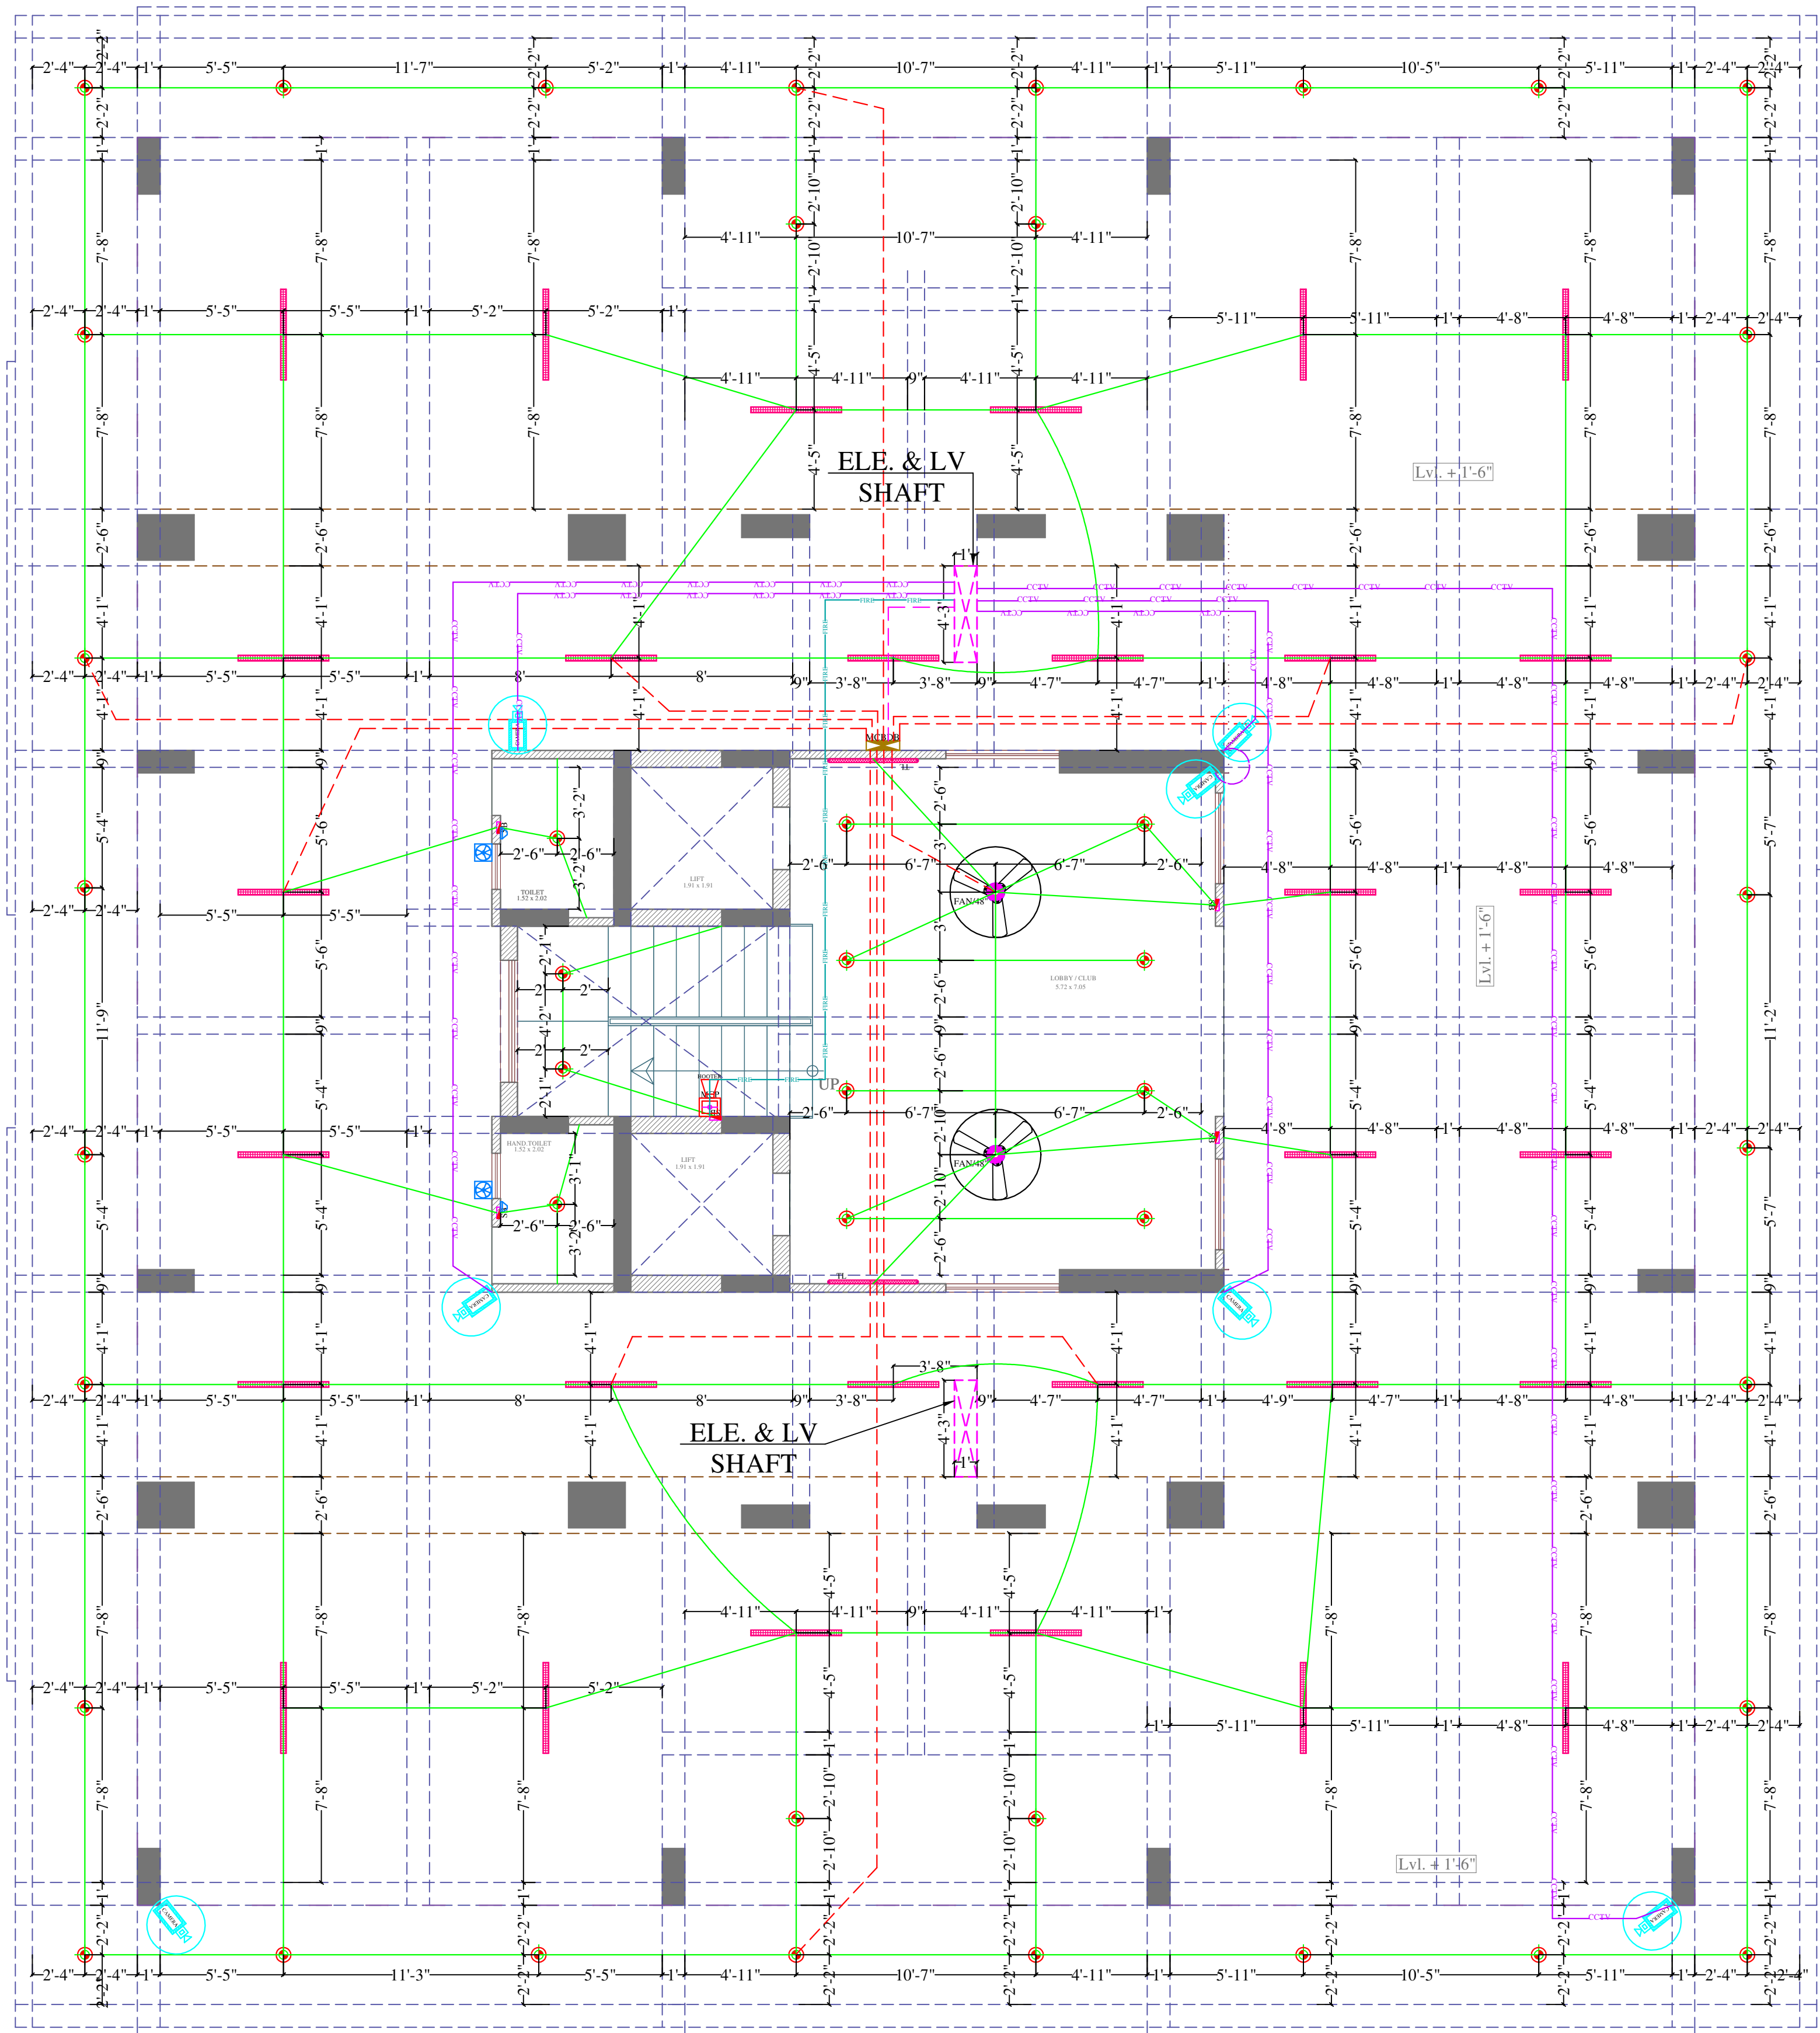

Vipul
VIPUL AGARWAL
M.E.P. CONSULTANT
B.E. ELECTRICAL

LEGENDS:					
Mounting Height	No.	I D	Symbol	Description	
IN RCC SLAB		CONDUIT		Rigid PVC 25mm dia. Conduit / 1.5 sqmm Wire For Light Points	
IN RCC SLAB		CONDUIT		Rigid PVC 25mm dia. Conduit / 2.5 sqmm Wire For Light Circuits	
IN RCC SLAB		CONDUIT		Rigid PVC 25mm dia. Conduit / 4.00 sqmm Wire For Power Circuits	
IN RCC SLAB		CONDUIT		Submain Wire to DB From Main Panel on Ground Floor in 1nos.	
IN RCC SLAB		CONDUIT		Rigid PVC 25mm dia. Conduit / 2X1.5 sq. mm Copper Wire For Fire Alarm	
IN RCC SLAB		CONDUIT		Rigid PVC 25mm dia. Conduit / 3+1 Coaxial Wire / Cat 6 UTP Cable For Security Camera (C.C.T.V.).	
CEILING	02	FAN/48"		CEILING FAN 48"	
CEILING	30			LED CEILING TUBE LIGHT MAKE:- SYSKA LED CAT NO.- SSK-TS-20W	
+90"	02	TL/W		LED WALL TUBE LIGHT MAKE:- SYSKA LED CAT NO.- SSK-TS-20W	
CEILING	44	DL		LED 6" DOWN LIGHTER 20W (SURFACE MOUNTED) MAKE:- SYSKA LED CAT NO.- SDL-15W GLD 6.5K/4K	
VENTILATOR HT.	02	CR		CEILING ROSE	
VENTILATOR HT.	02	EXF		9" DIA FRESH AIR FAN	
+42"	05	SB		SWITCH BOARD	
+60"	01	MCB DB		MCB DISTRIBUTION BOARD	
+42"	01	MCP		MANUAL CALL POINT	
+90"	01	HO		HOOTER POINT	
+90"	07	CCTV		WALL MOUNTED CCTV CAMERA	

PROJECT NAME:- WONDER HOMES PROMOTER:- VIVEK CHORDIA PROPRIETER OF VIVANTA CORPORATION	PROJECT ADDRESS:- PROPOSED RESIDENTIAL BUILDING OF PLOT NO. R17/263, R17/264(NUI KHATEDAR) SCHEME :- "INDRAPRASTH (CHORDIA CITY)" AJMER ROAD, JAIPUR."	DRAWING: BLOCK-B STILT FLOOR ELECTRIC & LV CONDUIT PLAN	DRN. BY:- RAJENDER CKD. BY:- SANJAY APPD. BY:- VIPUL AGARWAL	DATE :- 19-05-2022 REV. :- 00 SCALE:- N.T.S.	SERVICES CONSULTANT :- VIPUL CONSULTING, F 9 / 440 , Keshav Marg, Chitrakut Scheme,Jaipur PH:91-0-93146-10438 ,0141-2440946 Mail:vipul8599@yahoo.com	ARCHITECT :- SPACE_GRID C-49,VIDYA APARTMENT,PARAS MARG, BAPU NAGAR,NEAR JANTA STORE CIRCLE, JAIPUR-302015 PH-09314918766,0141-4005506 (O) Email:-info.spacegrid@gmail.com	
--	---	--	--	--	---	--	--

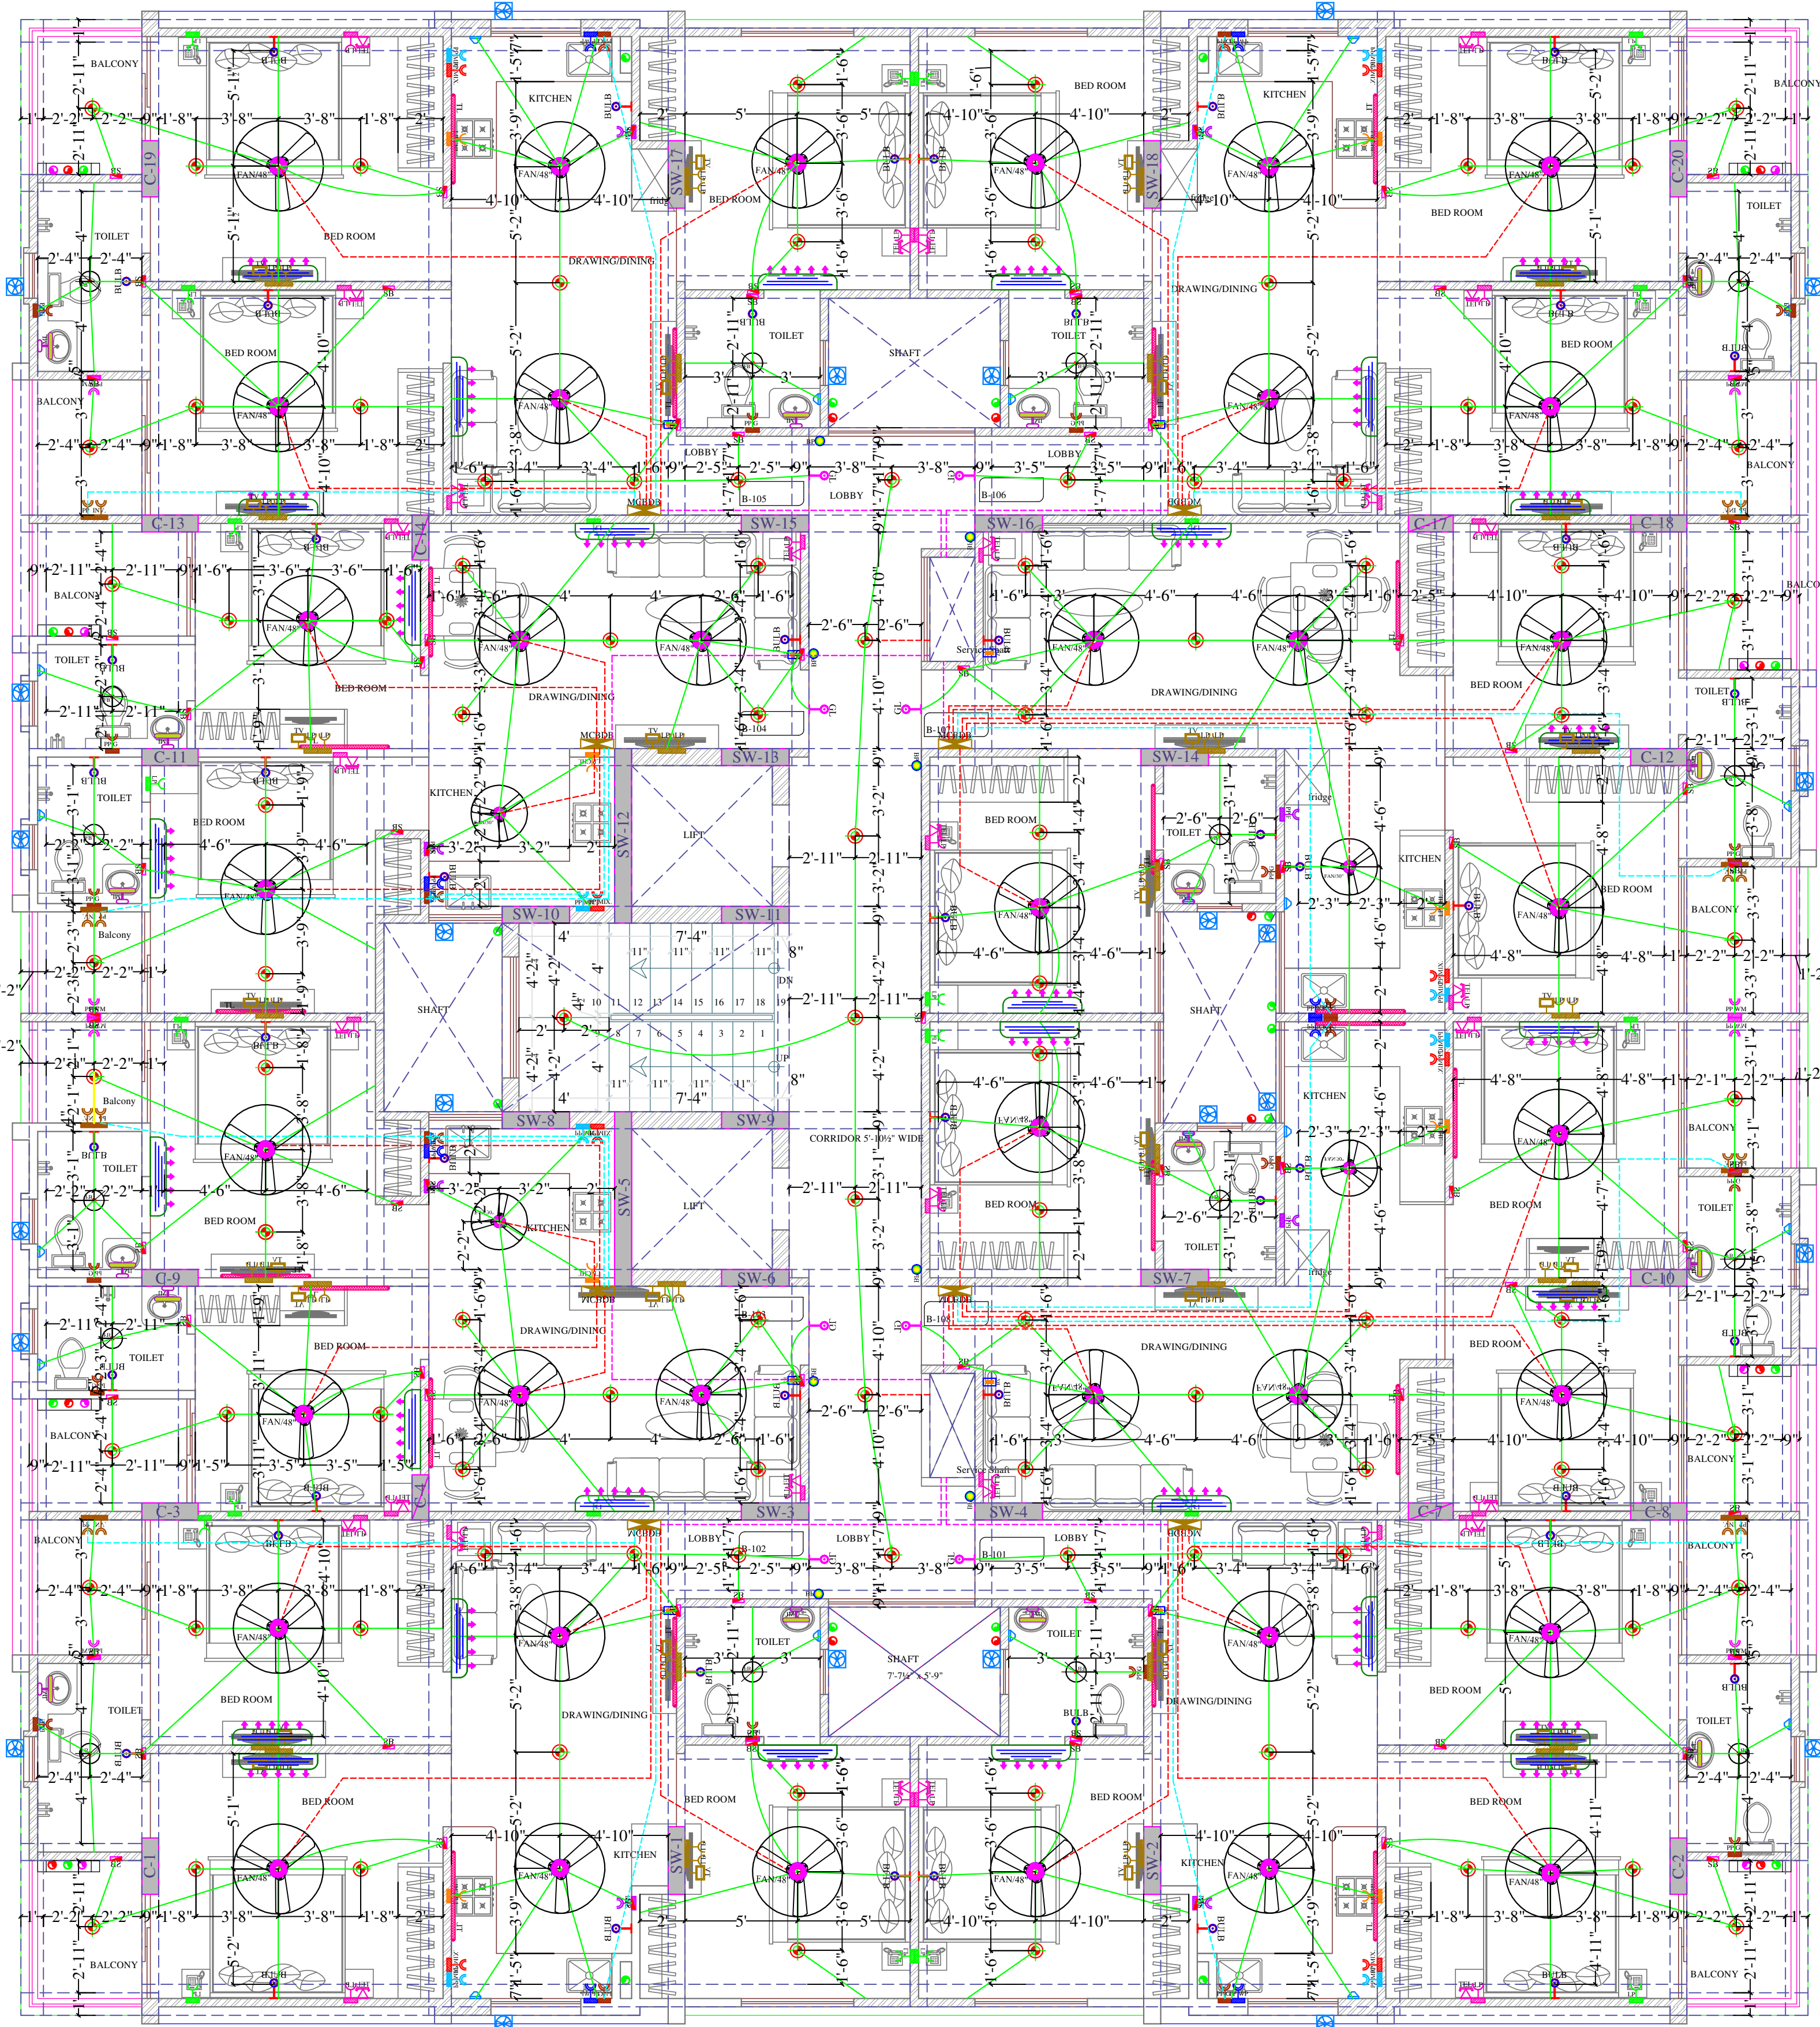


Vipul
VIPUL AGARWAL
M.E.P. CONSULTANT
B.E. ELECTRICAL

LEGENDS:

Mounting Height	No.	ID	Symbol	Description
IN RCC SLAB		CONDUIT		Rigid PVC 25mm dia. Conduit /1.5 sqmm Wire For Light Points
IN RCC SLAB		CONDUIT		Rigid PVC 25mm dia. Conduit /2.5 sqmm Wire For Light Circuits
IN RCC SLAB		CONDUIT		Rigid PVC 25mm dia. Conduit / 4.00 sqmm Wire For Power Circuits
IN RCC SLAB		CONDUIT		Submain Wire to DB From Main Panel on Ground Floor in Inos. 32mm dia Conduits
CEILING	38	FAN/48"		CEILING FAN 48"
CEILING	04	FAN/30"		CEILING FAN 30"
CEILING	16	FB		FAN BOX
CEILING	00	CH1		CHANDELIER
+90°	21	TL/W		Led Wall Tube Light Make:- Syska Led Cat no:- SSK-TS-20W
+90°	49	BULB		Led Bulb 20W Make:- Syska Led Cat no. SKC-20W 5.7K/3K
+90°	08	GL		WALL BRACKETS AS DESIGN FOR GANESH LIGHT
+78°	16	ML		12x2 Led Mirror Light Make:- Syska Led Cat no:- FPL-12x2
CEILING	100	DL		Led 6" Down Lighter 20W (Surface Mounted) Make:- Syska Led Cat no:- SDL-15W GLD 6.5K/4K
VENTILATOR HT.	24	CR		CEILING ROSE
VENTILATOR HT.	24	EXF		9" DIA FRESH AIR FAN
+42°	79	SB		SWITCH BOARD
+24°	30	TEL		TELEPHONE POINT
+24°	30	LP TEL		6 A PLUG POINT FOR TELEPHONE
+48°	30	TV		TV COAXIAL POINT
+48°	60	LP TV		6 A PLUG POINT FOR TV
+24°	22	LP		6 A PLUG POINT FOR SIDE TABLE
+72°	08	LP-CH		6 A PLUG POINT FOR CHIMNEY
+90°	32	SAC		SPLIT AC INDOOR UNIT
+42°	08	PP-MIX		16 A POWER POINT FOR MIXER
+42°	08	PP-MIC		16 A POWER POINT FOR MICROWAVE
+78°	24	PP-G		16 A POWER POINT FOR GEYSER
+54°	08	PP-F		16 A POWER POINT FOR FRIDGE
+78°	08	PP-WP		16 A POWER POINT FOR WATER PURIFIER
+48°	08	PP-WM		16 A POWER POINT FOR WASHING MACHINE
+12°	16	PP-INV.		16 A POWER POINT FOR INVERTOR
+60°	08	BP		6 A BELL PUSH
+90°	08	BZ		BUZZER FOR CALL BELL
+60°	08	MCB DB		MCB DISTRIBUTION BOARD


PROJECT NAME:- WONDER HOMES	PROJECT ADDRESS:- PROPOSED RESIDENTIAL BUILDING OF PLOT NO. R17/263, R17/264(NUI KHATEDARI) SCHEME :- "INDRAPRASTH (CHORDIA CITY)" AMER ROAD, JAIPUR."	DRAWING: BLOCK-B TYPICAL FLOOR (1st-5th) ELECTRIC CONDUIT PLAN	DRN. BY:- VINOD KUMAR	DATE :- 24-09-2022	SERVICES CONSULTANT :- VIPUL CONSULTING, F 9 / 440 , Keshav Marg, Chitrakut Scheme,Jaipur PH:91-0-93146-10438, 0141-2440946 Mail:vipul8599@yahoo.com	ARCHITECT :- SPACE GRID C-49,VIDYA APARTMENT,PARAS MARG, BAPU NAGAR,NEAR JANTA STORE CIRCLE, JAIPUR-302015 PH-09314918766,0141-4005506 (O) Email-info.spacegrid@gmail.com	
PROMOTER:- VIVEK CHORDIA PROPRIETER OF VIVANTA CORPORATION			CKD. BY:- SANJAY	REV. :- 00			
			APPD. BY:- VIPUL AGARWAL	SCALE:- N.T.S.			

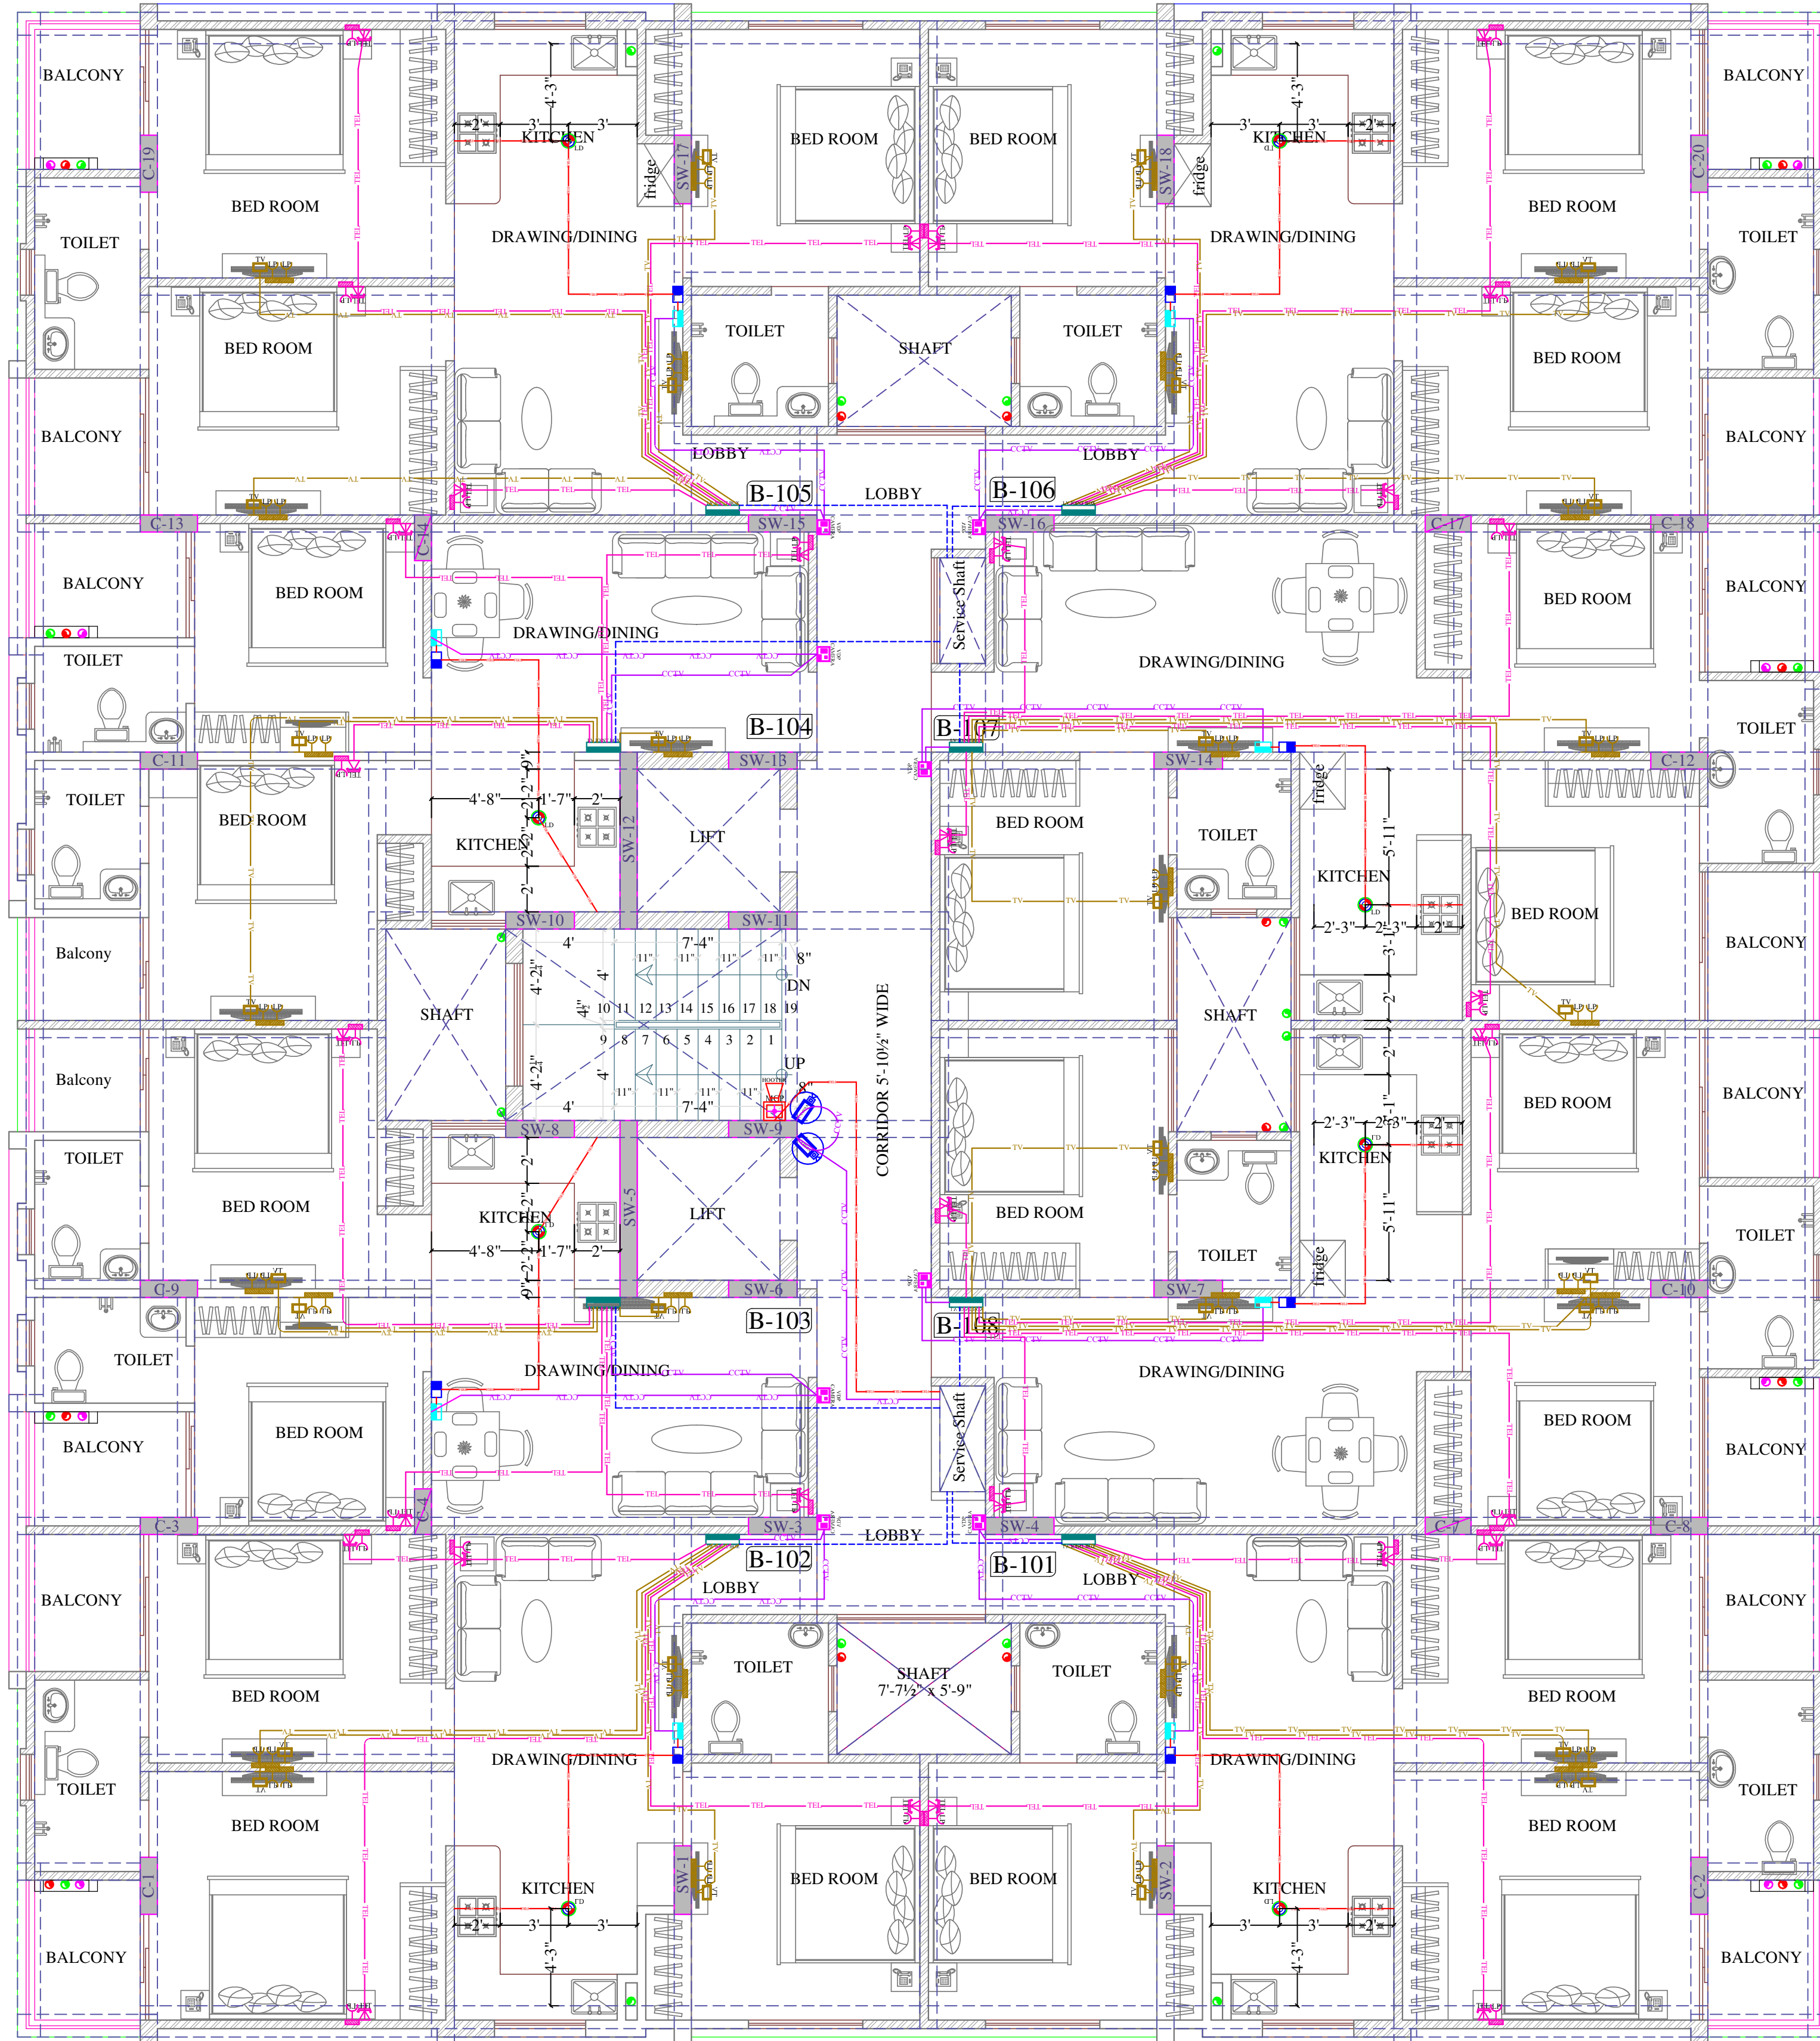

Vipul
VIPUL AGARWAL
M.E.P. CONSULTANT
B.E. ELECTRICAL

LEGENDS:					
Mounting Height	No.	I D	Symbol	Description	
IN FLOOR		CONDUIT	TEL	Rigid PVC 25mm dia. Conduit / 0.5mm 2 Pair Wire For Tel Wiring	
IN FLOOR		CONDUIT	TV	Rigid PVC 25mm dia. Conduit / RG6 Cable For TV Wiring	
IN RCC SLAB		CONDUIT		1Nos. 32 mm dia Conduits From Flat LV System to Drop LV Shaft	
IN RCC SLAB		CONDUIT	CCTV	Rigid PVC Conduit 25mm/3+1 Coaxial Wire/Cat-6 Cable for Video Door Phone & Security Camera (C.C.T.V.).	
IN RCC SLAB		CONDUIT	FIRE	Rigid PVC 25mm dia. Conduit / 2X1.5 sq. mm Copper Wire For Fire Alarm	
+60"	08	VDP CAMERA		VIDEO DOOR PHONE OUTDOOR UNIT WITH BUILT IN CAMERA	
+48"	08	VDP		VIDEO DOOR PHONE INDOOR UNIT	
+48"	08	PS		PANIC SWITCH	
CELLING	08	LD		LPG DETECTOR	
+24"	30	TEL		TELEPHONE POINT	
+24"	30	LP TEL		6 A PLUG POINT FOR TELEPHONE	
+48"	30	TV		TV COAXIAL POINT	
+48"	60	LP TV		6 A PLUG POINT FOR TV	
+42"	01	MCP		MANUAL CALL POINT	
+90"	01	HO		HOOTER POINT	
+90"	02	CCTV		WALL MOUNTED CCTV CAMERA	
+24"	08	LVS JB		LV SYSTEM JOINT BOX	

PROJECT NAME:- WONDER HOMES	PROJECT ADDRESS:- PROPOSED RESIDENTIAL BUILDING OF PLOT NO. R17/263, R17/264 (NIJI KHATEDARI) SCHEME :- "INDRAPRASTH (CHORDIA CITY)" AJMER ROAD, JAIPUR."	DRAWING: BLOCK-B TYPICAL FLOOR (1st-5th) LV CONDUIT PLAN	DRN. BY:- VINOD KUMAR	DATE :- 24-09-2022	SERVICES CONSULTANT :- VIPUL CONSULTING, F 9 / 440 , Keshav Marg, Chitrakut Scheme,Jaipur PH:91-0-93146-10438 ,0141-2440946 Mail:vipul8599@yahoo.com	ARCHITECT :- SPACE GRID C-49,VIDYA APARTMENT,PARAS MARG, BAPU NAGAR,NEAR JANTA STORE CIRCLE, JAIPUR-302015 PH-09314918766,0141-4005506 (O) Email:-info.spacegrid@gmail.com	S N
PROMOTER:- VIVEK CHORDIA PROPRIETOR OF VIVANTA CORPORATION			CKD. BY:- SANJAY	REV. :- 00			
			APPD. BY:- VIPUL AGARWAL	SCALE:- N.T.S.			

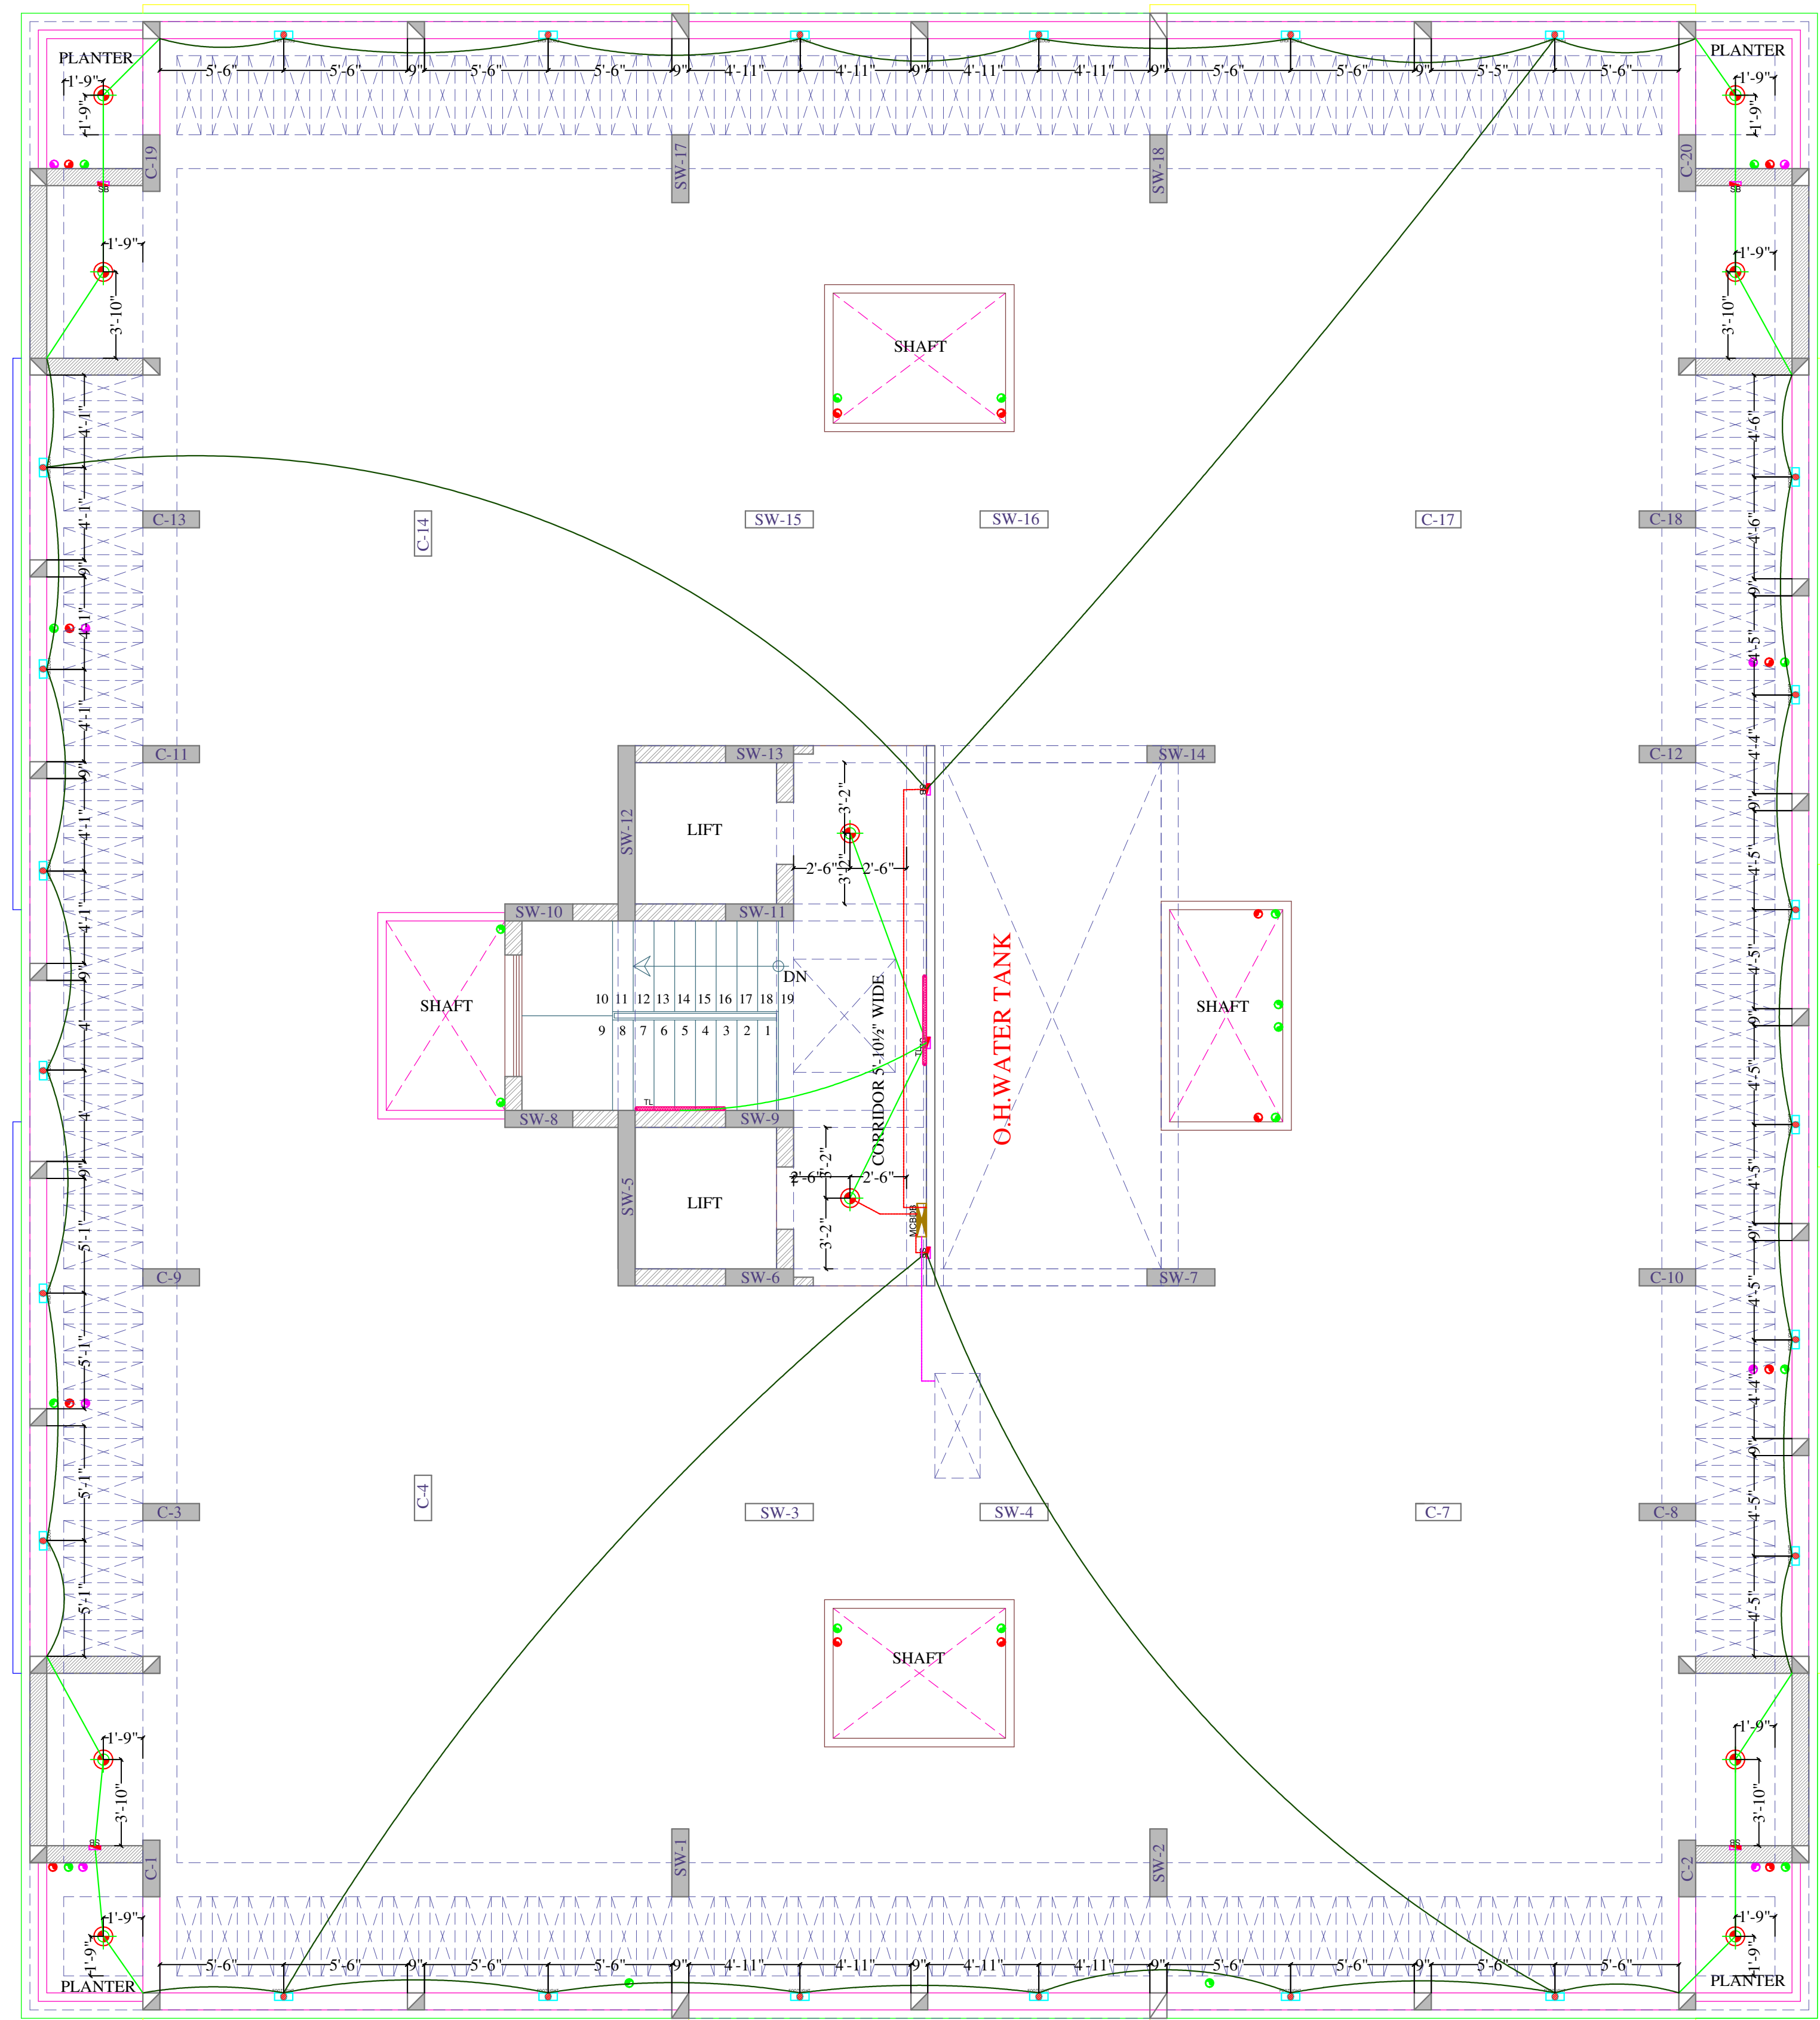

Vipul
VIPUL AGARWAL
M.E.P. CONSULTANT
B.E. ELECTRICAL

LEGENDS:

Mounting Height	QTY.	ID	SYMBOL	DESCRIPTION
IN FLOOR		CONDUIT		submain wire to db from ele. meater to db p ground floor in 1 nos, 32 mm dia conduits
IN RCC SLAB		CONDUIT		Rigid PVC Conduit 25mm/1.5 sqmm wire for Light points
IN FLOOR		CONDUIT		Rigid PVC Conduit 25mm/1.5 sqmm wire for Light points
IN RCC SLAB		CONDUIT		Rigid PVC Conduit 25mm/2.5 sqmm wire for Light Circuits
+90"	02	TL/W		Led Wall Tube Light Make:- Syska Led Cat no.- SSK-T5-20W
CEILING	10	DL		LED 6" DOWNLIGHTER 15W (SURFACE MOUNTED) MAKE SYSKA LED CAT NO.SDL-15W GLD 6.5K/4K
+42"	07	SB		SWITCH BOARD
+18"	24	FL		FOOOT LIGHT
+60"	01	DB		MCB DISTRIBUTION BOARD

PROJECT NAME:- WONDER HOMES	PROJECT ADDRESS:- PROPOSED RESIDENTIAL BUILDING OF PLOT NO. R17/263, R17/264(NIJI KHATEDARI) SCHEME :- "INDRAPRASTH (CHORDIA CITY)" AJMER ROAD, JAIPUR."	DRAWING: BLOCK-B TERRACE FLOOR ELECTRIC CONDUIT PLAN	DRN. BY:- ARUN	DATE : - 01-02-2023	SERVICES CONSULTANT :- VIPUL CONSULTING, F 9 / 440 , Keshav Marg, Chitrakut Scheme,Jaipur PH:91-0-93146-10438 ,0141-2440946 Mail:vipul8599@yahoo.com	ARCHITECT :- SPACE GRID C-49,VIDYA APARTMENT,PARAS MARG, BAPU NAGAR,NEAR JANTA STORE CIRCLE, JAIPUR-302015 PH-09314918766,0141-4005506 (O) Email:-info.spacegrid@gmail.com	
PROMOTER:- VIVEK CHORDIA PROPRIETER OF VIVANTA CORPORATION			CKD. BY:- SANJAY	REV. : - 00			
			APPD. BY:- VIPUL AGARWAL	SCALE:- N.T.S.			