



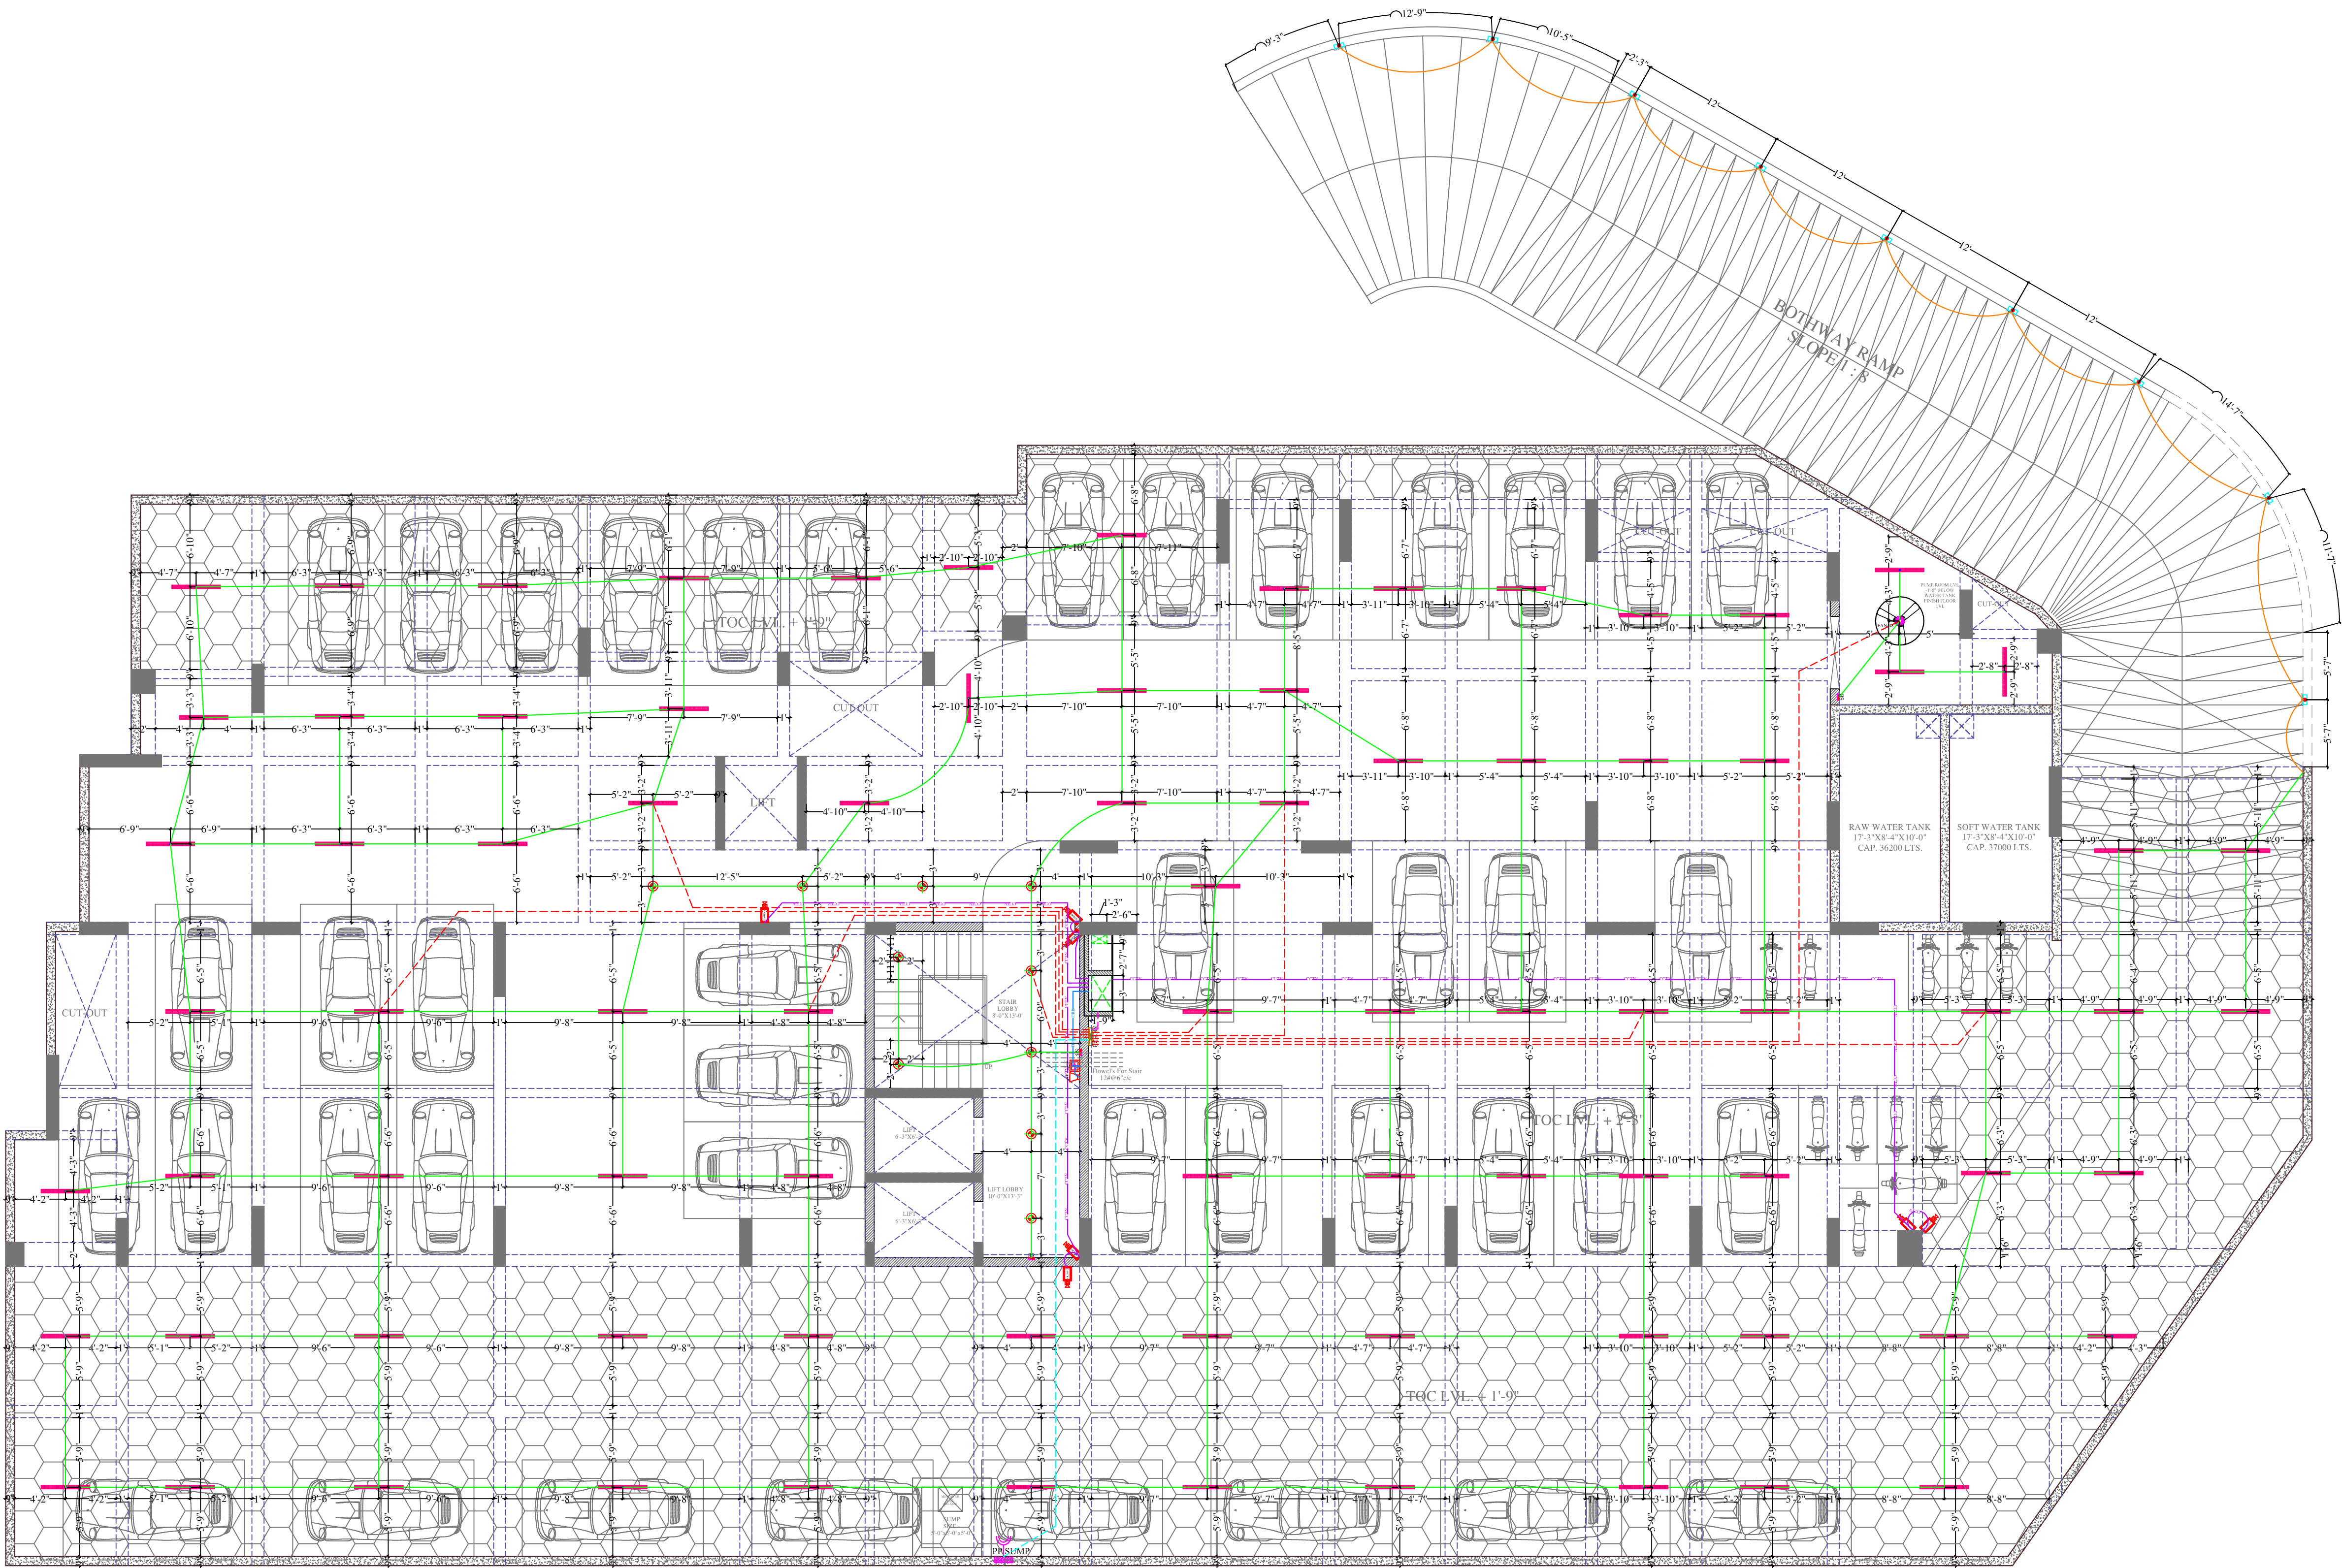


Vipul
VIPUL AGARWAL
M.E.P. CONSULTANT
B.E. ELECTRICAL

LEGENDS:				
Mounting Height	No.	ID	Symbol	Description
IN FLOOR		CONDUIT		Rigid PVC Conduit 25mm/1.5 sqmm wire for Light points
IN RCC SLAB		CONDUIT		Rigid PVC Conduit 25mm/1.5 sqmm wire for Light points
IN RCC SLAB		CONDUIT		Rigid PVC Conduit 25mm/2.5 sqmm wire for Light Circuits
IN RCC SLAB		CONDUIT		Rigid PVC Conduit 25mm/4.0 sqmm wire for POWER Circuits
IN RCC SLAB		CONDUIT		Submain wire to DB from Main Panel on Ground Floor in 1 nos. 32 mm dia conduits
IN RCC SLAB		CONDUIT		Rigid PVC 25mm dia. Conduit /3+1 coaxial wire for Security Camera (C.C.T.V.).
IN RCC SLAB		CONDUIT		Rigid PVC Conduit 25mm/ 2X1.5 sq. mm Copper Wire for Fire Alarm
CEILING	01	FAN48"		SWITCH BOARD
CEILING	83	TL/C		LED CEILING TUBE LIGHT MAKE SYSKA LED CAT NO. SSR-T5-20W
CEILING	10	DL		LED 6" DOWNLIGHTER 20W (SURFACE MOUNTED) MAKE SYSKA LED CAT NO.SDL-15W GLD 6.5K/4K
+66"	09	FL		FOOT LIGHT RABTREE MAKE CAT NO. . ACTPFIWL08
+42"	03	SB		SWITCH BOARD
+18"	01	PP-SUMP		16A POWER POINT FOR SUMP
+60"	01	MCB DB		MCB DISTRIBUTION BOARD
+90"	07	CCTV		WALL MOUNTED CCTV CAMERA
+42"	01	MCP		MANUAL CALL POINT
+90"	01	HT		HOOTER POINT

PROJECT ADD. :- Khasra no/ plot no A-6,7,8,9,10,&11/547, 550,to 555, 557,and 558, Pragti Nagar, Kotra Scheam , Ajmer-305004 (Rajasthan)	PROJECT NAME:- SKY TOWER	DRAWING BASEMENT FLOOR ELECTRIC & LV CONDUIT PLAN	DRAWN:- PAWAN APPD:- SANJAY VIPUL AGARWAL	DEALT:- SERVICES CONSULTANT: VIPUL CONSULTING, F 9 / 440 , Keshav Marg Chitrakut Scheme,Jaipur PH:91-0-93146-10438 ,0141-2440946 Mail:vipul8599@yahoo.com REV. NO. 01,DATE:-02-07-2018	ARCHITECT: studio RKR architecture plot no. G-14, jan path, near dana pani restaurant shyam nagar, jaipur, rajasthan, India cont: 098286 00550 e.mail: rajoriyarajesh@yahoo.co.in	NORTH
--	---------------------------------	--	---	--	---	-----------

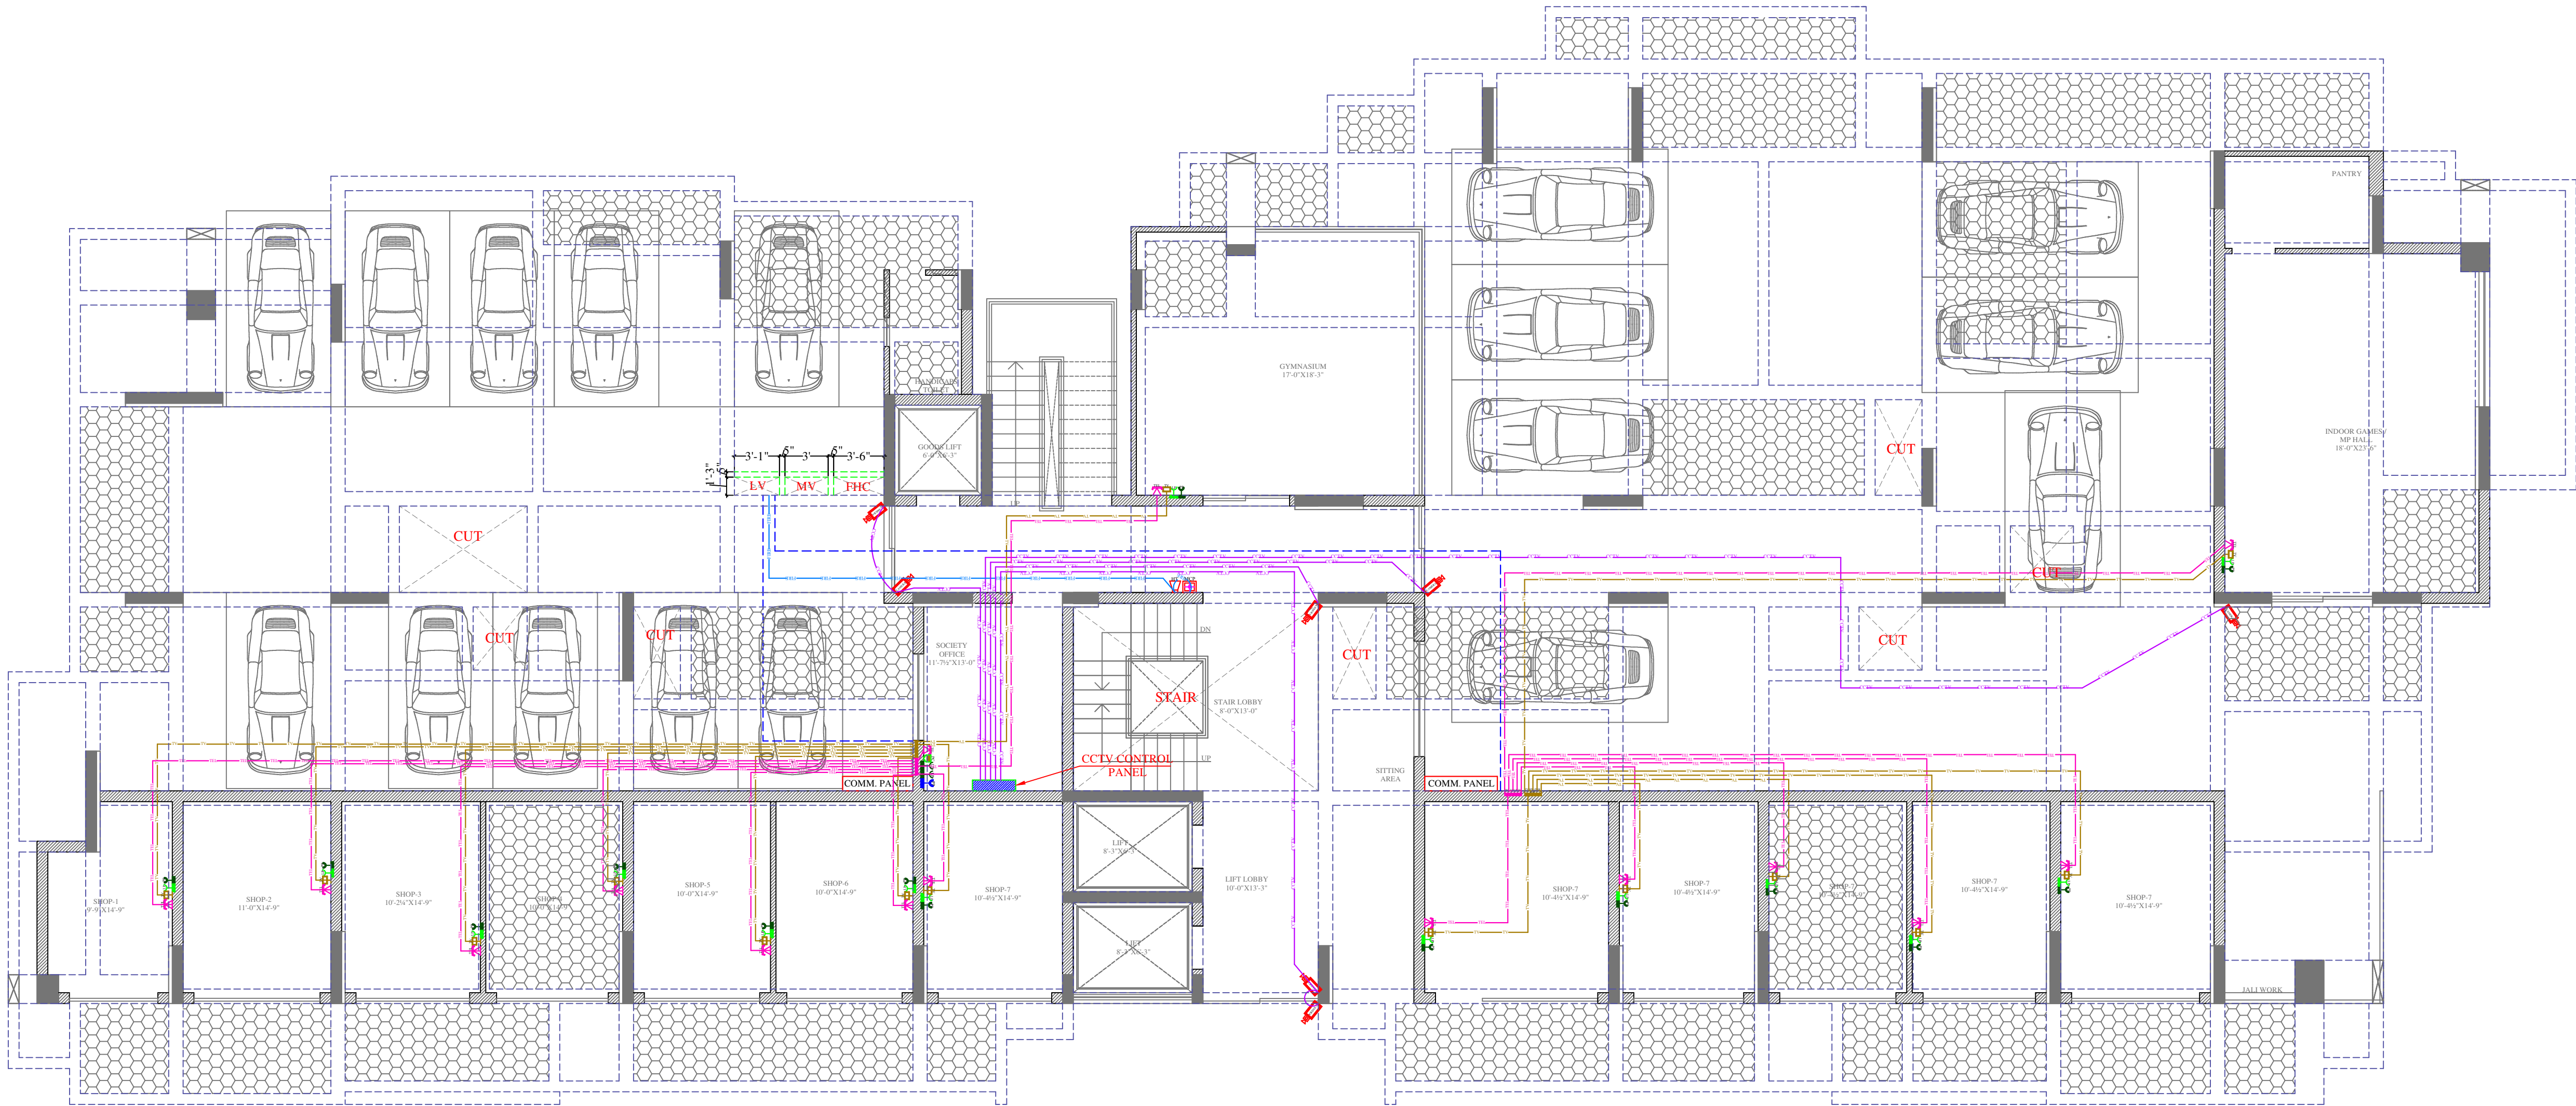


2Nos. 6A Socket Controlled by 1No. 16A Switch, 1Nos. 16A 5Pin Socket Controlled by 1No. 16A Switch, 1No.Telephone jack & 1No.DATA Jack for Computer Point

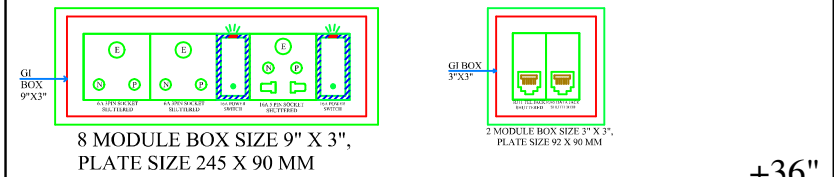

+36"

1Nos. 6A Socket Controlled by 1No. 6A Switch, 1Nos. 16A 5Pin Socket Controlled by 1No. 16A Switch, 1No.Telephone jack & 1No. TV Coaxial Jack

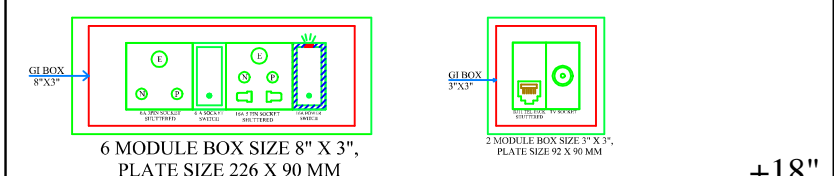

+18"

Vipul
VIPUL AGARWAL
M.E.P. CONSULTANT
B.E. ELECTRICAL

LEGENDS:

Mounting Height	No.	ID	Symbol	Description
IN RCC SLAB		CONDUIT		1Nos. 32 mm dia Conduits From LV System Tag Box to Drop LV Shaft
IN FLOOR		CONDUIT		Rigid PVC 25mm dia. Conduit / 0.5mm 2 Pair Wire For Tel Wiring
IN FLOOR		CONDUIT		Rigid PVC 25mm dia. Conduit / RG6 Cable For TV Wiring
IN RCC SLAB		CONDUIT		Rigid PVC 25mm dia. Conduit / 2X1.5 sq. mm Copper Wire For Fire Alarm
IN RCC SLAB		CONDUIT		Rigid PVC 25mm dia. Conduit / 3+1 Coaxial Wire For Security Camera (C.C.T.V.)
as per elevation	14	SET-1		1Nos. 6A Socket Controlled by 6A Switch, 1Nos. 16A 5Pin Socket Controlled by 16A Switch, 1No.Telephone jack & 1No.TV Coaxial Point
as per elevation	01	SET-2		2Nos. 6A Socket Controlled by 1No. 16A Switch, 1Nos. 16A 5Pin Socket Controlled by 1No. 16A Switch, 1No.Telephone jack & 1No.DATA Jack for Computer Point
+42"	01	MCP		MANUAL CALL POINT
+90"	01	HO		HOOTER POINT
+90"	07	CCTV		WALL MOUNTED CCTV CAMERA
+24"	02			TV SPLITTER BOX
+24"	02			TELEPHONE TAG BOX

PROJECT ADD. :-

Khasra no/ plot no A-6,7,8,9,10,&11/547, 550,to 555, 557,and 558, Pragti Nagar, Kotra Scheam , Ajmer-305004 (Rajasthan)

PROJECT NAME:-

SKY TOWER

DRAWING

STILT FLOOR
LV SYSTEM
CONDUIT PLAN

DRAWN:-
PAWAN
APPD:-
SANJAY

VIPUL AGARWAL


SERVICES CONSULTANT:
VIPUL CONSULTING,
F 9 / 440 , Keshav Marg Chitrakut Scheme,Jaipur
PH:91-0-93146-10438 ,0141-2440946
Mail:vipul8599@yahoo.com
REV. NO. 01, DATE:- 10-09-2018

ARCHITECT:

studio RKR architecture
plot no. G-14, jan path, near dana pani restaurant shyam nagar, jaipur, rajasthan, India
cont: 098286 00550
e.mail: rajoriyarajesh@yahoo.co.in

NORTH

SCALE
1" : 10'-0"

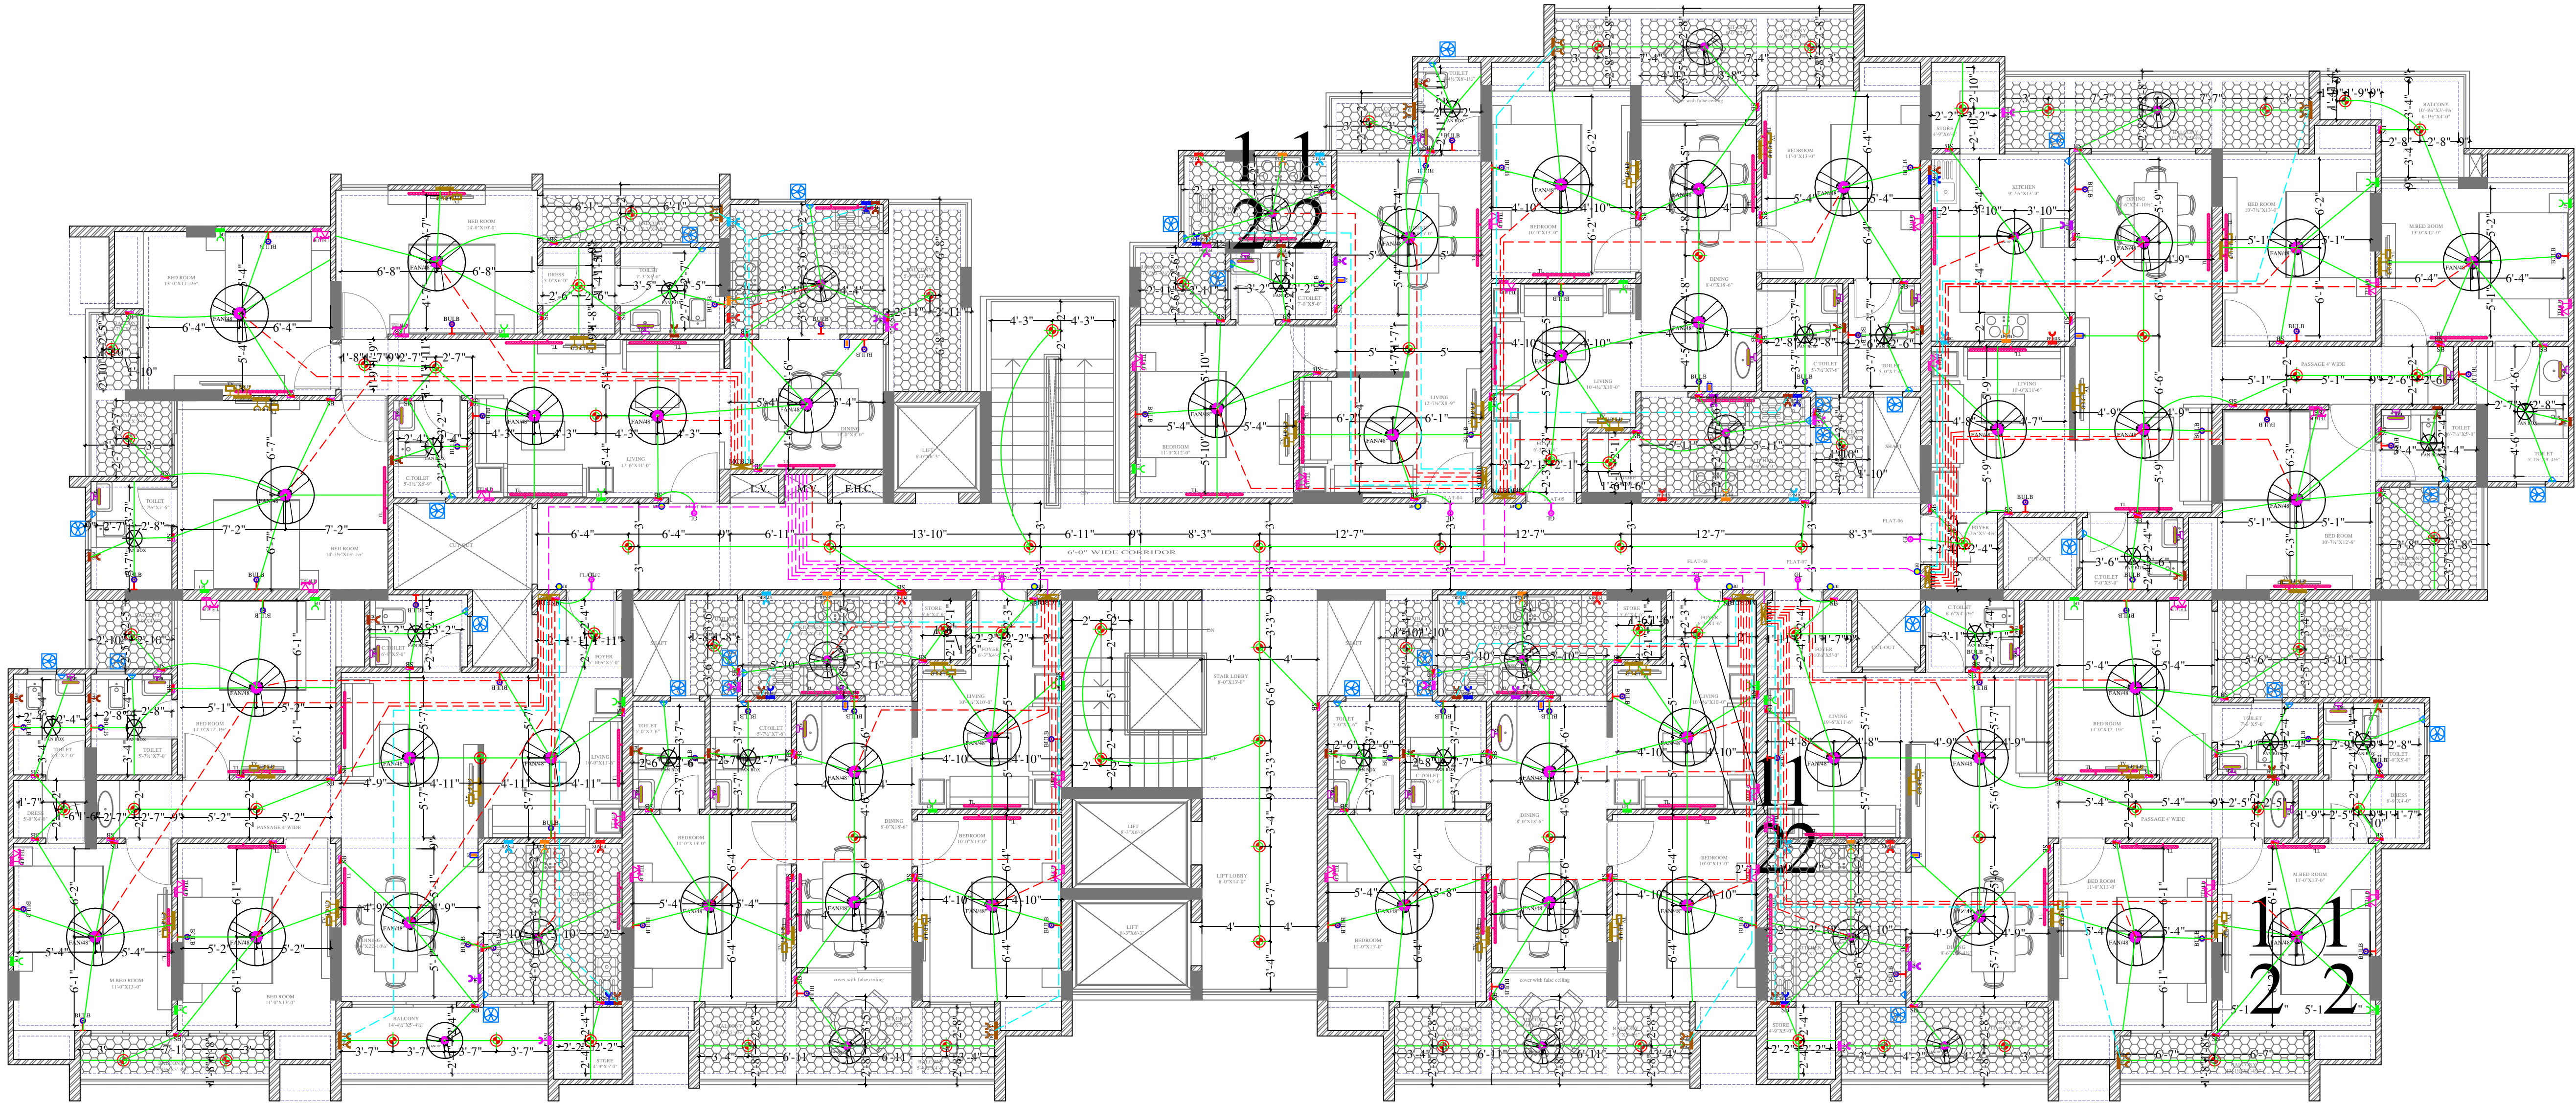

Vipul
VIPUL AGARWAL
M.E.P. CONSULTANT
B.E. ELECTRICAL

LEGENDS:				
Mounting Height	No.	1 D	Symbol	Description
IN RCC SLAB		CONDUIT		Rigid PVC Conduit 25mm/1.0 sqmm wire for Light points
IN RCC SLAB		CONDUIT		Rigid PVC Conduit 25mm/2.5 sqmm wire for Light Circuits
IN RCC SLAB		CONDUIT		Rigid PVC Conduit 25mm/4.0 sqmm wire for POWER Circuits
IN RCC SLAB		CONDUIT		Submain wire to DB from Main Panel on Ground Floor in 1 nos. 32 mm dia conduit
CEILING	42	FAN/48"		CEILING FAN 48"
CEILING	14	FAN/30"		CEILING FAN 30"
CEILING	20	FB		FAN BOX
CEILING	00	CHI		CHANDELLIER
+90"	47	TL		XAWW WALL TUBELIGHT
+90"	64	BULB		WALL BRACKETS AS DESIGN LIGHT
+90"	08	GL		WALL BRACKETS AS DESIGN FOR GANESH LIGHT
CEILING	71	DI		DEEP JUNCTION 4WAY
+42"	114	SB		SWITCH BOARD
+78"	25	ML		1 X 11 W CFL MIRROR LIGHT
VENTILATOR HT.	28			CEILING ROSE
VENTILATOR HT.	28	EXF		9" DIA FRESH AIR FAN
+24"	27	TEL		TELEPHONE POINT
+48"	27	TV		TV COAXIAL POINT
+24"	27	LP		6 A PLUG POINT
+48"	54	LP TV		6 A PLUG POINT FOR TV
+24"	20	LP		6 A PLUG POINT FOR BED SIDE
+72"	08	LP-CH		6 A PLUG POINT FOR CHIMNEY
+90"	00	SP		SPLIT AC INDOOR UNIT
+42"	08	PP-MIX		15 A POWER POINT FOR MIXER
+42"	08	PP-MIC		15 A POWER POINT FOR MICROWAVE
+78"	28	PP-G		15 A POWER POINT FOR GREYSER
+54"	08	PP-F		15 A POWER POINT FOR FRIDGE
+60"	08	PP-WP		15 A POWER POINT FOR WATER PURIFIER
+48"	08	PP-WM		15 A POWER POINT FOR WASHING MACHINE
+12"	16	PP-INV.		15 A POWER POINT FOR INVERTER
+60"	08	BP		6 A BELL PUSH
+90"	08	BZ		BUZZER FOR CALL BELL
+60"	08	MCB DB		MCB DISTRIBUTION BOARD

SERVICES CONSULTANT:
VIPUL CONSULTING.
F 9 / 440 , Keshav Marg Chitrakut Scheme,Jaipur
PH:91-0-93146-10438 ,0141-2440946 Mail:vipul8599@yahoo.co.in
REV. NO. 01,DATE: 25-10-2018

PROJECT ADD. :-

Khasra no/ plot no A-6,7,8,9,10,&11/547, 550,to
555, 557and 558, Pragti Nagar, Kotra Scheam ,
Ajmer-305004 (Rajasthan)

PROJECT NAME:-

SKY TOWER

NAME OF
DRAWING:

TYPICAL FLOOR ELECTRIC CONDUIT PLAN

SCALE	PROJ. NO.- PA-06_17	DRAWING NO.	NORTH
1" : 10'-0"	DEALT BY.- VIJESH	CEN.-02	
DATE	CHKD BY.- SANJAY		
25 / 10 / 2018	APPD BY.- VIPUL AGARWAL		

GENERAL NOTES

1. ALL DIMENSION ON THIS DRAWING ARE IN FEET AND INCHES
2. ONLY WRITTEN DIMENSIONS ARE TO BE FOLLOWED. DRAWING SHOULD NOT BE SCALED UNDER ANY CIRCUMSTANCES.
3. ALL MEASUREMENTS MUST BE CHECKED AND VERIFIED BY THE CONTRACTORS PRIOR TO EXECUTION OF WORK AT THE SITE.
4. THIS DRAWING IS TO BE READ IN CONJUNCTION WITH ALL RELEVANT STRUCTURAL, SERVICES & FACILITY PLANNING DRAWINGS.
5. ARCHITECTURAL DRAWINGS ARE TO BE FOLLOWED FOR THE LOCATION OF ALL STRUCTURAL MEMBERS & MASONRY WALLS. FOR SIZES & REINFORCEMENT DETAILS OF STRUCTURAL MEMBERS, RELEVANT STRUCTURAL DRAWINGS ARE TO BE REFERED.
6. ANY DISCREPANCIES BETWEEN ARCHITECTURAL, STRUCTURAL AND SERVICES DRAWINGS MUST BE BROUGHT TO THE NOTICE OF THE ARCHITECTS IMMEDIATELY & PRIOR TO EXECUTION AT SITE.
7. CO-ORDINATION WITH SERVICES SUCH AS HVAC, PLUMBING & ELECTRICAL, ETC. IS THE RESPONSIBILITY OF THE CONTRACTORS.
8. ALL MASONRY WALLS SHOULD BE ALIGNED WITH THE COLUMNS AS INDICATED ON THE PLAN, IRRESPECTIVE OF THE POSITION AS CALCULATED WITH THE DIMENSIONING.
9. FURNITURE/FIXTURES SHOWN ARE INDICATIVE ONLY PLEASE REFER RESPECTIVE SCHEDULES
10. THIS DRAWING IS THE PROPERTY OF **IMAGINE ARCHITECTURE**.AND NOT TO BE COPIED OR USED WITHOUT THEIR PERMISSION


REVISION L E G E N D

S.NO.	DATE	DESCRIPTION
01		
02		

ARCHITECT:

STUDIO rkr architecture

plot no. G-14,Siddharth Apartment,
opp. Dana Pani Restaurant, Jan Path
Shyam Nagar, jaipur , rajasthan, India
cont: 0141-2297446
R. - 098286 00550 H. - 9636020090
e.mail: info@imaginearchitecture.co.in;
rajoriyarajesh@yahoo.co.in

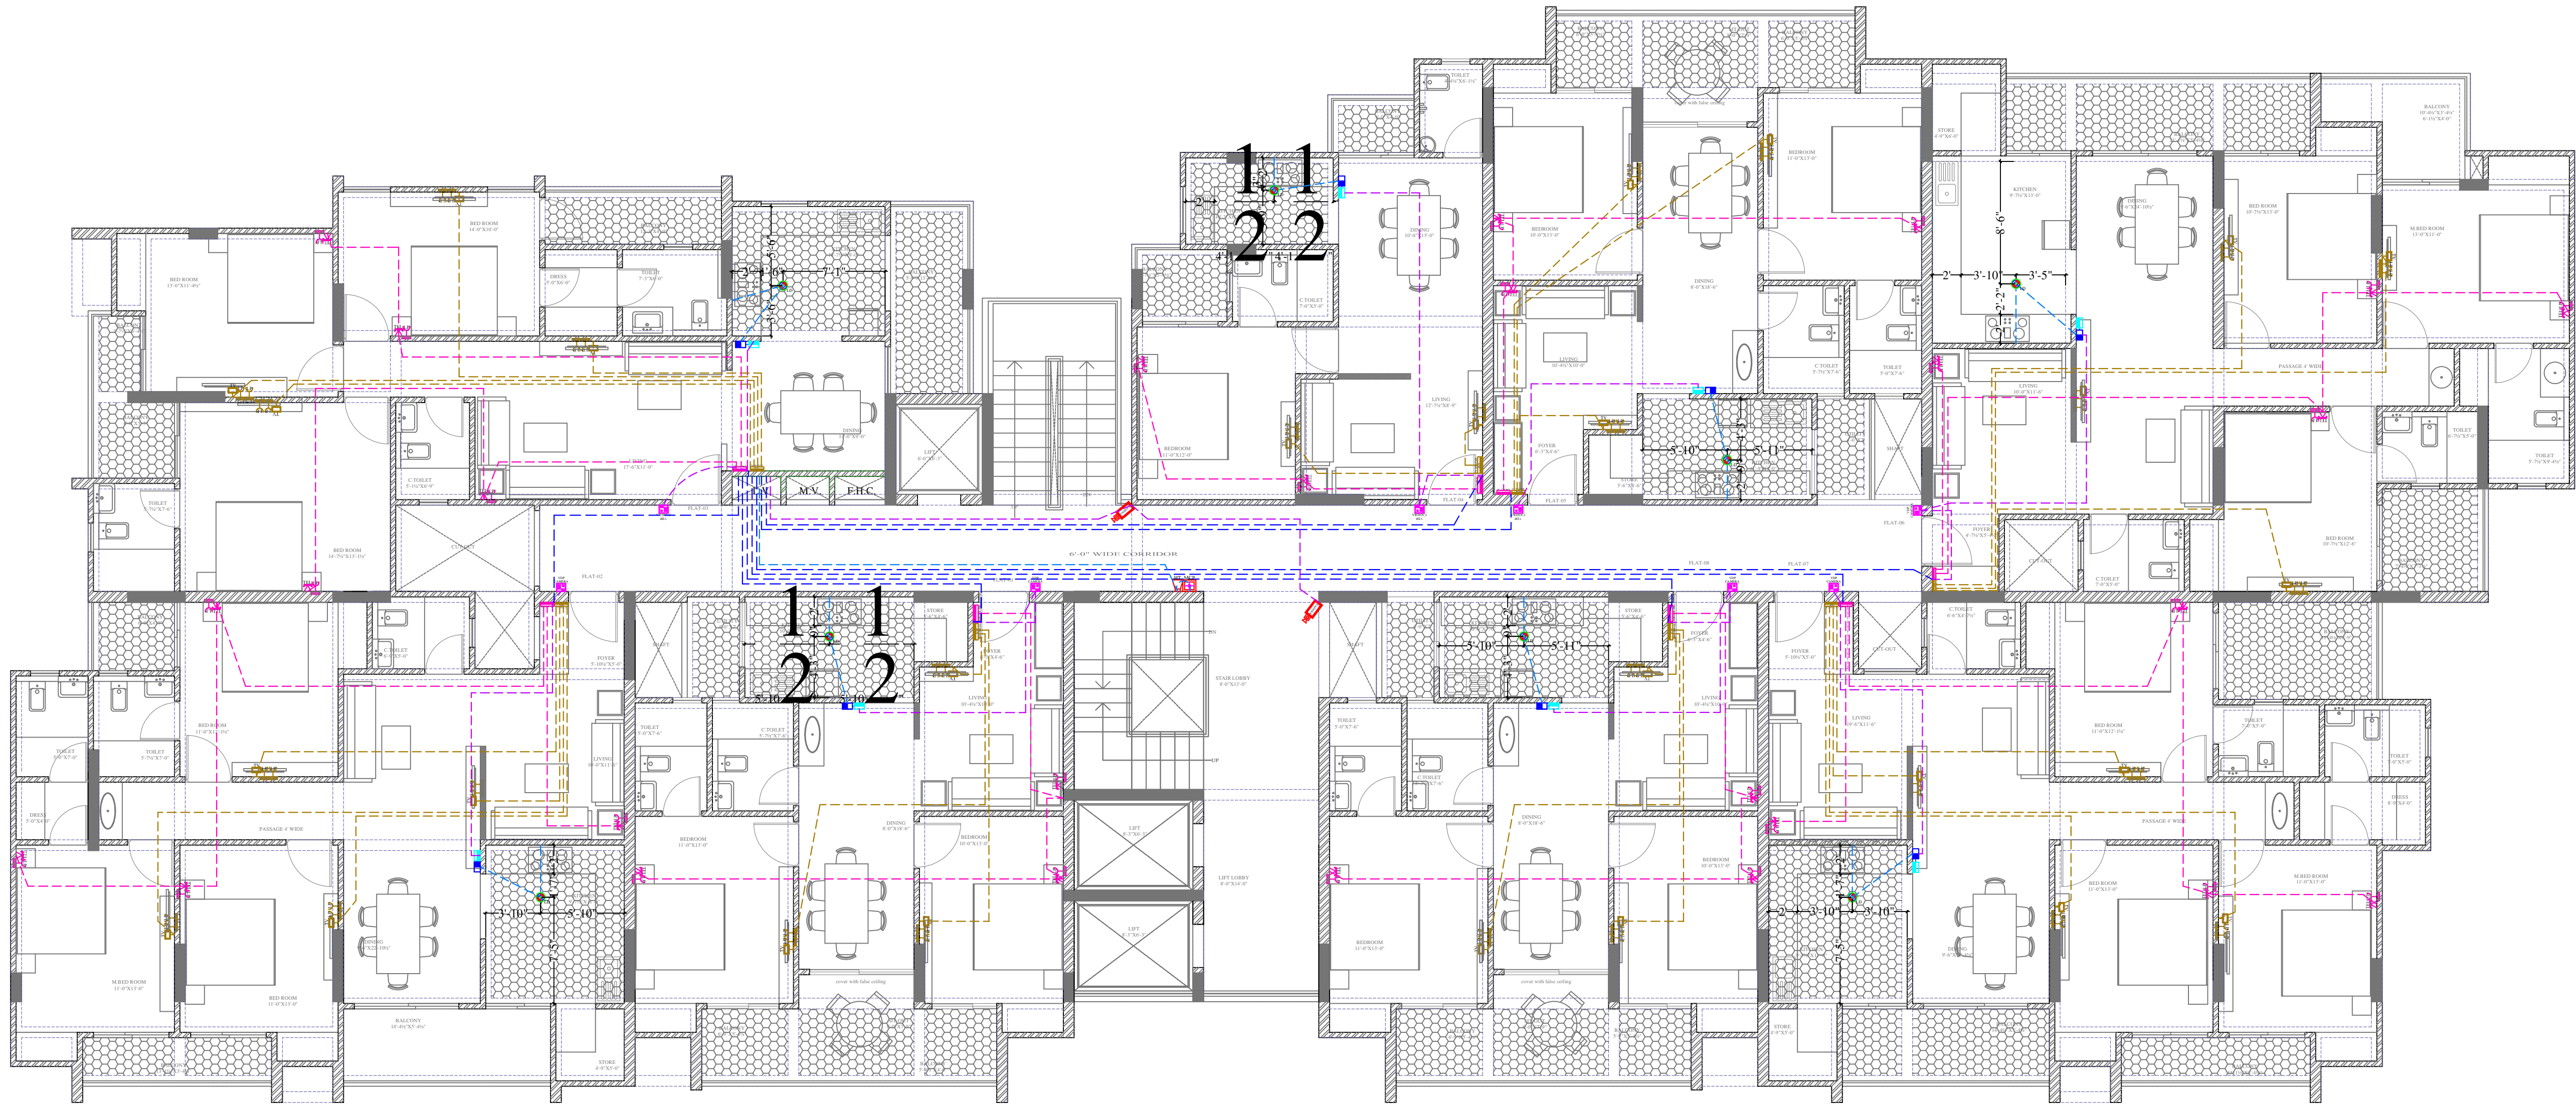

Vipul
VIPUL AGARWAL
M.E.P. CONSULTANT
B.E. ELECTRICAL

LEGENDS:				
Mounting Height	No.	ID	Symbol	Description
IN FLOOR		CONDUIT		Rigid PVC 25mm dia. Conduit / 0.5mm 2 Pair Wire For Tel Wiring
IN FLOOR		CONDUIT		Rigid PVC 25mm dia. Conduit / RG6 Cable For TV Wiring
IN RCC SLAB		CONDUIT		1Nos. 32 mm dia Conduits From Flat LV System to Drop LV Shaft
IN RCC SLAB		CONDUIT		Rigid PVC 25mm dia. Conduit For Video Door Phone & Camera
IN RCC SLAB		CONDUIT		Rigid PVC 25mm dia. Conduit / 2X1.5 sq. mm Copper Wire For Fire Alarm
+60"	08	VDP CAMERA		VIDEO DOOR PHONE OUTDOOR UNIT WITH BUILT IN CAMERA
+48"	08	VDP		VIDEO DOOR PHONE INDOOR UNIT
+48"	08	PS		PANIC SWITCH
CELLING	08	LD		LPG DETECTOR
+24"	27	TEL		TELEPHONE POINT
+48"	27	TV		TV COAXIAL POINT
+24"	27	LP TEL		6 A PLUG POINT FOR TELEPHONE
+48"	54	LP TV		6 A PLUG POINT FOR TV
+24"	08			TV SPLITTER BOX
+24"	08			TELEPHONE TAG BOX
+42"	01	MCP		MANUAL CALL POINT
+90"	01	HO		HOOTER POINT
+90"	02	CCTV		WALL MOUNTED CCTV CAMERA
SERVICES CONSULTANT: VIPUL CONSULTING, F 9 / 440 , Keshav Marg Chitrakut Scheme Jaipur PH:91-0-93146-10438 ,0141-2440946 Mail:vipul8599@yahoo.com REV. NO. 01,DATE:25-10-2018				

PROJECT ADD. :-
Khasra no/ plot no A-6,7,8,9,10,&11/547, 550,to
555, 557,and 558, Pragti Nagar, Kotra Scheam ,
Ajmer-305004 (Rajasthan)

PROJECT NAME:-
SKY TOWER


NAME OF DRAWING: TYPICAL FLOOR LV CONDUIT PLAN			
SCALE 1" : 10'-0"	PROJ. NO.- PA-06_17	DRAWING NO.	NORTH
DATE 25 / 10 / 2018	DEALT BY.- VJESH	CEN.-02	
	CHKD BY.- SANJAY		
	APPD BY.- VIPUL AGARWAL		

- GENERAL NOTES
1. ALL DIMENSION ON THIS DRAWING ARE IN FEET AND INCHES.
 2. ONLY WRITTEN DIMENSIONS ARE TO BE FOLLOWED. DRAWING SHOULD NOT BE SCALED UNDER ANY CIRCUMSTANCES.
 3. ALL MEASUREMENTS MUST BE CHECKED AND VERIFIED BY THE CONTRACTORS PRIOR TO EXECUTION OF WORK AT THE SITE.
 4. THIS DRAWING IS TO BE READ IN CONJUNCTION WITH ALL RELEVANT STRUCTURAL, SERVICES & FACILITY PLANNING DRAWINGS.
 5. ARCHITECTURAL DRAWINGS ARE TO BE FOLLOWED FOR THE LOCATION OF ALL STRUCTURAL MEMBERS & MASONRY WALLS.
 6. FOR SIZES & REINFORCEMENT DETAILS OF STRUCTURAL MEMBERS, RELEVANT STRUCTURAL DRAWINGS ARE TO BE REFERRED.
 7. ANY DISCREPANCIES BETWEEN ARCHITECTURAL, STRUCTURAL AND SERVICES DRAWINGS MUST BE BROUGHT TO THE NOTICE OF THE ARCHITECTS IMMEDIATELY & PRIOR TO EXECUTION AT SITE.
 8. CO-ORDINATION WITH SERVICES SUCH AS HVAC, PLUMBING & ELECTRICAL, ETC. IS THE RESPONSIBILITY OF THE CONTRACTORS.
 9. ALL MASONRY WALLS SHOULD BE ALIGNED WITH THE COLUMNS AS INDICATED ON THE PLAN, IRRESPECTIVE OF THE POSITION AS CALCULATED WITH THE DIMENSIONING.
 10. FURNITURE/FIXTURES SHOWN ARE INDICATIVE ONLY PLEASE REFER RESPECTIVE SCHEDULES
 11. THIS DRAWING IS THE PROPERTY OF **IMAGINE ARCHITECTURE**.AND NOT TO BE COPIED OR USED WITHOUT THEIR PERMISSION

REVISION LEGEND		
S.NO.	DATE	DESCRIPTION
01		
02		

ARCHITECT:
STUDIO rkr architecture
plot no. G-14,Siddharth Apartment,
opp. Dana Pani Restaurant, Jan Path
Shyam Nagar, jaipur , rajasthan, India
cont: 0141-2297446
R. - 098286 00550 H. - 9636020090
e.mail: info@imaginearchitecture.co.in;
rajoriyarajesh@yahoo.co.in

LEGENDS:				
Mounting Height	No.	I D	Symbol	Description
IN FLOOR		CONDUIT		Rigid PVC 25mm dia. Conduit /1.5 sqmm Wire For Light Points
IN RCC SLAB		CONDUIT		Rigid PVC 25mm dia. Conduit /1.5 sqmm Wire For Light Points
IN FLOOR		CONDUIT		Rigid PVC 25mm dia. Conduit /2.5 sqmm Wire For Light Circuits
CEILING	25	DL		Led 6" Down Lighter 20W (Surface Mounted) Make:- Syska Led Cat no.:- SDL-15W GLD 6.5K/4K
+42"	04	SB		SWITCH BOARD
+90"	02	BULB		Led Bulb 20W Make:- Syska Led Cat no. SKC-20W 5.7K/3K
+18"	29	FL		FOOT LIGHT
+90"	01	TL/W		LED WALL TUBE LIGHT MAKE SYSKA LED CAT NO. SSK-T5-20W

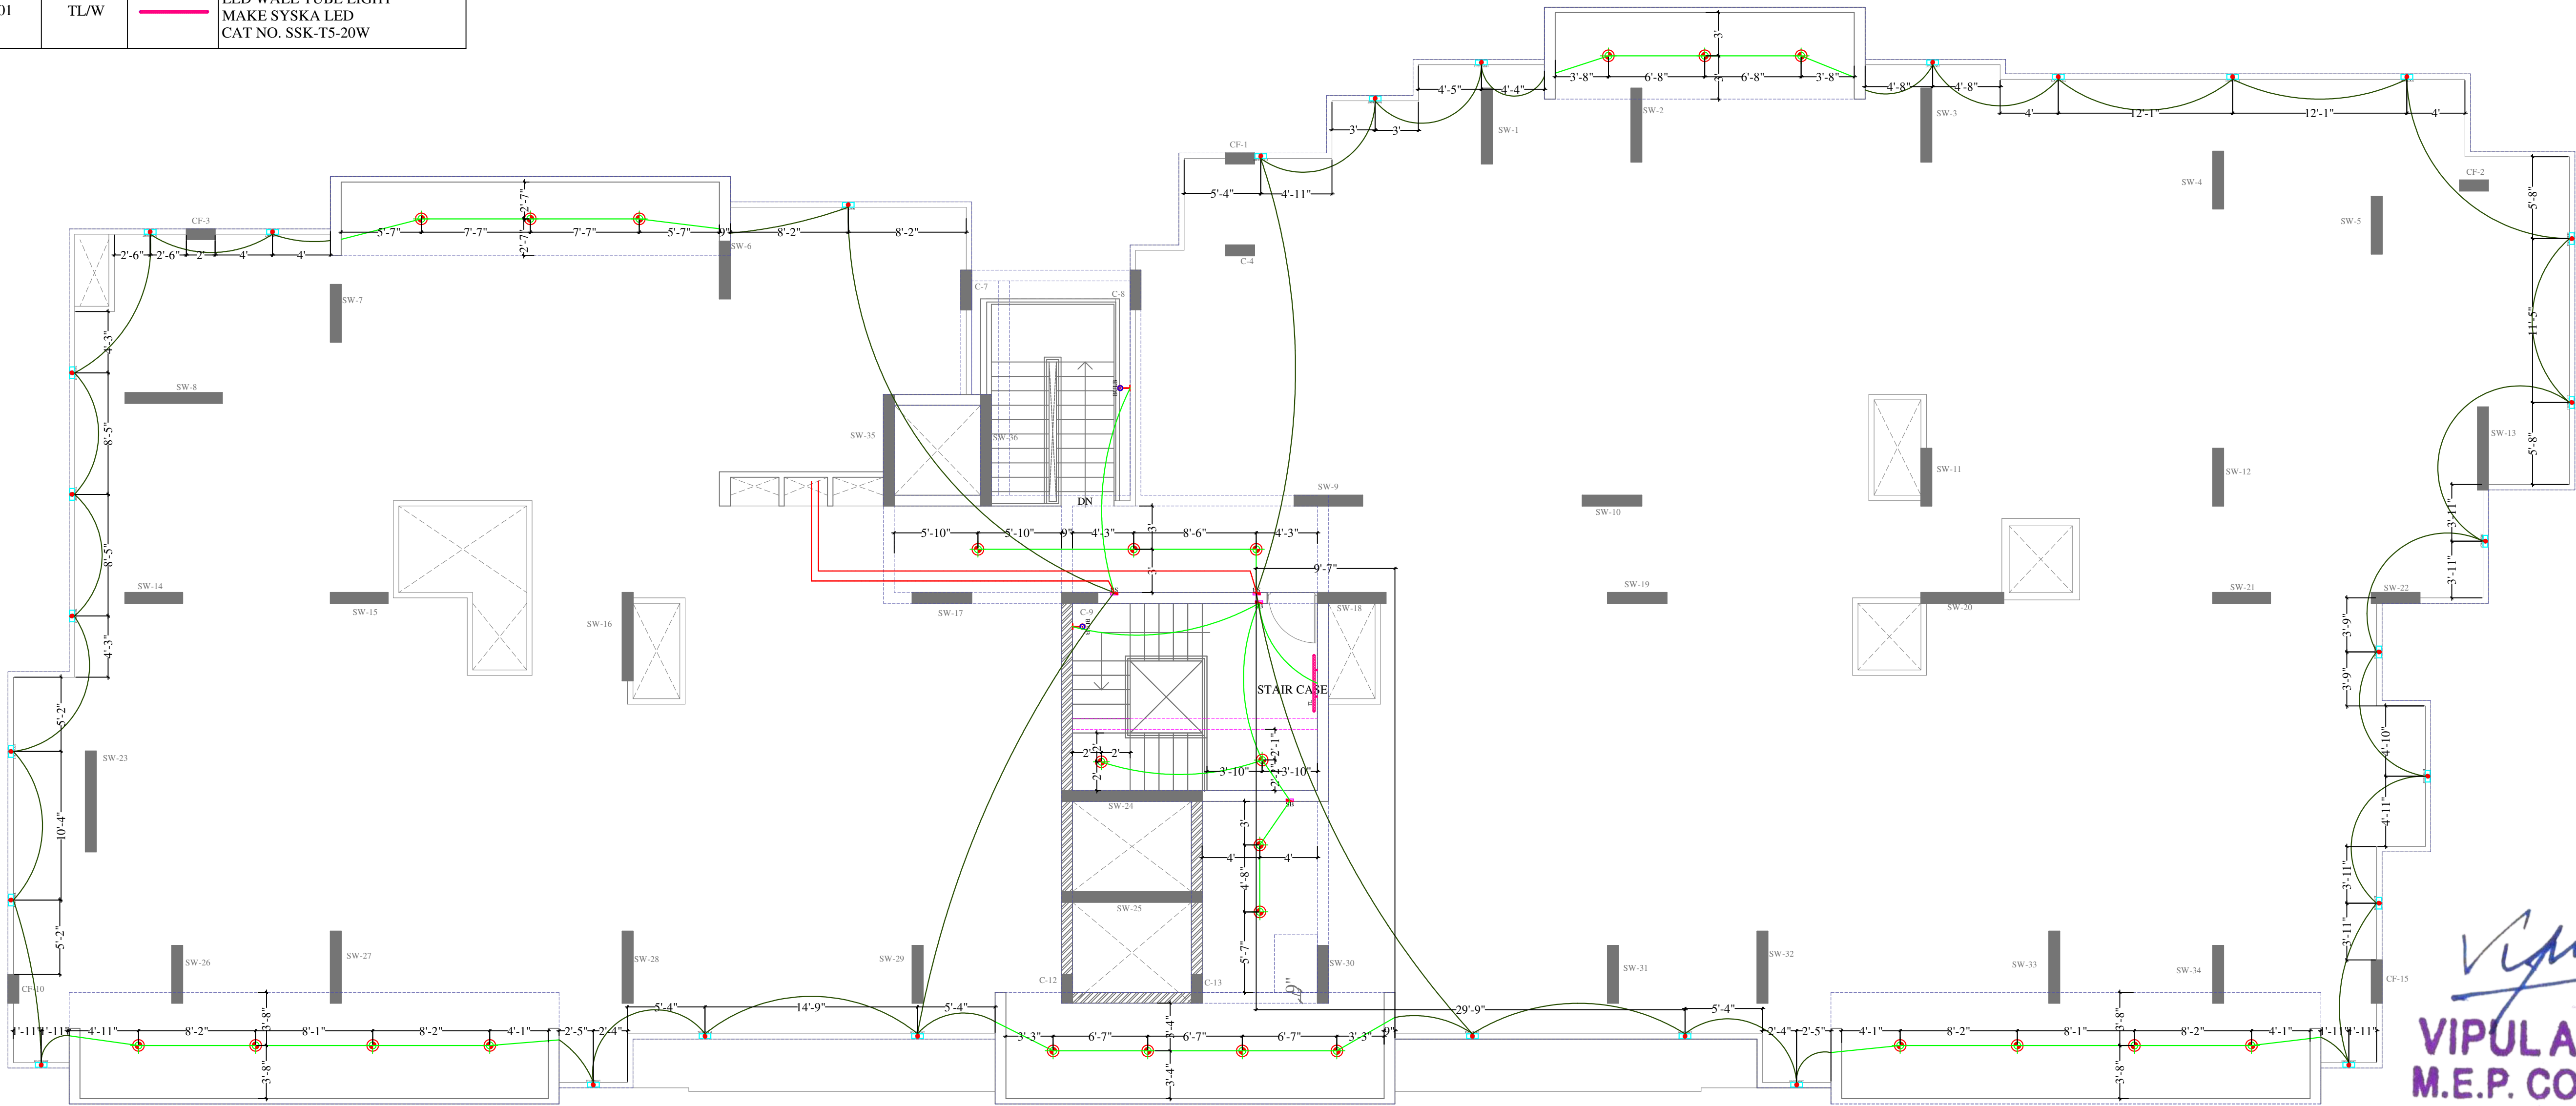


Vipul
VIPUL AGARWAL
M.E.P. CONSULTANT
B.E. ELECTRICAL

PROJECT ADD. :-
Khasra no/ plot no A-6,7,8,9,10,&11/547, 550,to
555, 557,and 558, Pragti Nagar, Kotra Scheam ,
Ajmer-305004 (Rajasthan)

PROJECT NAME:-

SKY TOWER

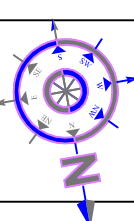NAME OF DRAWING:			
TERRACE FLOOR ELECTRIC CONDUIT PLAN			
SCALE 1" : 10'-0"	PROJ. NO.- PA-06_17	DRAWING NO.	
	DEALT BY.- VINOD	001	
DATE	CHKD BY.- SANJAY		
06/ 07 / 2021	APPD BY.- VIPPUL AGARWAL		

- GENERAL NOTES
1. ALL DIMENSION ON THIS DRAWING ARE IN FEET AND INCHES
 2. ONLY WRITTEN DIMENSIONS ARE TO BE FOLLOWED .DRAWING SHOULD NOT BE SCALED UNDER ANY CIRCUMSTANCES.
 3. ALL MEASUREMENTS MUST BE CHECKED AND VERIFIED BY THE CONTRACTORS PRIOR TO EXECUTION OF WORK AT THE SITE.
 4. THIS DRAWING IS TO BE READ IN CONJUNCTION WITH ALL RELEVANT STRUCTURAL, SERVICES & FACILITY PLANNING DRAWINGS.
 - 5.Architectural Drawings are to be followed for the location of all structural members & masonry walls.
 6. FOR SIZES & REINFORCEMENT DETAILS OF STRUCTURAL MEMBERS, RELEVANT STRUCTURAL DRAWINGS ARE TO BE REFERED.
 7. ANY DISCREPANCIES BETWEEN ARCHITECTURAL, STRUCTURAL AND SERVICES DRAWINGS MUST BE BROUGHT TO THE NOTICE OF THE ARCHITECTS IMMEDIATELY & PRIOR TO EXECUTION AT SITE.
 8. CO-ORDINATIO WITH SERVICES SUCH AS HVAC, PLUMBING & ELECTRICAL, ETC. IS THE RESPONSIBILITY OF THE CONTRACTORS.
 9. ALL MASONRY WALLS SHOULD BE ALIGNED WITH THE COLUMNS AS INDICATED ON THE PLAN, IRRESPECTIVE OF THE POSITION AS CALCULATED WITH THE DIMENSIONING.
 10. THIS DRAWING IS THE PROPERTY OF **IMAGINE ARCHITECTURE**.AND NOT TO BE COPIED OR USED WITHOUT THEIR PERMISSION

SERVICES CONSULTANT:
VIPUL CONSULTING,
F 9 / 440 , Keshav Marg Chitrakut Scheme,Jaipur
PH:91-0-93146-10438 ,0141-2440946 Mail:vipul8599@yahoo.com
REV. NO. 00,DATE:-06-07-2021

ARCHITECT:
STUDIO rkr architecture
plot no. G-14,Siddharth Apartment,
opp. Dana Pani Restaurant, Jan Path
Shyam Nagar, jaipur , rajasthan, India
cont: 0141-2297446
R. - 098286 00550 H. - 9636020090
e.mail: info@imaginearchitecture.co.in;
rajoriyarajesh@yahoo.co.in