



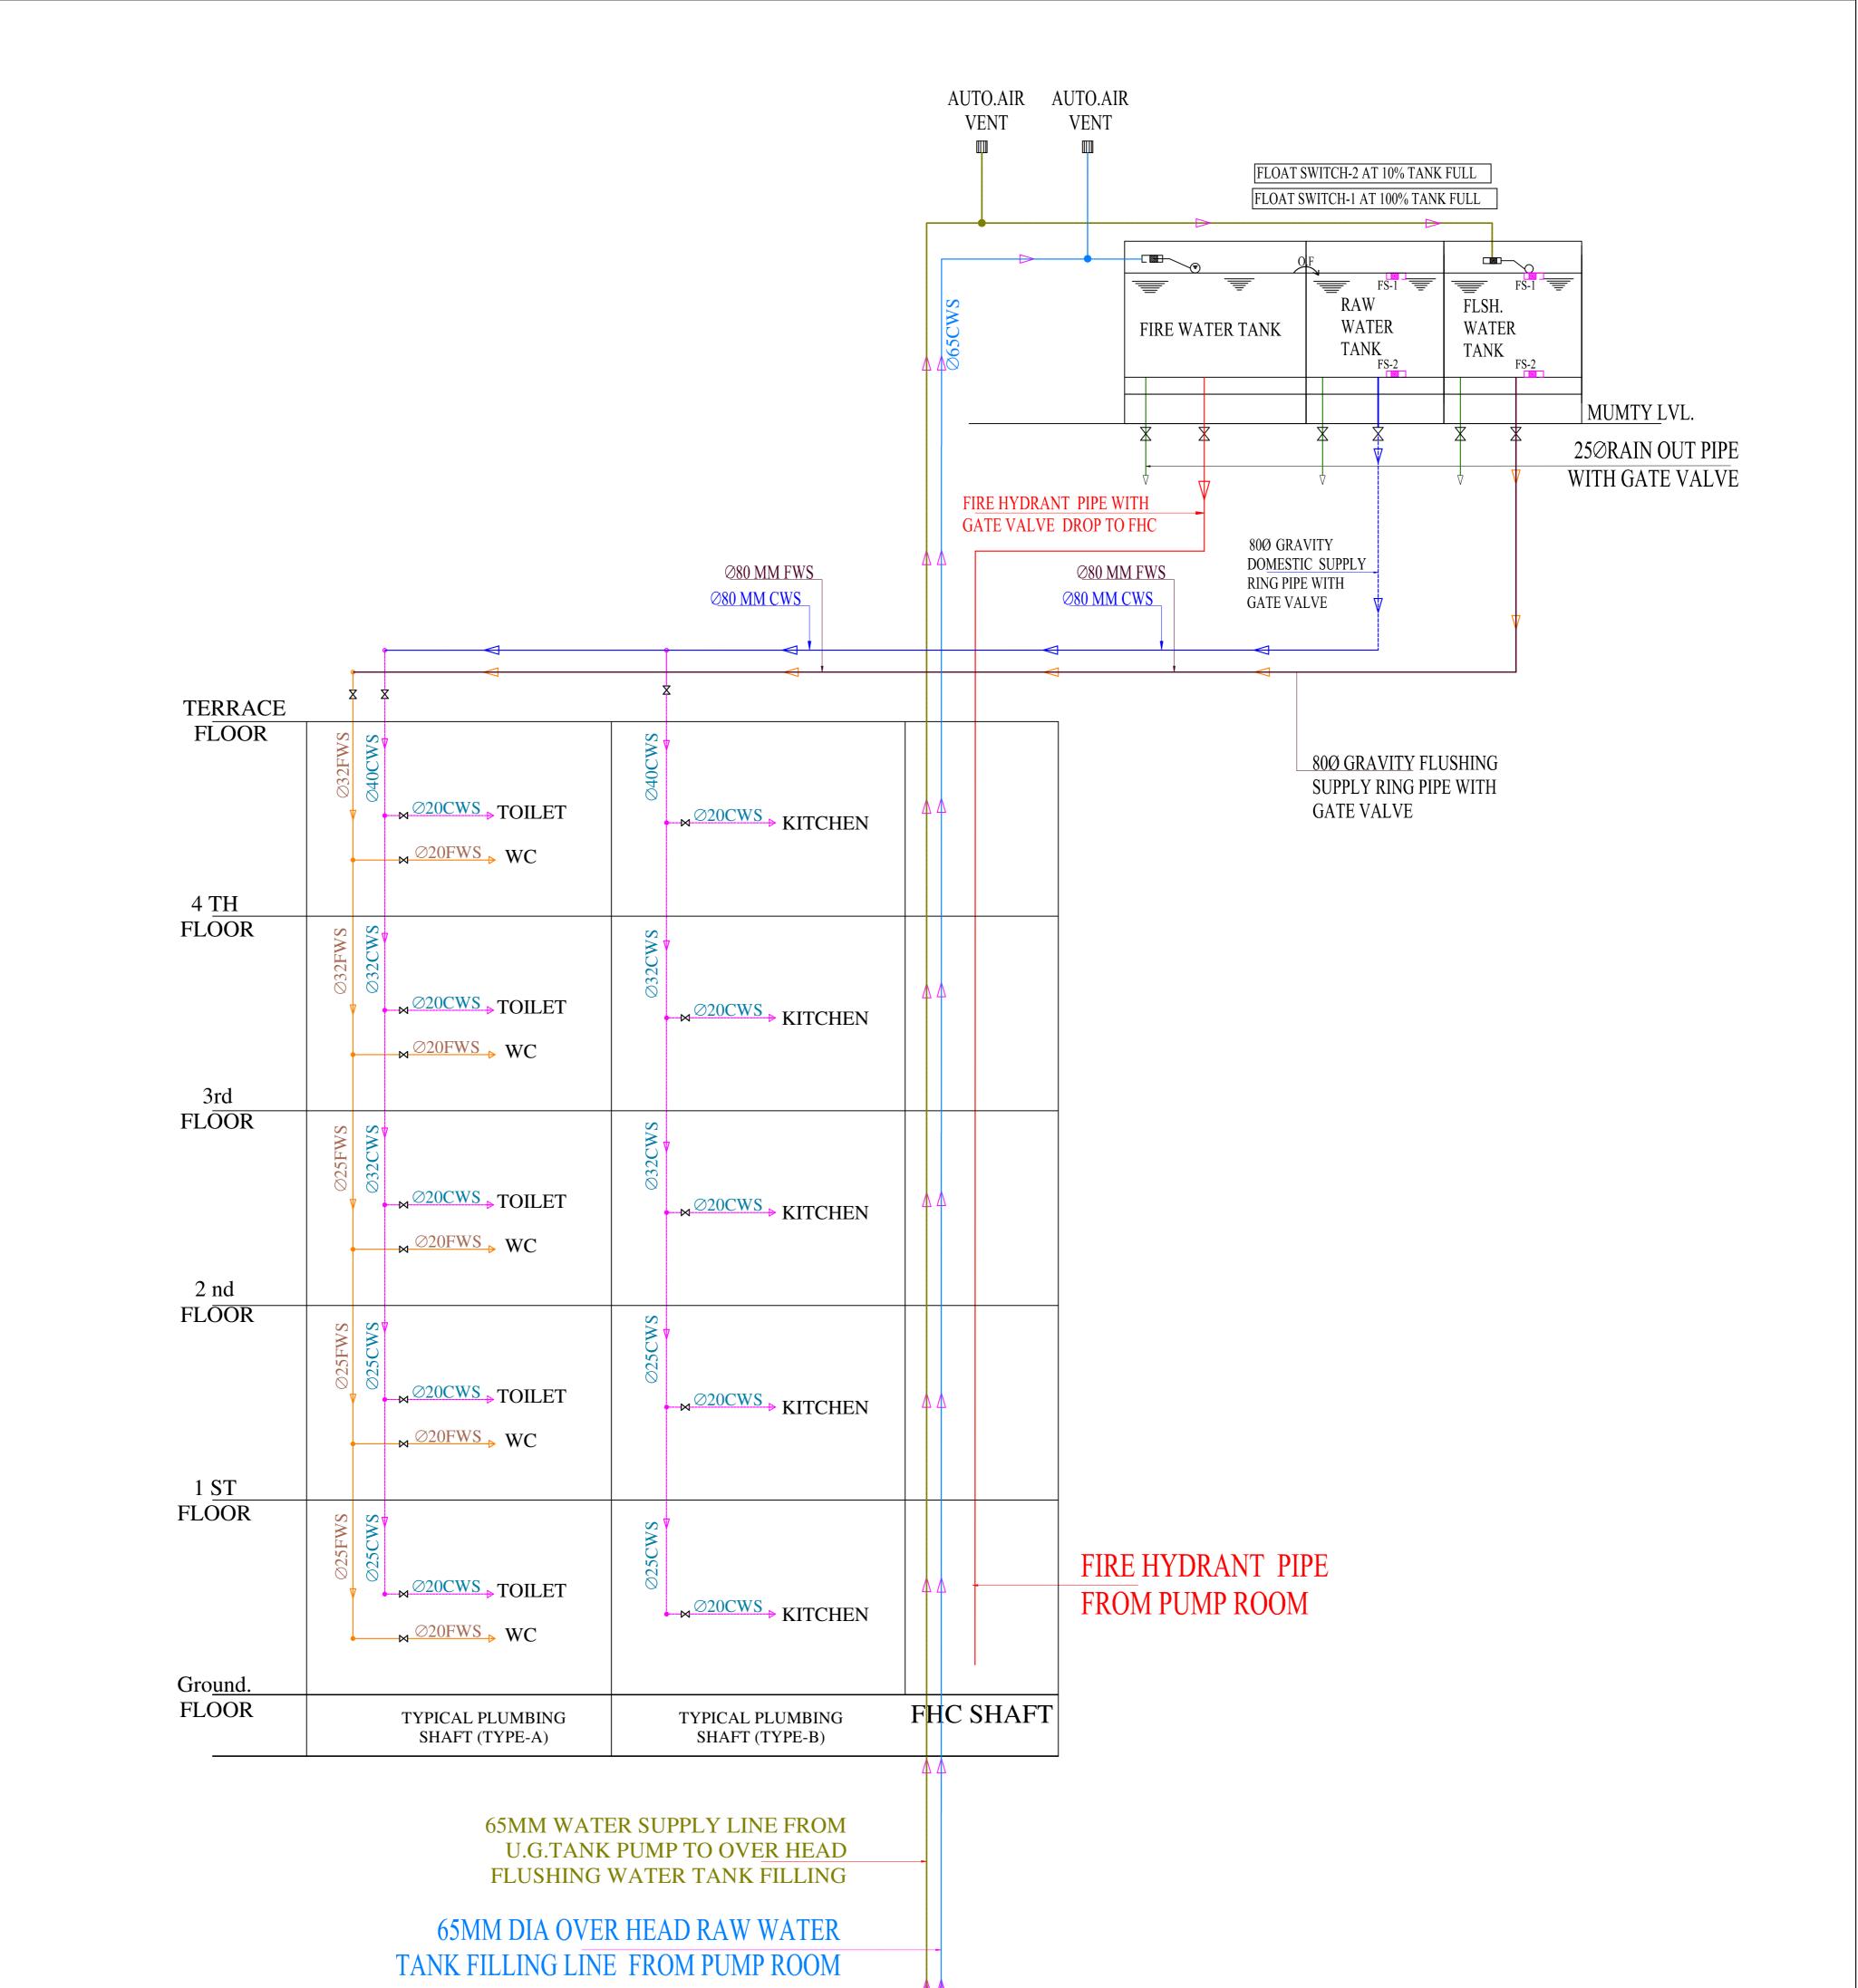


CLIENT :	PROJECT:-	ARCHITECTS :	NAME OF DRAWING:				NORTH:		
des graphite tudio SAMRIDDHI BUILDERS	PROPOSED GSITE PLAN SHOWING RESIDENTIAL PLOT FOR CHEIF MINISTER JAN AWAS YOJANA SITUATED AT KH. NO. 1296,1306 AT VILLAGE MAKARWALI ,AJMER	GRAPHITE DESIGN STUDIO ARCHITECTS, INTERIOR DESIGNERS, PLANNERS 68, Janak Puri -1st, Imliwala phatak, Opp Jain Mandir, Jaipur CONTACT NO. +91-9928334414, 0141-2593414 email: studiosgraphite@gmail.com Website : www.graphitedesignstudio.com	TOWER-A WATER SUPPLY SCHEMATIC DIAGRAM		PROJECT NO. : SCALE :	24-02-2021		SERVICES CONSULTANT: VIPUL CONSULTING, F 9 / 440 , Keshav Marg Chitrakut Scheme,Jaipur	
			DRN BY:	CKD. BY:	APPD. BY:	DRAWING NO. :			PH:91-0-93146-10438 ,0141-2440946 Mail:vipul8599@yahoo.com REV. NO. 01 DATE: 24-02-2021
			RAAJ	SANJAY	VIPUL AGARWA	L			




		4 * 4						
								VIPUL AGARWAL M.E.P. CONSULTANT B.E. ELECTRICAL
CLIENT : des graphite n tudio	PROJECT:- PROPOSED GSITE PLAN SHOWING	ARCHITECTS :	NAME OF DRAWING:	TOWER			NORTH:	
SAMRIDDHI BUILDERS	RESIDENTIAL PLOT FOR CHEIF MINISTER JAN AWAS YOJANA SITUATED AT KH. NO. 1296,1306 AT	GRAPHITE DESIGN STUDIO ARCHITECTS, INTERIOR DESIGNERS, PLANNERS 68, Janak Puri -1st, Imliwala phatak, Opp Jain Mandir, Jaipur CONTACT NO. +91-9928334414, 0141-2593414 email: studiosgraphite@gmail.com	DRN BY:	CKD. BY:	SCHEMATIC AM APPD. BY:	PROJECT NO. : SCALE : DRAWING NO. :	DATE : 24-02-2021 REV NO. : R-01	SERVICES CONSULTANT: VIPUL CONSULTING, F 9 / 440, Keshav Marg Chitrakut Scheme,Jaipur PH:91-0-93146-10438,0141-2440946 Mail:vipul8599@yahoo.com
	VILLAGE MAKARWALI ,AJMER	Website : www.graphitedesignstudio.com	RAAJ	SANJAY	VIPUL AGARWA	L		REV. NO. 01 DATE: 24-02-2021

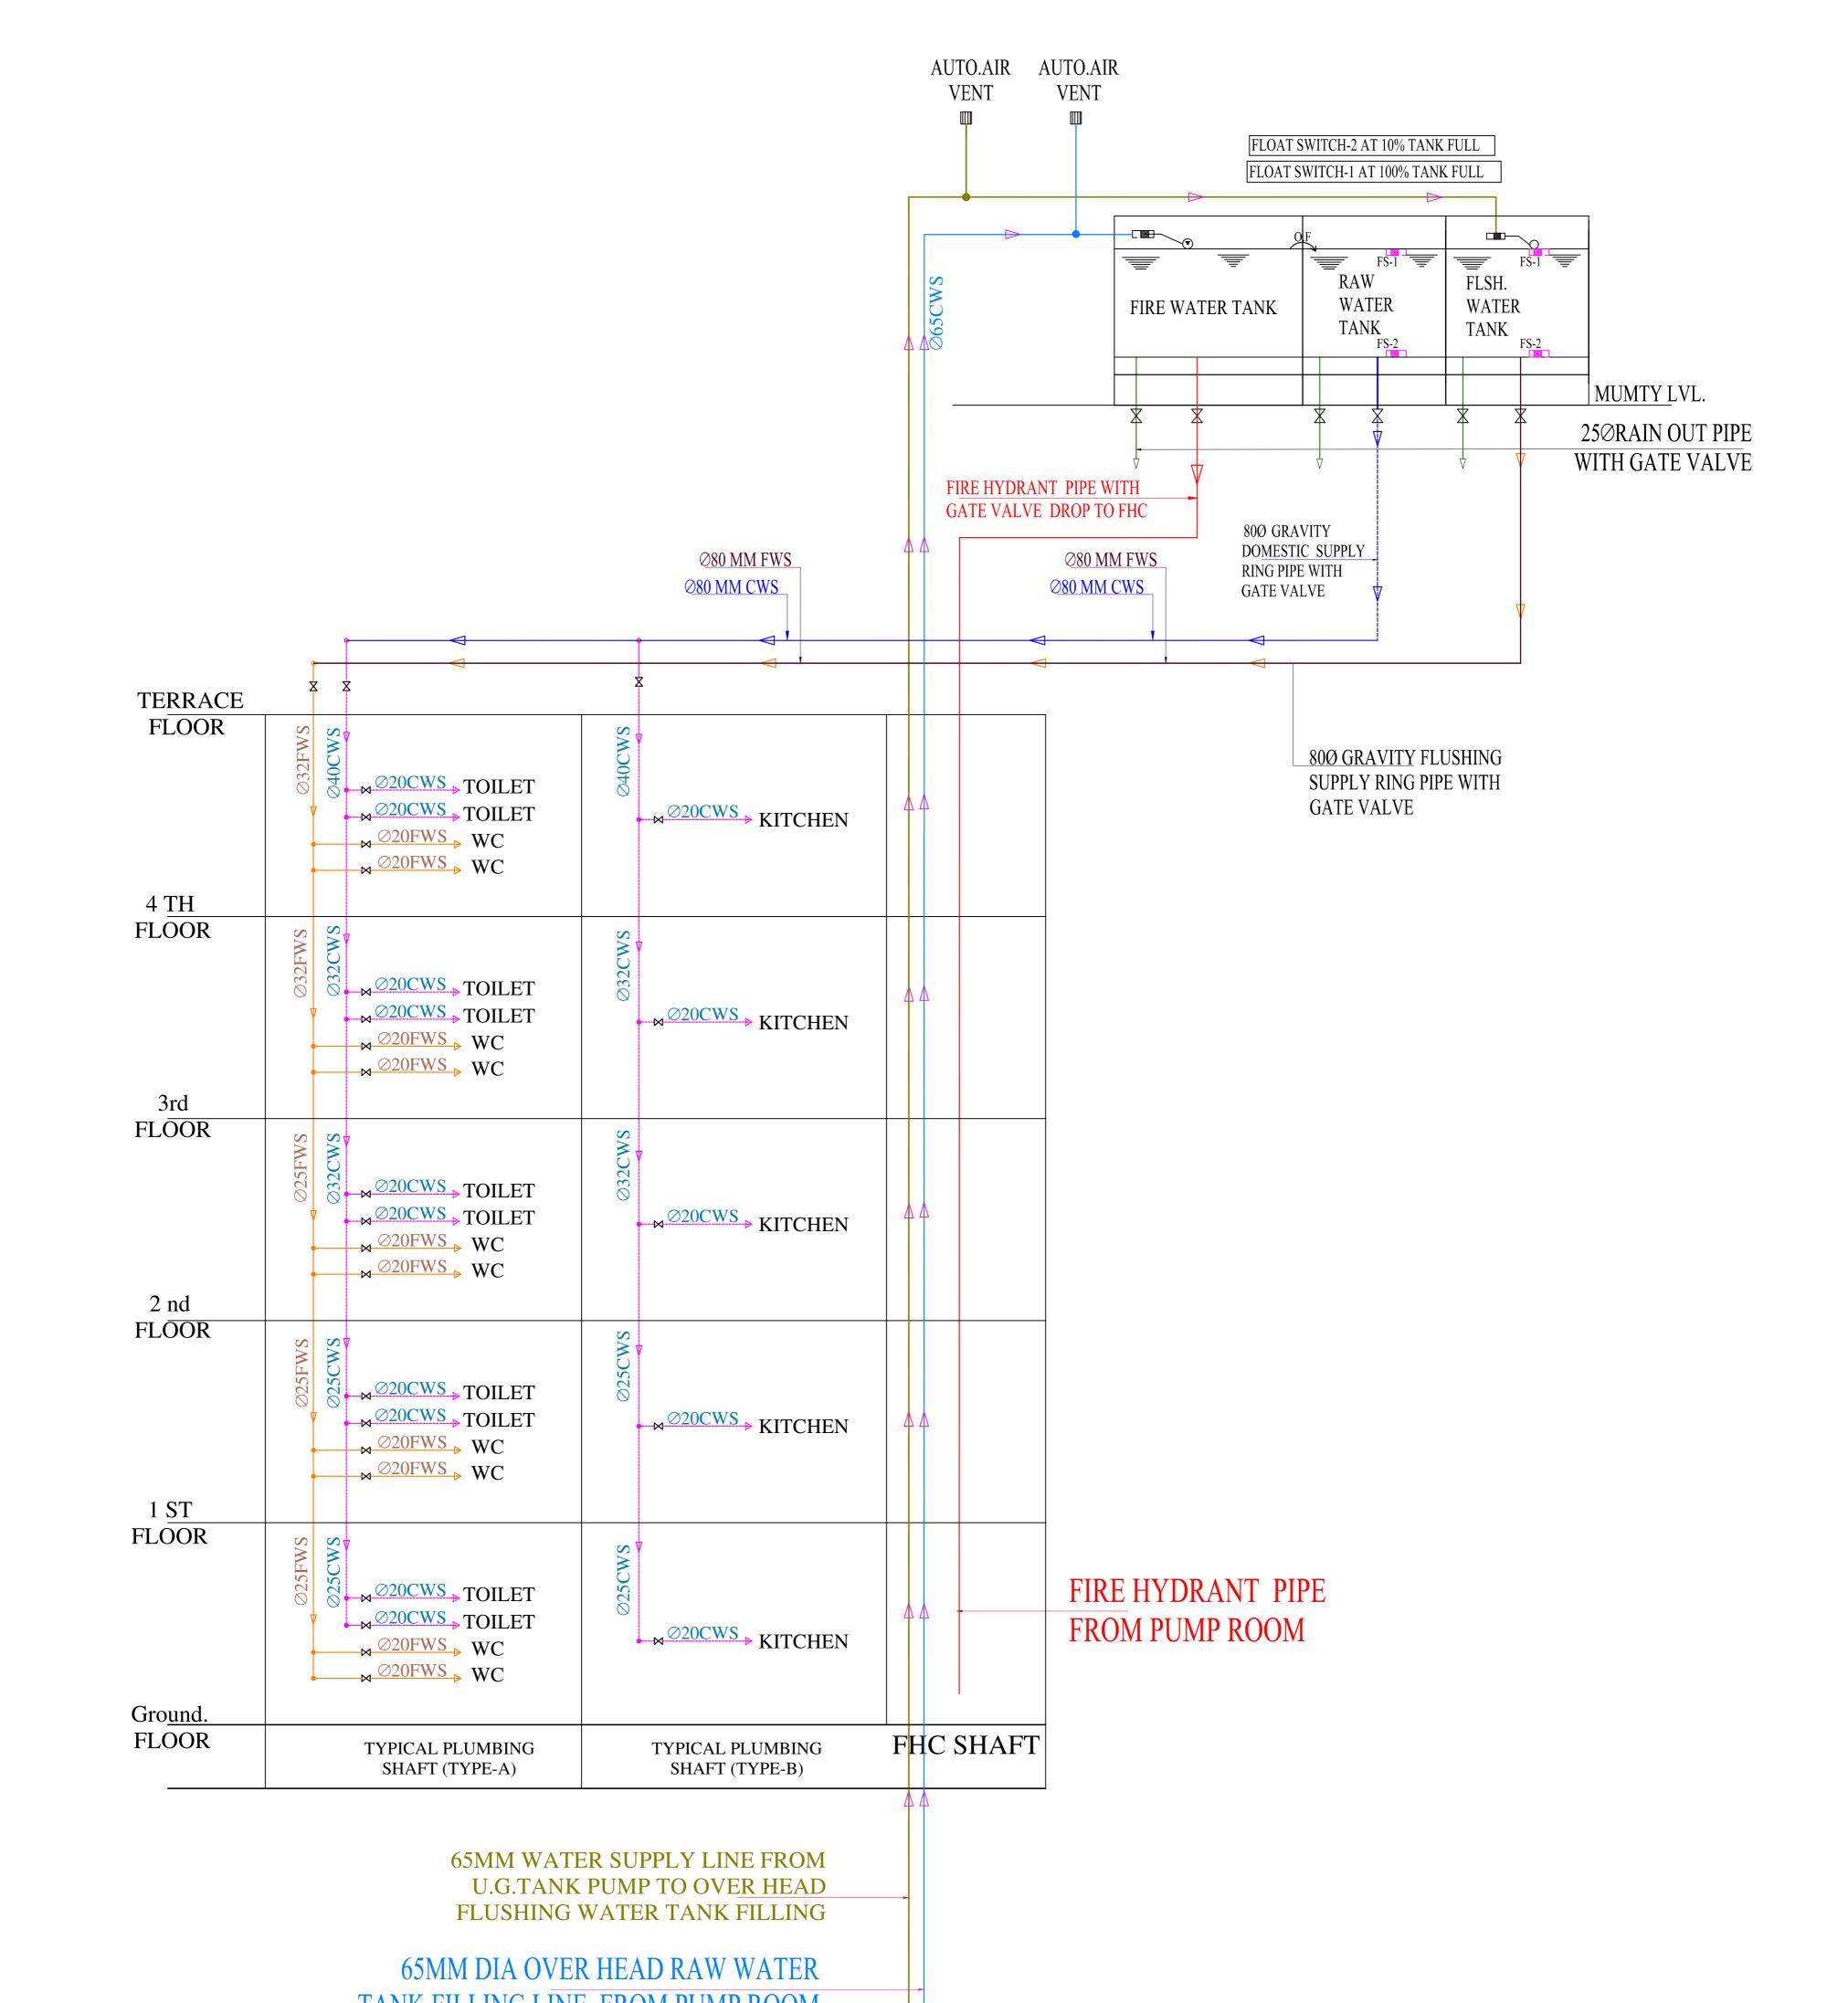


	TANK FILLING LINE	E FROM PUMP ROOM	\mathcal{V}^{\square}			
						VIPUL AGARWAL M.E.P. CONSULTANT B.E. ELECTRICAL
CLIENT :	PROJECT:-	ARCHITECTS :	NAME OF DRAWING:		NORTH:	
des graphite tudio SAMRIDDHI BUILDERS	PROPOSED GSITE PLAN SHOWING RESIDENTIAL PLOT FOR CHEIF MINISTER JAN AWAS YOJANA	GRAPHITE DESIGN STUDIO ARCHITECTS, INTERIOR DESIGNERS, PLANNERS 68, Janak Puri -1st, Imliwala phatak, Opp Jain Mandir, Jaipur	WATER,	<i>TOWER-C SUPPLY SCHEMATIC DIAGRAM</i>	PROJECT NO. : DATE : 24-02-202 SCALE : REV NO. : R-0	F 9 / 440 , Keshav Marg Chitrak Scheme, Jaipur
	SITUATED AT KH. NO. 1296,1306 AT VILLAGE MAKARWALI ,AJMER	CONTACT NO. +91-9928334414, 0141-2593414 email: studiosgraphite@gmail.com	DRN BY:	CKD. BY: APPD. BY:	DRAWING NO. :	PH:91-0-93146-10438 ,0141-2440946 Mail:vipul8599@yahoo.com REV. NO. 01 DATE: 24-02-2021
		Website : www.graphitedesignstudio.com	RAAJ	SANJAY VIPUL AGARWA	AL	REV. NO. 01 DATE: 24-02-2021

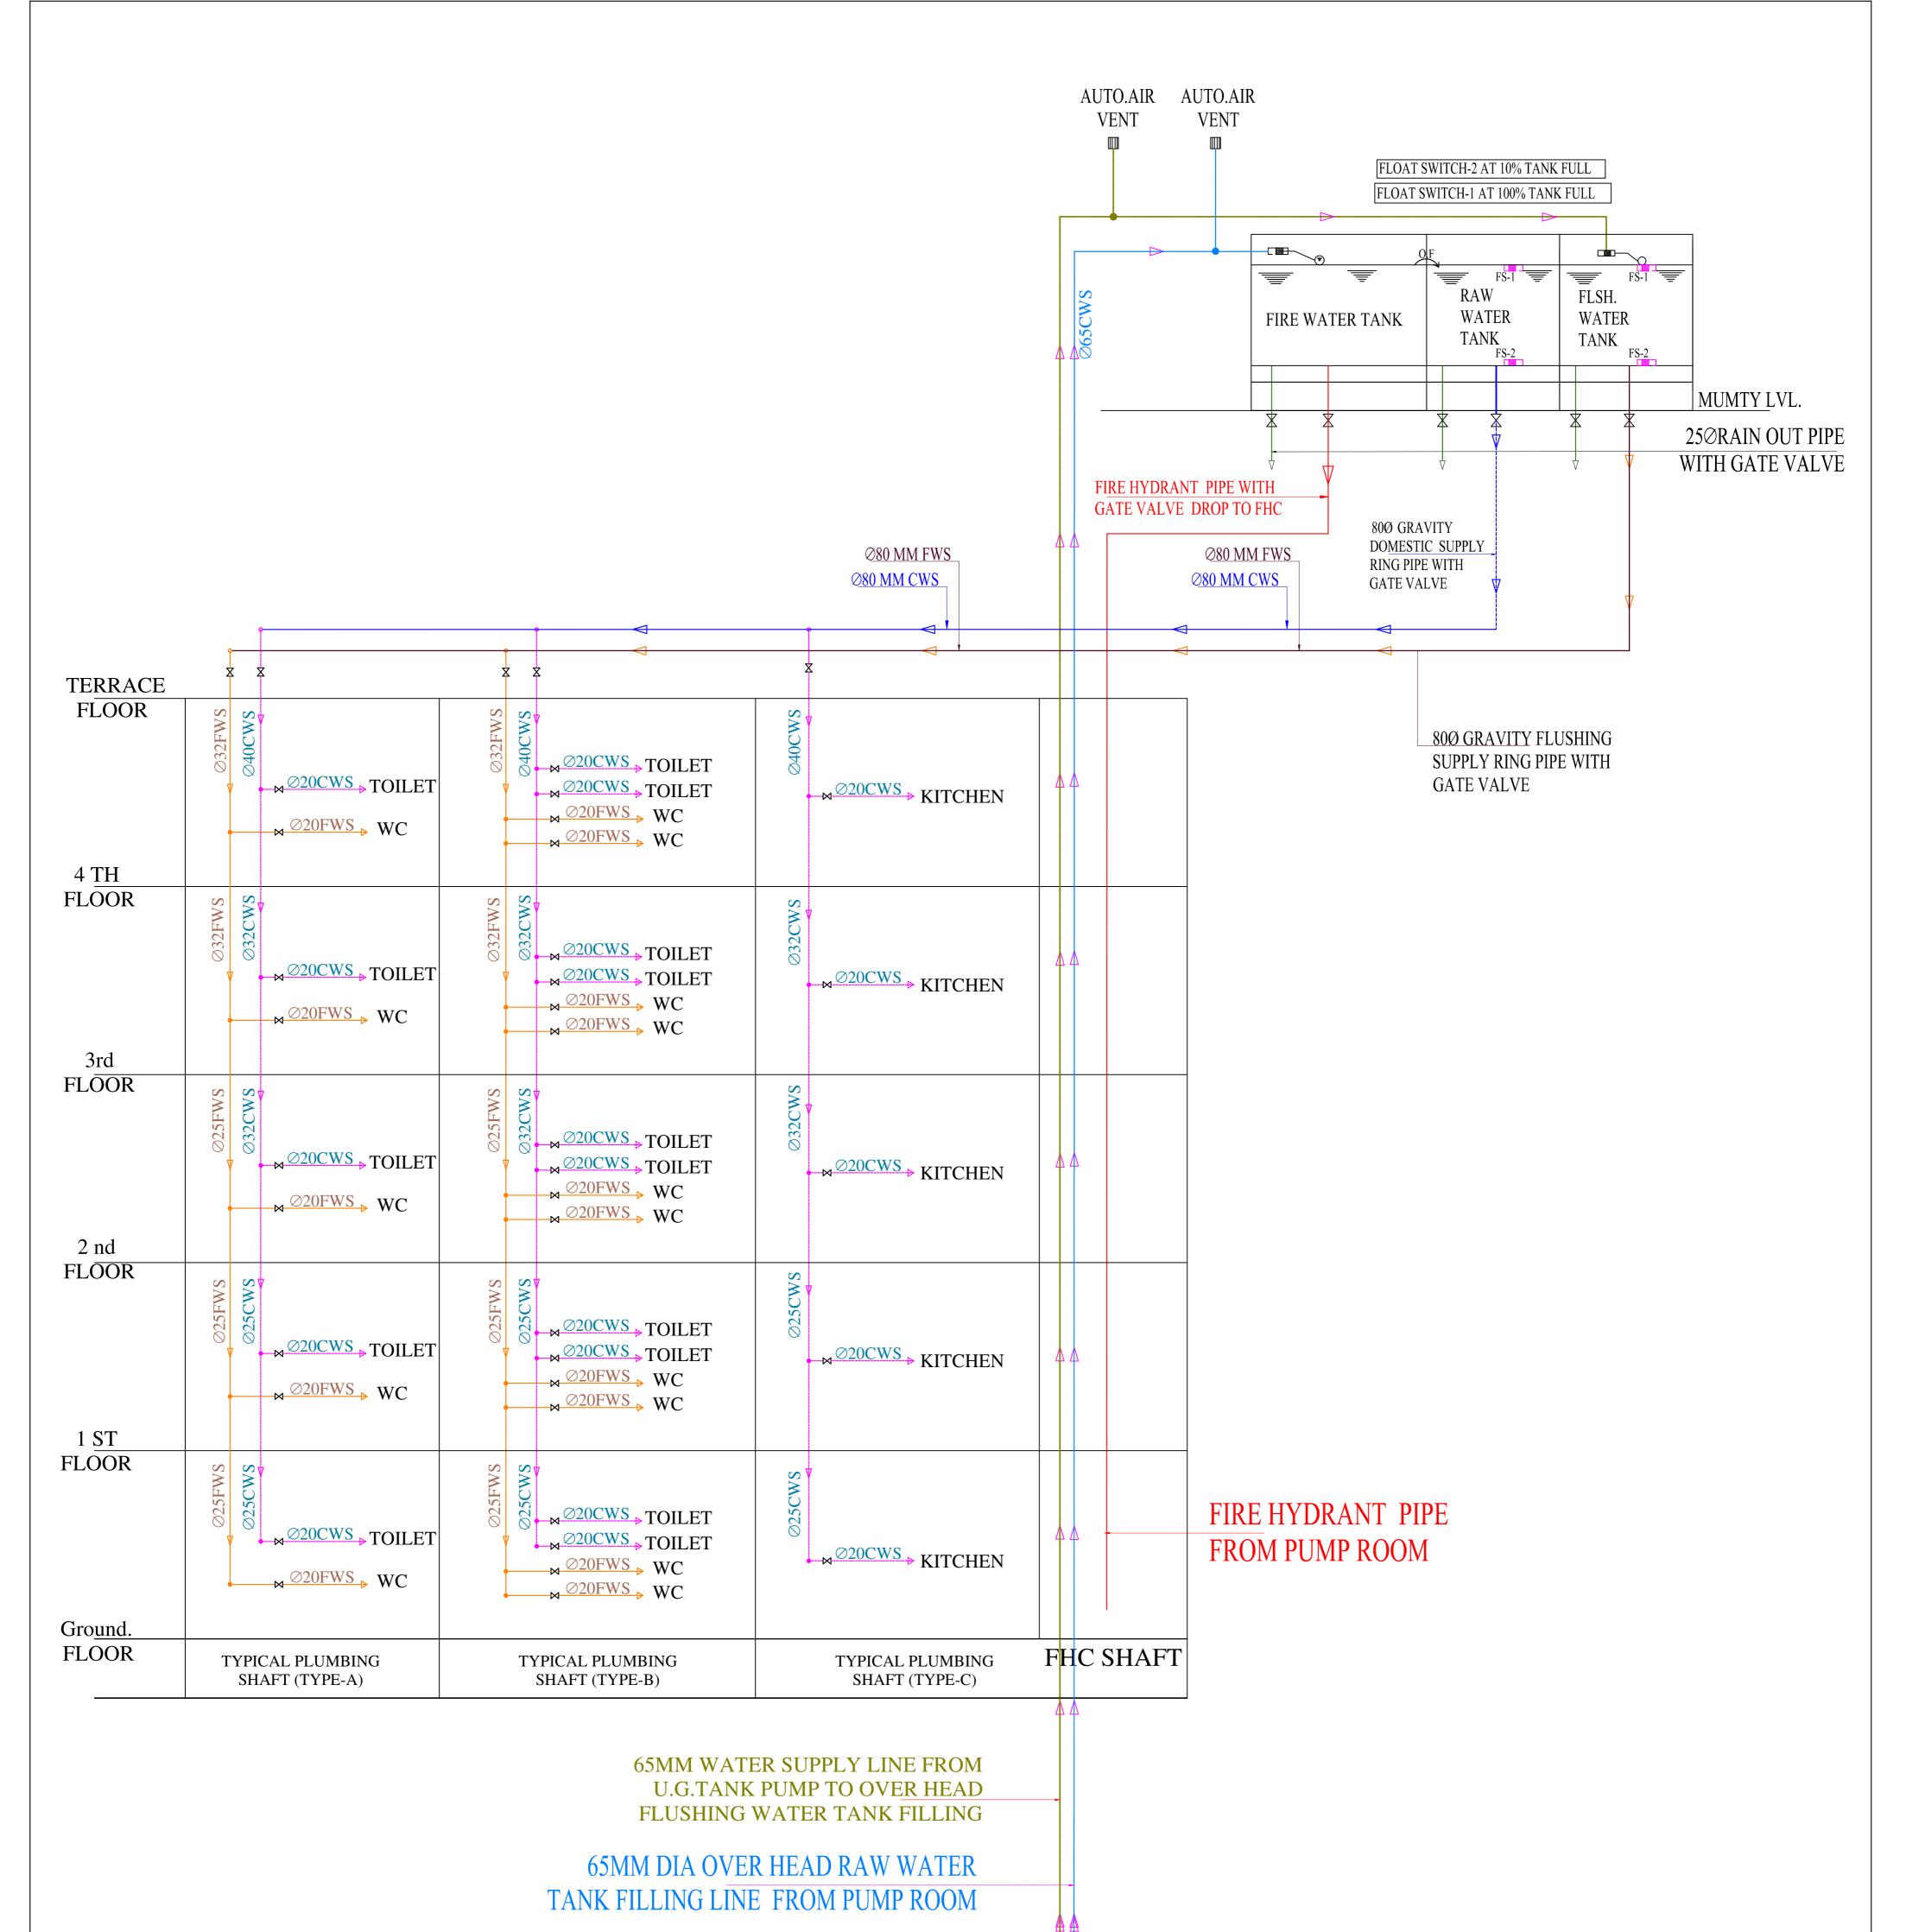

								VIPUL AGARWAL M.E.P. CONSULTANT B.E. ELECTRICAL
LIENT :	PROJECT:-	ARCHITECTS :	NAME OF DRAWING:				NORTH:	
O raphite	DDODOGED COUTE DI AN GLOUVING			TOWER	-D			
des graphite tudio	PROPOSED GSITE PLAN SHOWING RESIDENTIAL PLOT FOR CHEIF		WATER	SUPPLY S	CHEMATIC	PROJECT NO. :	DATE: 24-02-2021	SERVICES CONSULTANT:
	MINISTER JAN AWAS YOJANA	GRAPHITE DESIGN STUDIO ARCHITECTS, INTERIOR DESIGNERS, PLANNERS		DIAGRA	M	SCALE :	24-02-2021 REV NO.:	VIPUL CONSULTING F 9 / 440 , Keshav Marg Chitr
SAMRIDDHI BUILDERS							R-01	Scheme, Jaipur
SAMRIDDHI BUILDERS		68, Janak Puri -1st, Imliwala phatak, Opp Jain Mandir, Jaipur CONTACT NO. +91-9928334414, 0141-2593414			1		It of	PH·91_0_93146_10438_0141_24409
SAMRIDDHI BUILDERS	SITUATED AT KH. NO. 1296,1306 AT VILLAGE MAKARWALI ,AJMER	68, Janak Puri -1st, Imliwala phatak, Opp Jain Mandir, Jaipur CONTACT NO. +91-9928334414, 0141-2593414 email: studiosgraphite@gmail.com Website : www.graphitedesignstudio.com	DRN BY:	CKD. BY:	APPD. BY:	DRAWING NO. :		PH:91-0-93146-10438 ,0141-24409 Mail:vipul8599@yahoo.com REV. NO. 01 DATE: 24-02-2021

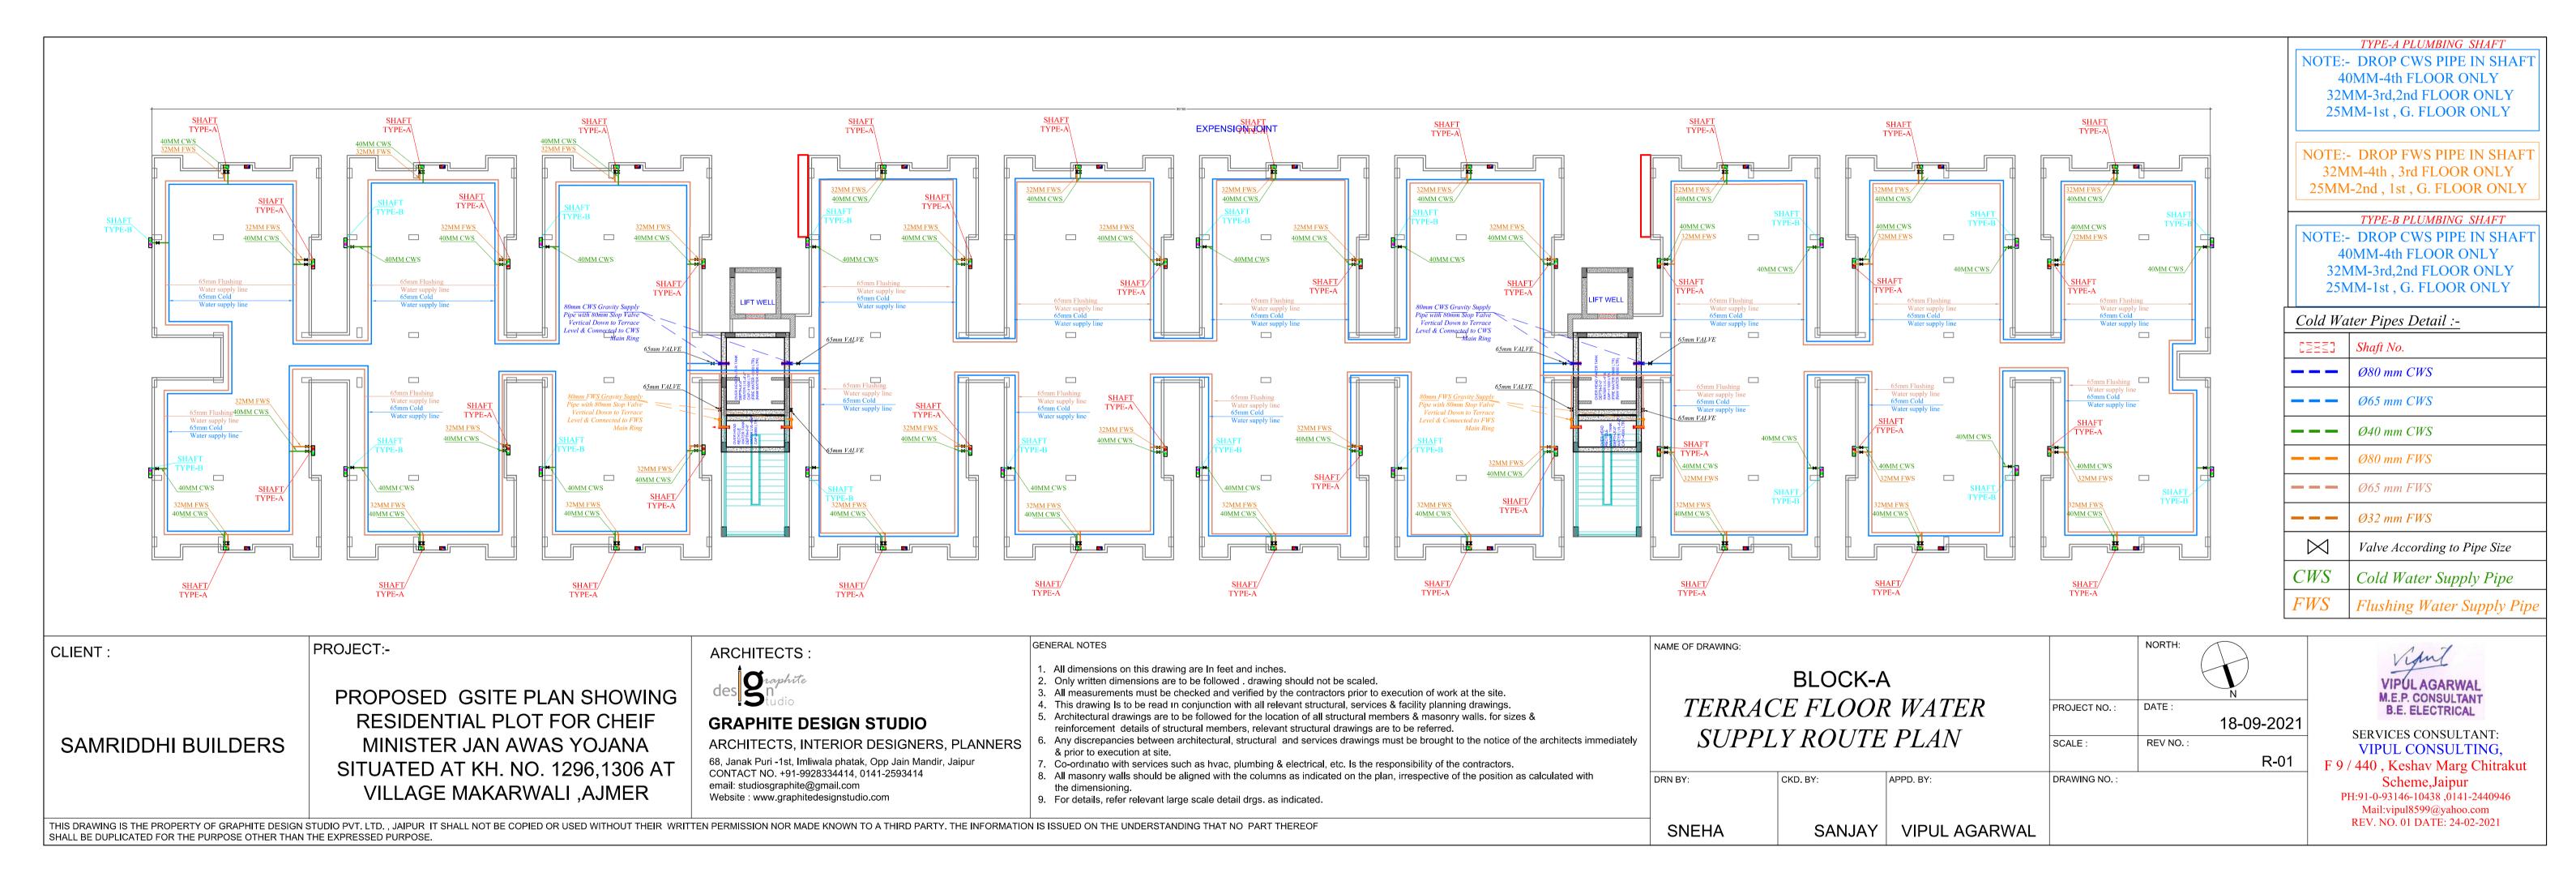

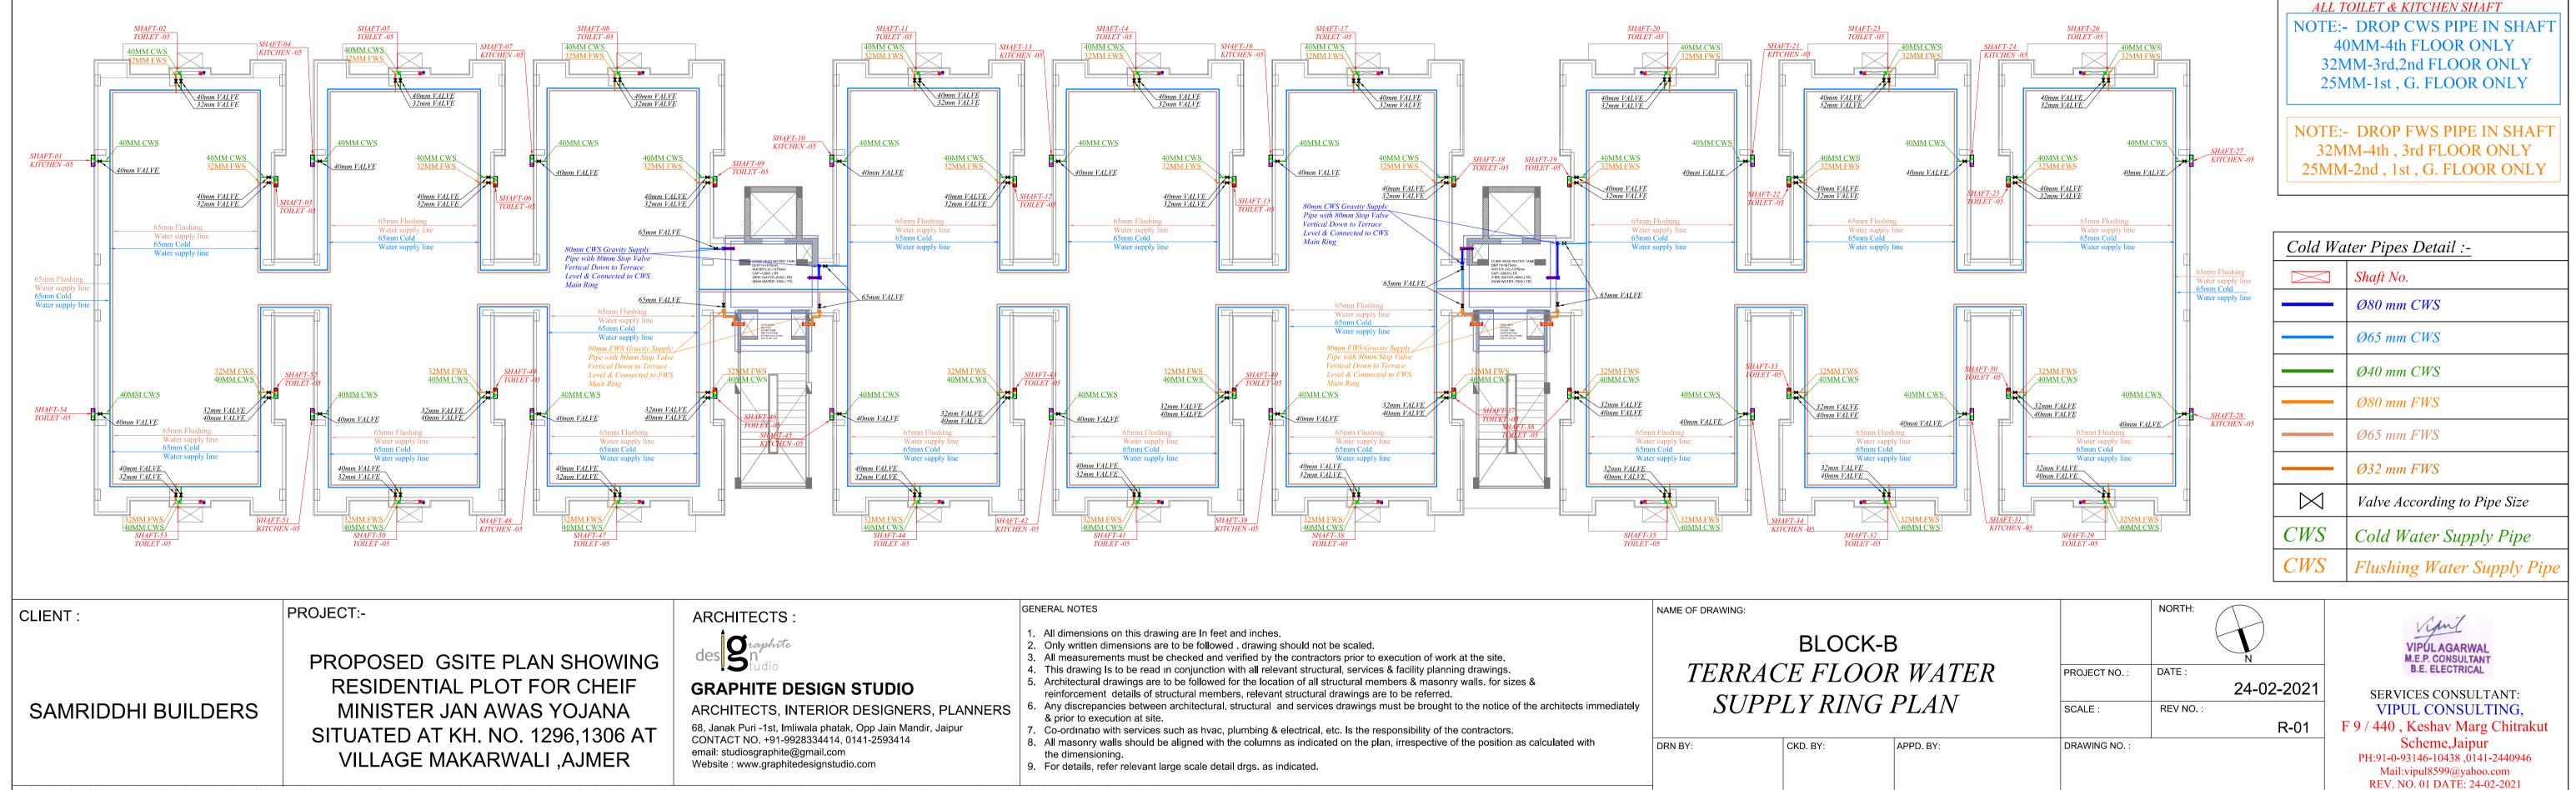


THIS DRAWING IS THE PROPERTY OF GRAPHITE DESIGN STUDIO PVT. LTD., JAIPUR IT SHALL NOT BE COPIED OR USED WITHOUT THEIR WRITTEN PERMISSION NOR MADE KNOWN TO A THIRD PARTY. THE INFORMATION IS ISSUED ON THE UNDERSTANDING THAT NO PART THEREOF


SHALL BE DUPLICATED FOR THE PURPOSE OTHER THAN THE EXPRESSED PURPOSE.

SANJAY VIPUL AGARWAL

GANGA RAM

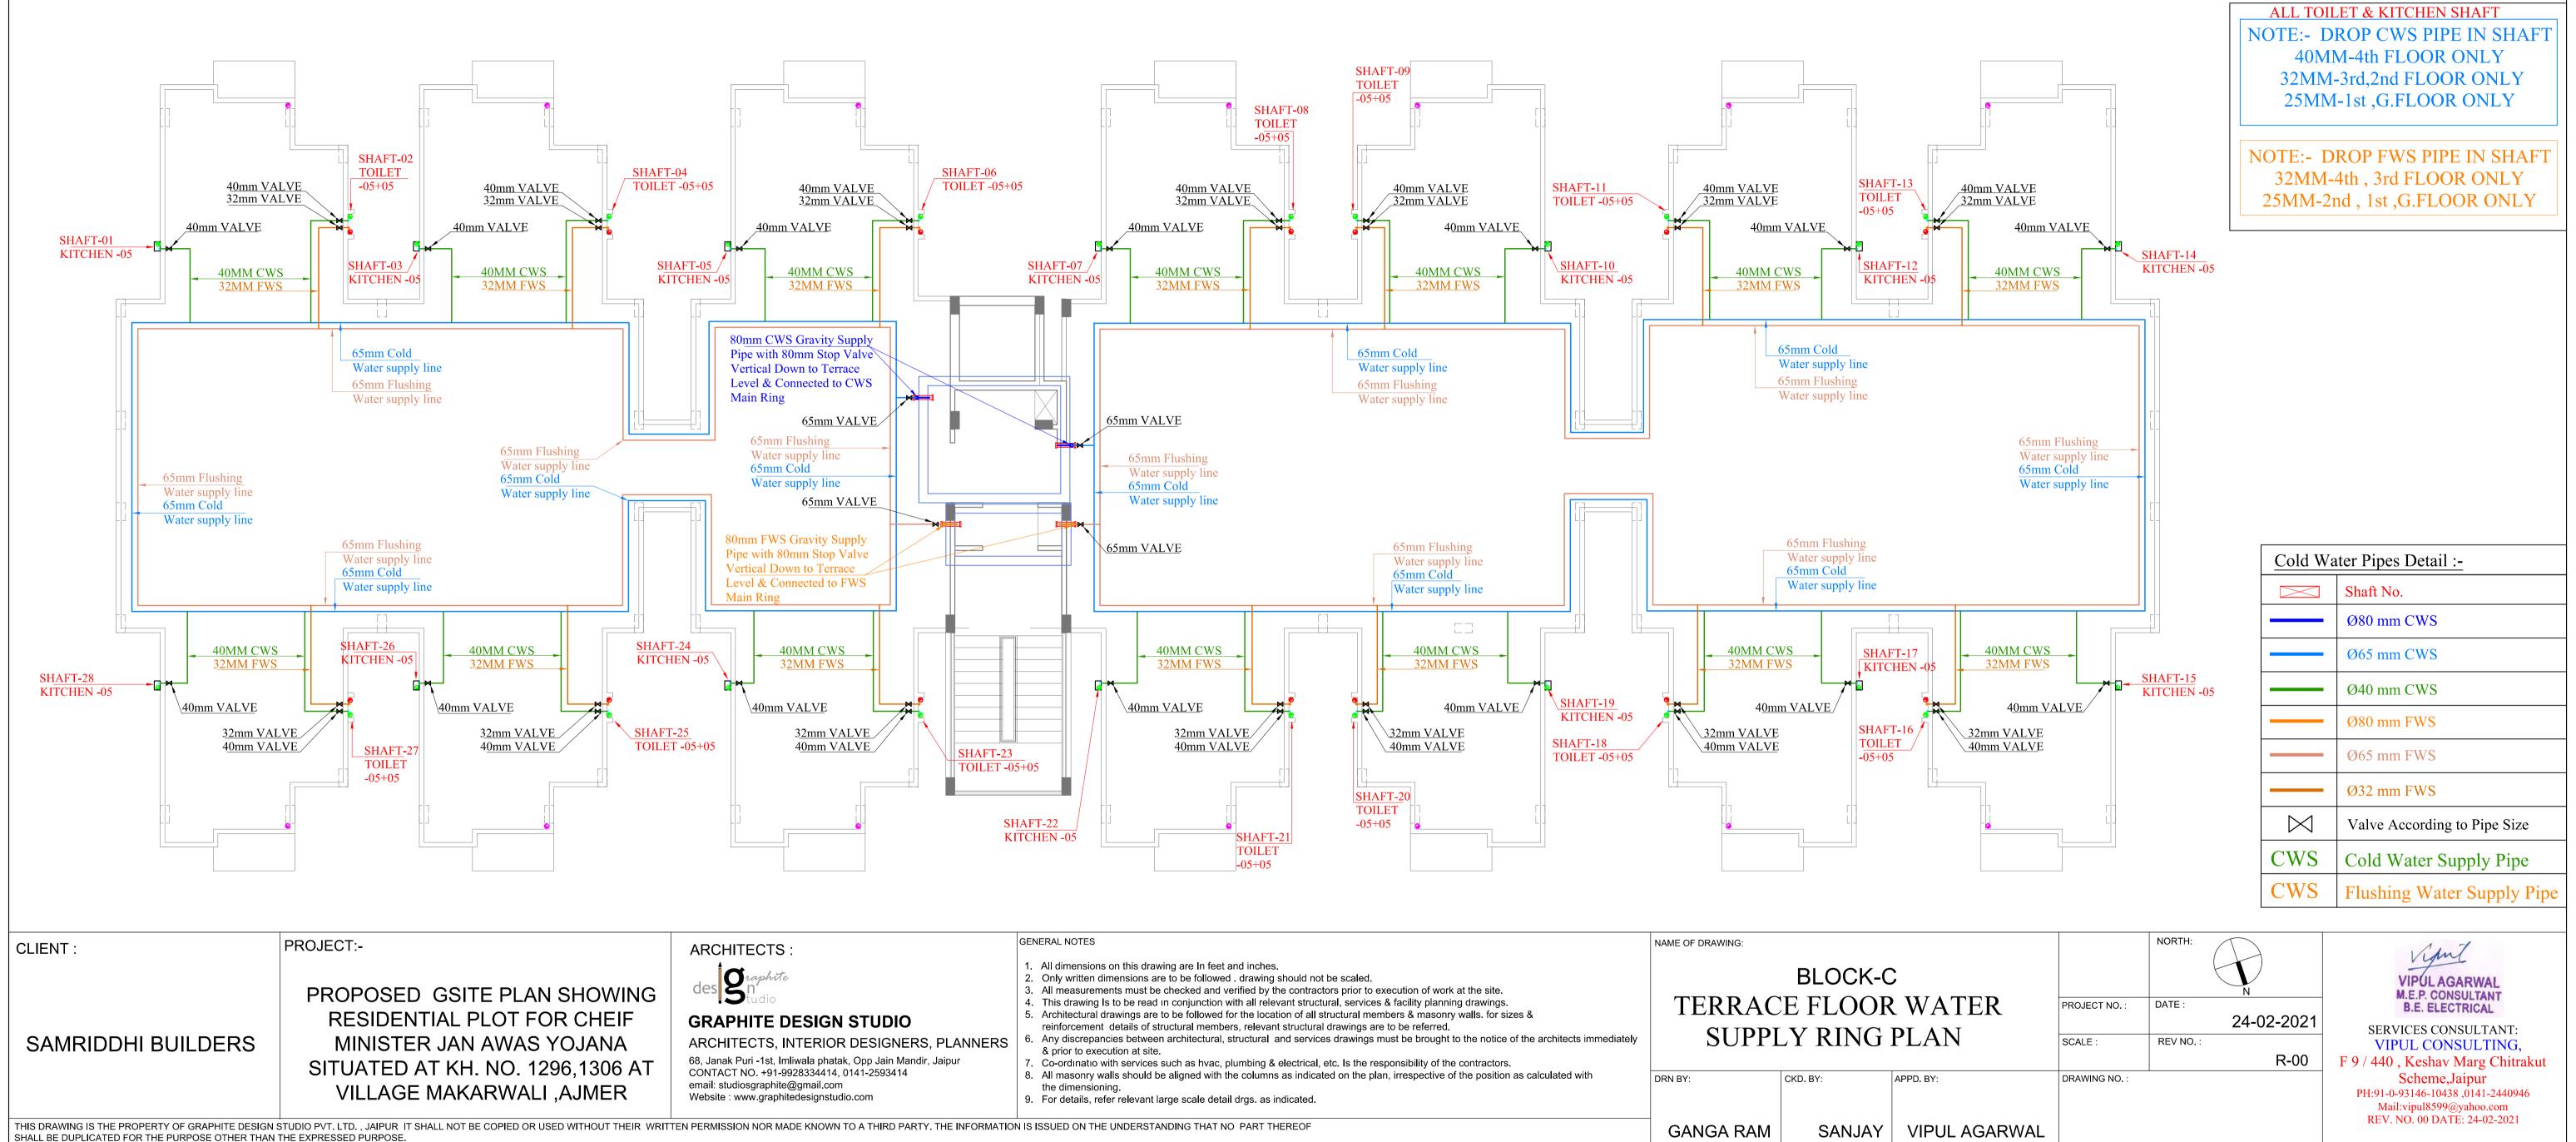

Calpai	7. Co-ordinatio with services such as fivac, plumbing & electrical, etc. is the responsibility of the contractors.			
	 All masonry walls should be aligned with the columns as indicated on the plan, irrespective of the position as calculated with the dimensioning. For details, refer relevant large scale detail drgs. as indicated. 	DRN BY:	CKD. BY:	APPD. BY
THE INFORMATION	I IS ISSUED ON THE UNDERSTANDING THAT NO PART THEREOF	GANGA RAM	SANJAY	VIP

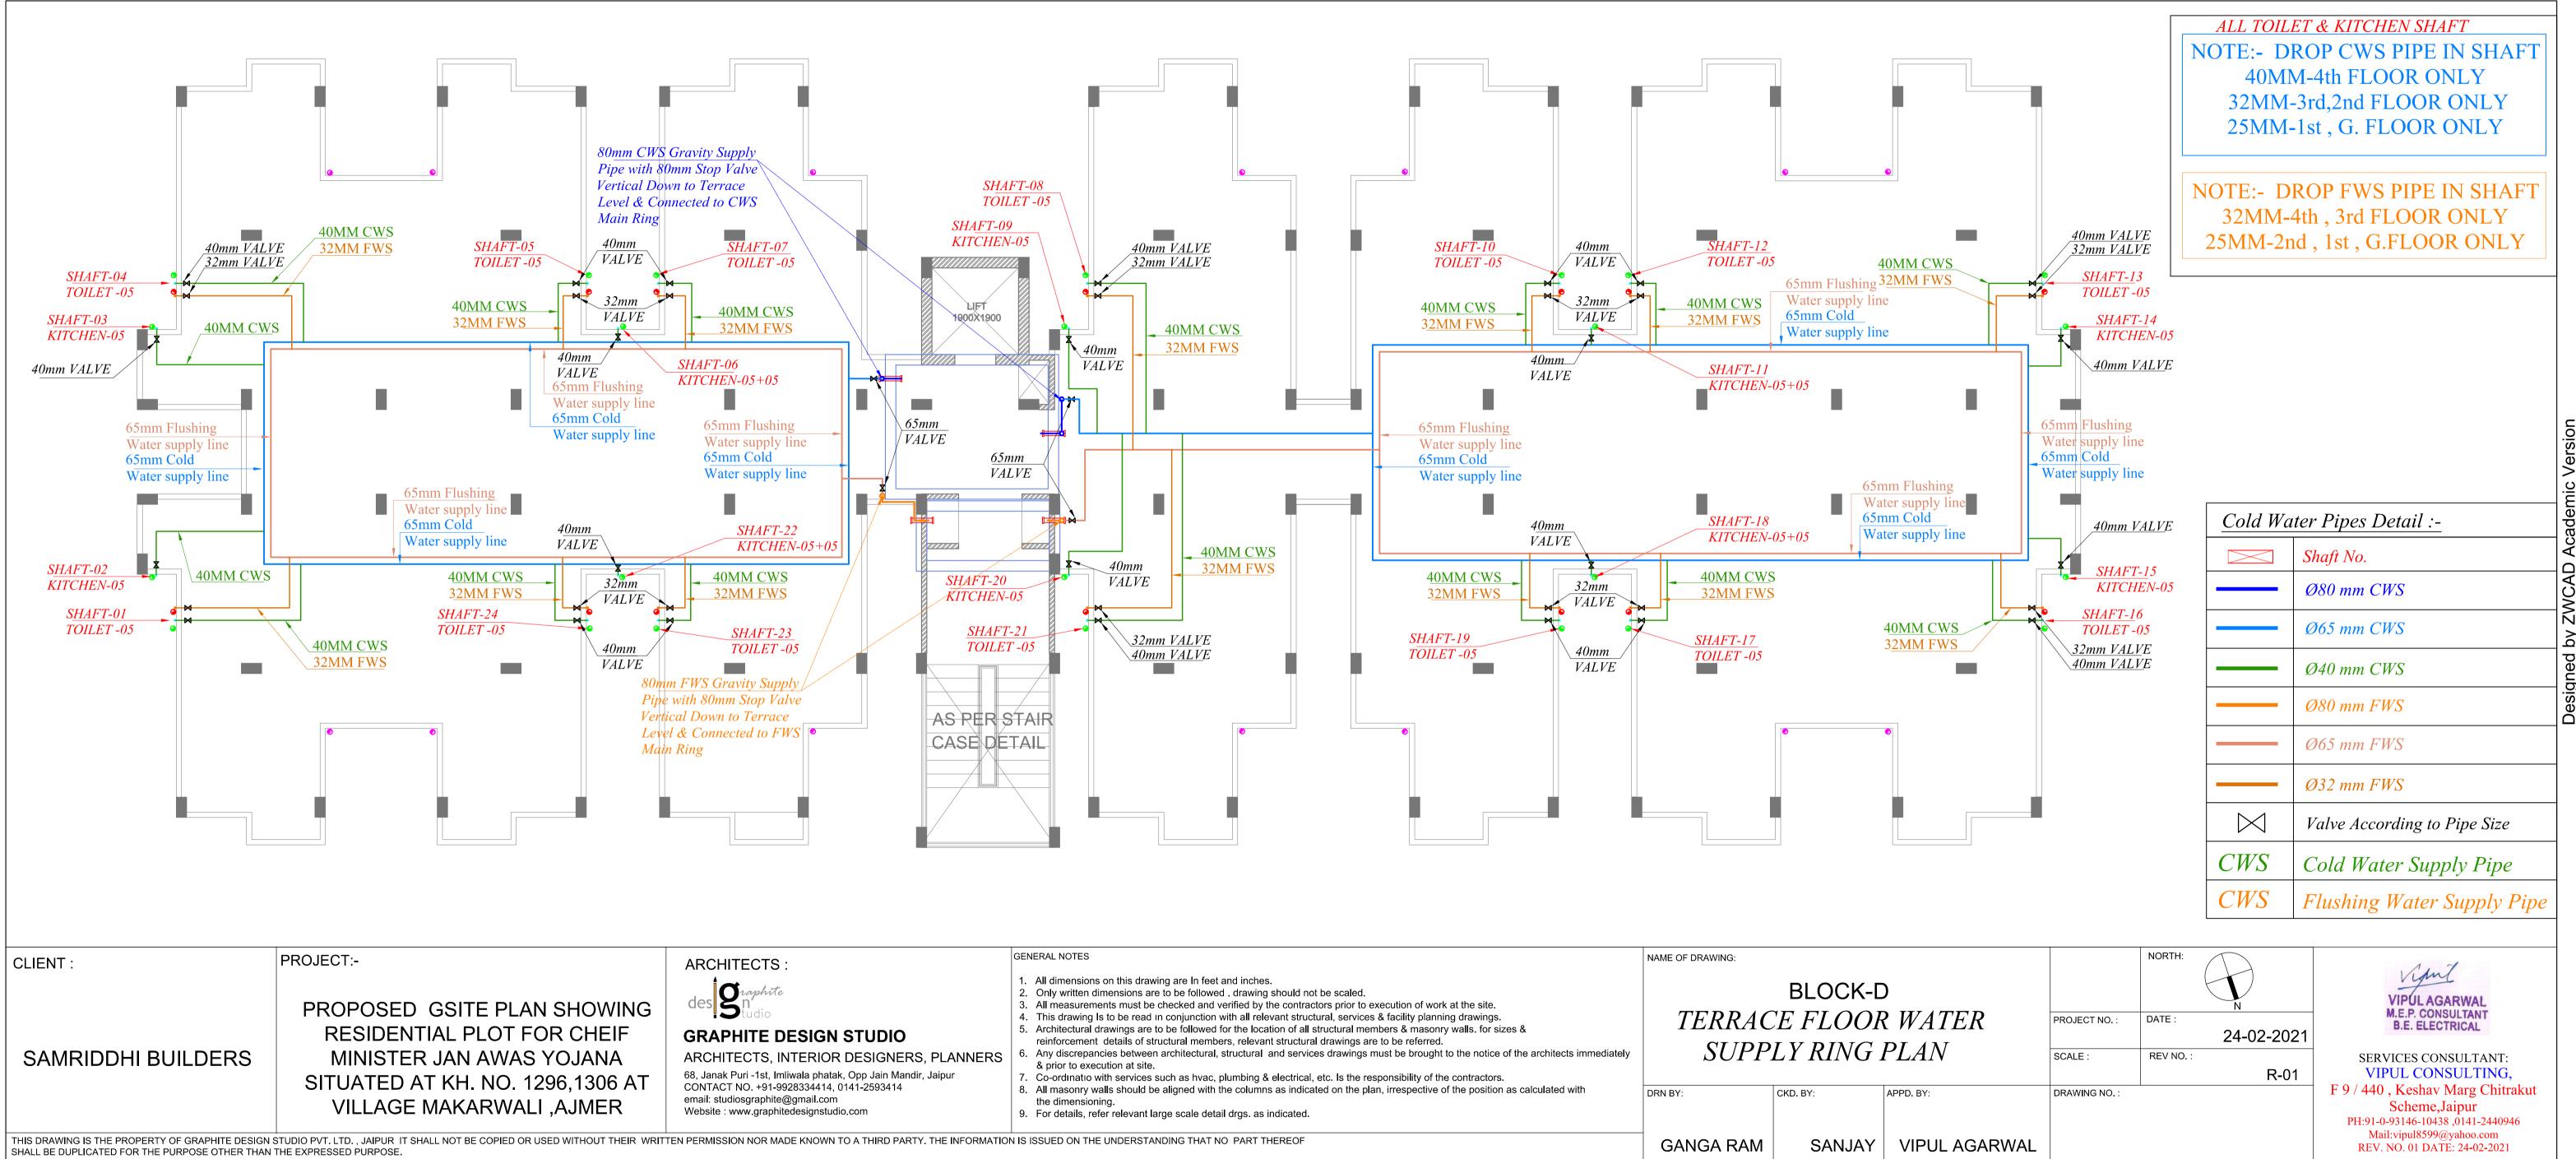

	GENERAL NOTES	NAME OF DRAWING:			
ANNERS	 All dimensions on this drawing are In feet and inches. Only written dimensions are to be followed . drawing should not be scaled. All measurements must be checked and verified by the contractors prior to execution of work at the site. This drawing Is to be read in conjunction with all relevant structural, services & facility planning drawings. Architectural drawings are to be followed for the location of all structural members & masonry walls. for sizes & reinforcement details of structural members, relevant structural drawings are to be referred. Any discrepancies between architectural, structural and services drawings must be brought to the notice of the architects immediately & prior to execution at site. Co-ordinatio with services such as hvac, plumbing & electrical, etc. Is the responsibility of the contractors. 	BLOCK-D TERRACE FLOOR WAT SUPPLY RING PLAN			
	 All masonry walls should be aligned with the columns as indicated on the plan, irrespective of the position as calculated with the dimensioning. 	DRN BY:	CKD. BY:	APPD. BY:	
	9. For details, refer relevant large scale detail drgs. as indicated.				
INFORMATIO	N IS ISSUED ON THE UNDERSTANDING THAT NO PART THEREOF	GANGA RAM	SANJAY	VIPUL /	

ρ ed sigi